

ARKANSAS DEPARTMENT OF TRANSPORTATION
EQUIPMENT AND PROCUREMENT OFFICE
LITTLE ROCK, ARKANSAS

March 3, 2020

NOTICE TO BIDDERS

ADDENDUM

Bid Number: M-20-032H

Standby Generator Power for Materials Division

Opening Date: March 31, 2020

Bid Invitation:

Drawings attached to the Bid Invitation are sized 8.5 x 11 and difficult to read when printed.


Drawings attached to the addendum have been resized to 24 x 36.

ALL OTHER SPECIFICATIONS SHALL REMAIN THE SAME.


Danny Keene
Division Head
Equipment and Procurement

ARKANSAS DEPARTMENT OF TRANSPORTATION CONSTRUCTION PLANS: MATERIALS LAB STANDBY GENERATORS

LITTLE ROCK, ARKANSAS PULASKI COUNTY JOB 42-72

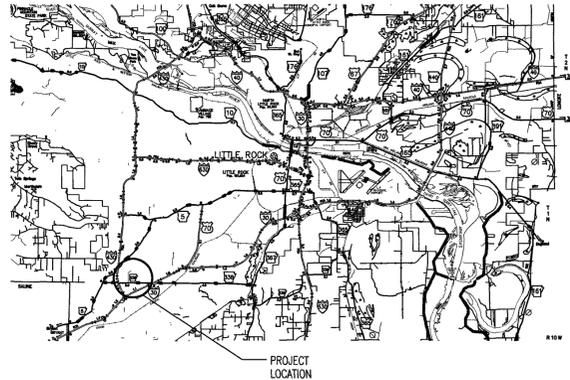


NORTH
VICINITY MAP
SCALE: NO SCALE

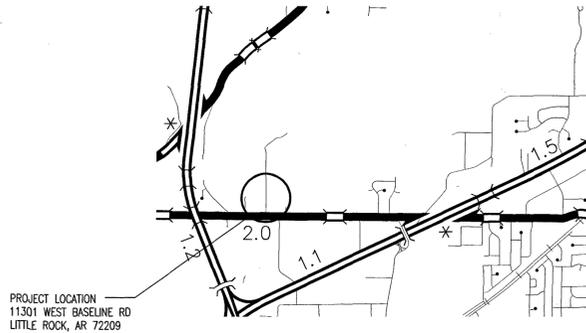

PROJECT LOCATION
11301 WEST BASELINE RD
LITTLE ROCK, AR 72209

NORTH
LOCATION MAP
SCALE: NO SCALE

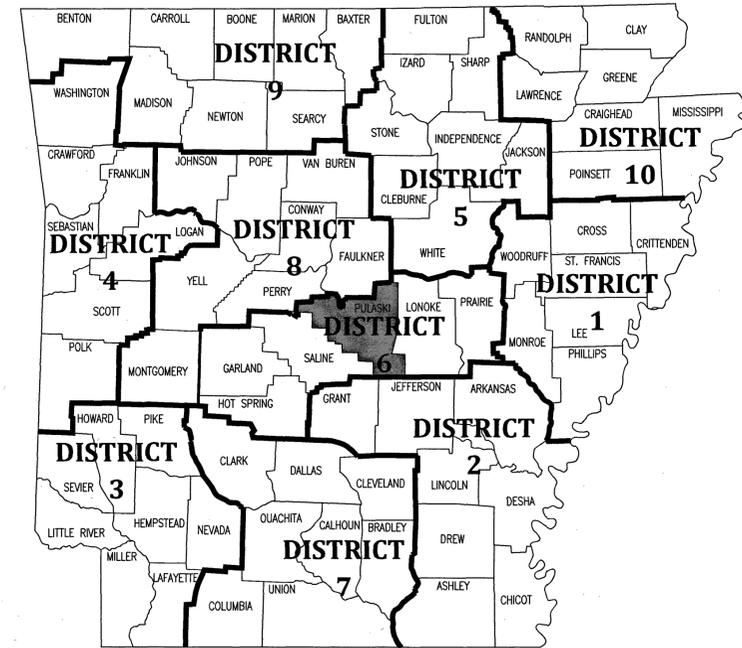


ARK. HWY. DIST. NO. 6

INDEX OF SHEETS		
SHEET NO.		SHEET TITLE
G1.1	1	TITLE SHEET
E1.1	2	PLANS AND DETAILS




COVER SHEET

MATERIALS LAB STANDBY
GENERATOR INSTALLATION
Little Rock, Arkansas
Pulaski County

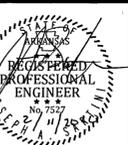


DATE: JAN. 30, 2020
JOB NO: 42-72
DRAWN BY: K.B.
REVISIONS:


G1.1
1 OF 2

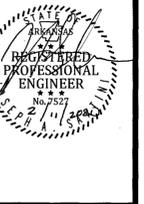


DATE: JAN. 30, 2020
JOB NO: 42-72
DRAWN BY: K.B.
REVISIONS:

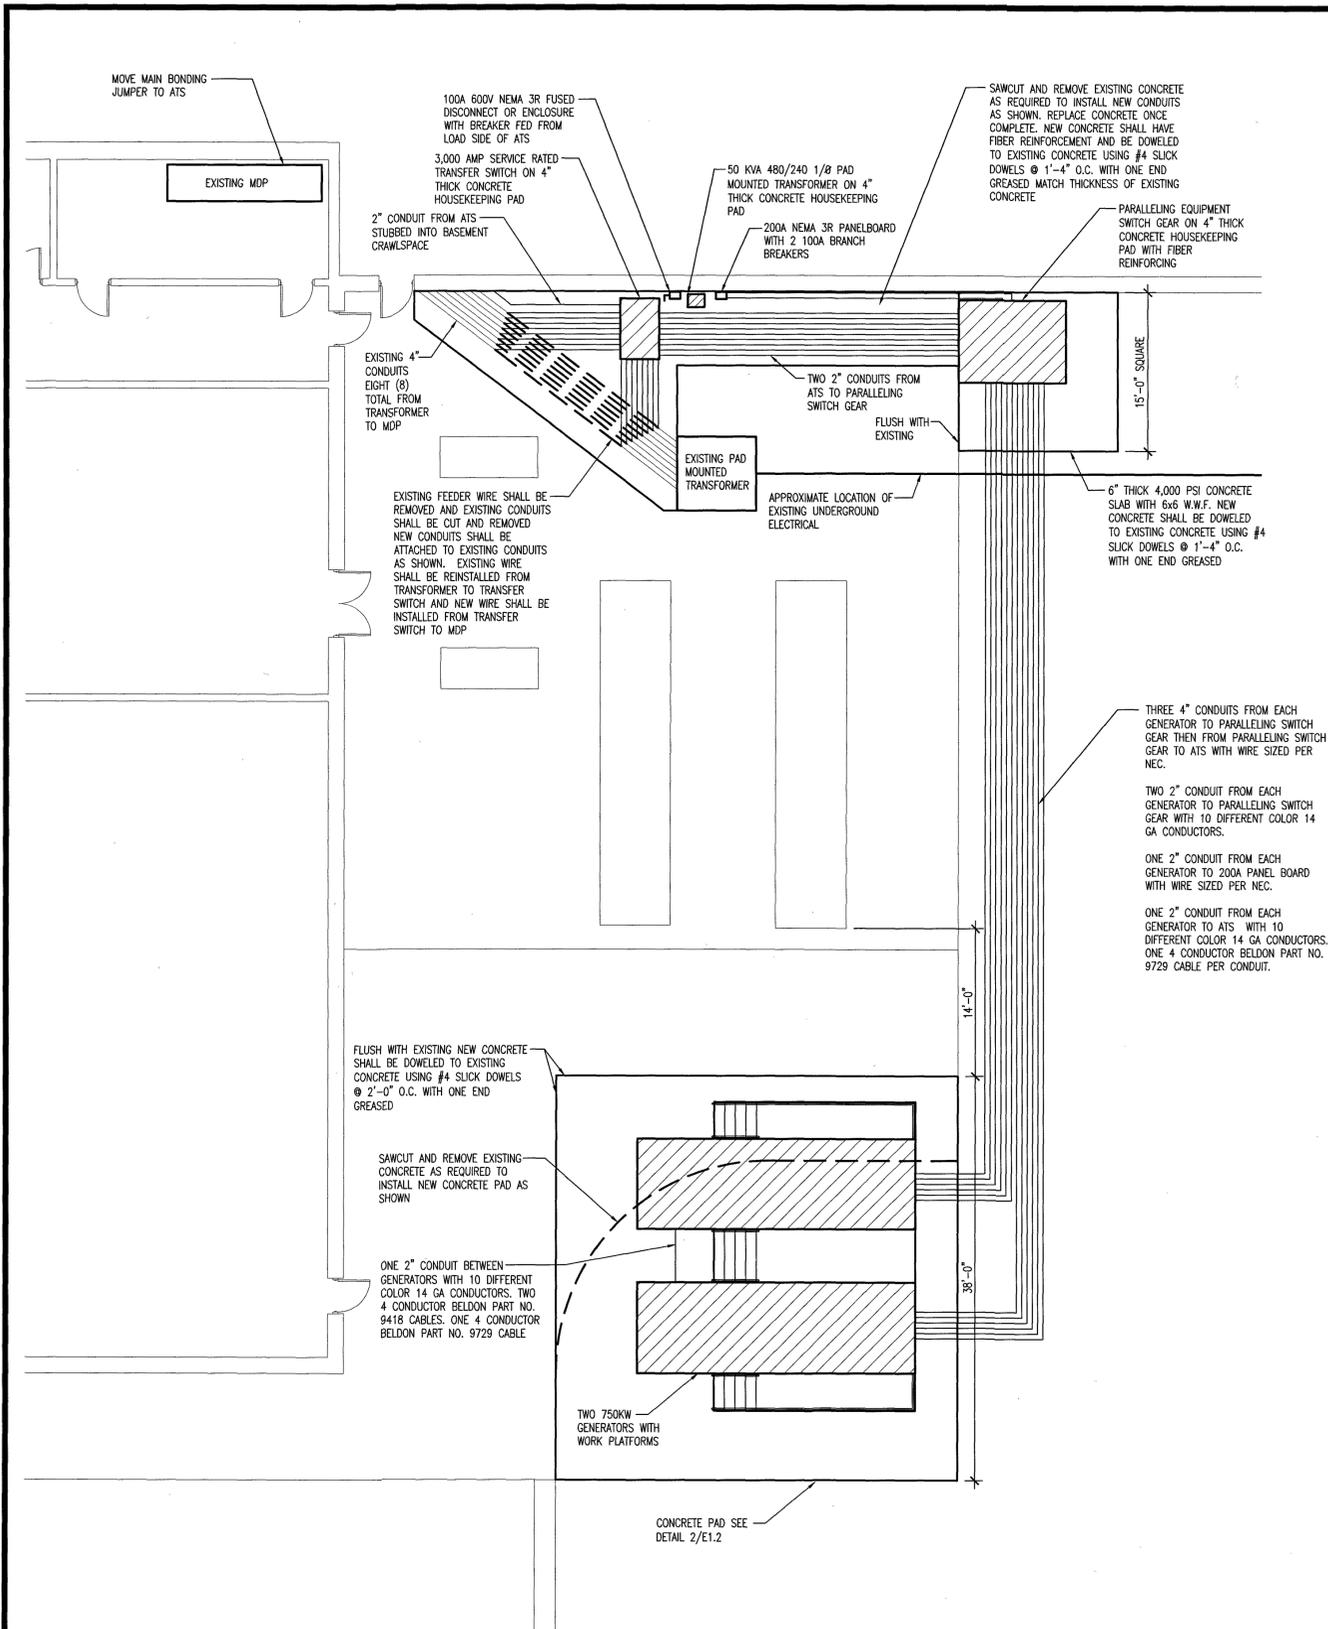


- GENERAL NOTES:
1. CONTRACTOR SHALL OBTAIN ALL REQUIRED PERMITS, FEES, AND INSPECTIONS AS REQUIRED BY LOCAL AUTHORITIES HAVING JURISDICTION.
 2. CONTRACTOR SHALL FOLLOW ALL CURRENT ADOPTED CODES BY LOCAL AUTHORITIES HAVING JURISDICTION.
 3. THIS PLAN IS A CONCEPTUAL DESIGN. CONTRACTOR SHALL PROVIDE A SIGNED AND SEALED SUBMITTAL FROM AN ELECTRICAL ENGINEER THAT IS LICENSED IN THE STATE OF ARKANSAS BEFORE WORK SHALL START.
 4. ALL UNDERGROUND CONDUITS SHALL BE BURIED A MINIMUM OF 2'-0" BELOW EXISTING GRADE.

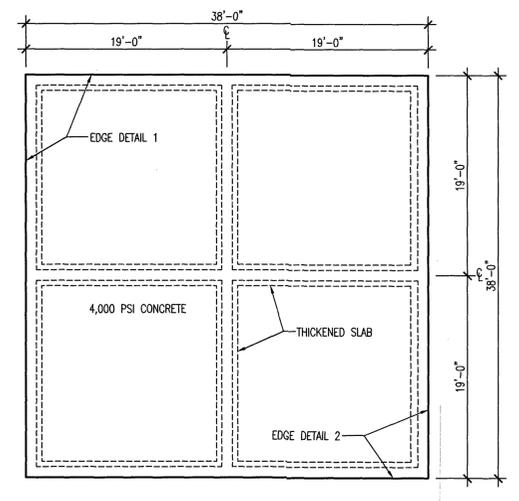

2 GENERATOR PAD PLAN
SCALE: 1/8"=1'-0"

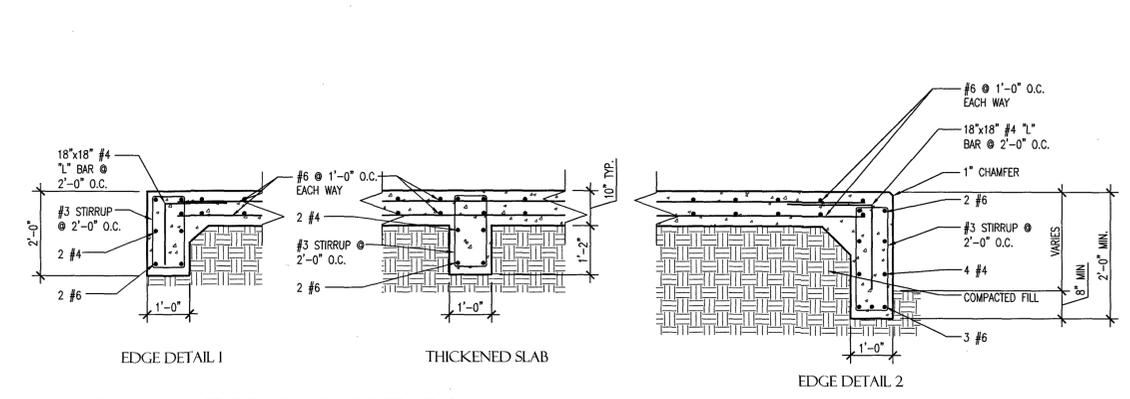

1 GENERATOR PAD DETAILS
SCALE: 1/2"=1'-0"

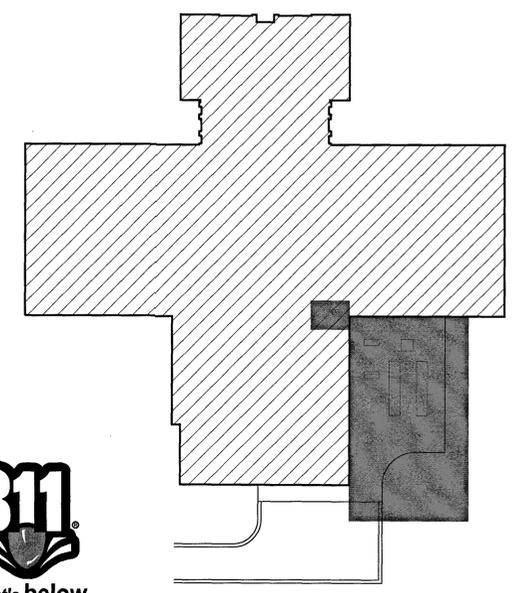

KEY PLAN

1 ENLARGED SITE PLAN
SCALE: 1/8"=1'-0"

