



DATE REVISED	DATE FILMED	DATE REVISED	DATE FILMED	FED. RD. DIST. NO.	STATE	FED. AID PROJ. NO.	SHEET NO.	TOTAL SHEETS
				6	ARK.			
				JOB NO.	020520		2	36

2 INDEX OF SHEETS AND GOV. SPECIFICATIONS



2-14-12

INDEX OF SHEETS

SHEET NO.	TITLE	DRAWING NO.	DATE
1	TITLE SHEET		
2	INDEX OF SHEETS AND GOVERNING SPECIFICATIONS		
3	GENERAL NOTES		
4-5	TEMPORARY EROSION CONTROL DETAILS		
6-7	INTERSECTION IMPROVEMENT DETAILS		
8-9	MAINTENANCE OF TRAFFIC DETAILS		
10-11	PERMANENT PAVEMENT MARKING DETAILS		
12	SUMMARY OF QUANTITIES AND REVISIONS		
13-15	SURVEY CONTROL DETAILS		
16	TRAFFIC SIGNAL NOTES		
17-24	SIGNALIZATION PLAN SHEETS		
25-29	SIGNALIZATION DETAILS		
30	CURBING DETAILS	CG-1	11-29-07
31	DETAILS OF DRIVEWAYS & ISLANDS	DR-1	11-29-07
32	PAVEMENT MARKING DETAILS	PM-1	11-17-10
33	STANDARD TRAFFIC CONTROLS FOR HIGHWAY CONSTRUCTION	TC-1	12-15-11
34	STANDARD TRAFFIC CONTROLS FOR HIGHWAY CONSTRUCTION	TC-2	3-11-10
35	STANDARD TRAFFIC CONTROLS FOR HIGHWAY CONSTRUCTION	TC-3	10-15-09
36	WHEELCHAIR RAMPS NEW CONSTRUCTION AND ALTERATIONS	WR-1	11-10-05

GOVERNING SPECIFICATIONS

ARKANSAS STATE HIGHWAY COMMISSION STANDARD SPECIFICATIONS FOR HIGHWAY CONSTRUCTION, EDITION OF 2003, AND THE FOLLOWING SPECIAL PROVISIONS AND SUPPLEMENTAL SPECIFICATIONS:

NUMBER	TITLE
ERRATA	ERRATA FOR THE BOOK OF STANDARD SPECIFICATIONS
FHWA-1273	FHWA-1273 REVISIONS
FHWA-1273	REQUIRED CONTRACT PROVISIONS FOR FEDERAL-AID CONSTRUCTION CONTRACTS
FHWA-1273	SUPPLEMENT-EQUAL OPPORTUNITY - NOTICE TO CONTRACTORS
FHWA-1273	SUPPLEMENT-SPECIFIC EQUAL EMPLOYMENT OPPORTUNITY RESPONSIBILITIES (23 U.S.C. 140)
FHWA-1273	SUPPLEMENT-EQUAL EMPLOYMENT OPPORTUNITY - GOALS AND TIMETABLES
FHWA-1273	SUPPLEMENT-EQUAL EMPLOYMENT OPPORTUNITY - FEDERAL STANDARDS
FHWA-1273	SUPPLEMENT-POSTERS AND NOTICES REQUIRED FOR FEDERAL-AID PROJECTS
FHWA-1273	SUPPLEMENT-WAGE RATE DETERMINATION
100-2	MANUAL FOR ASSESSING SAFETY HARDWARE (MASH)
102-1	BIDDING REQUIREMENTS AND CONDITIONS
103-1	DETERMINATION OF DBE PARTICIPATION
105-1	CONSTRUCTION CONTROL MARKINGS
105-2	EQUIPMENT AND MATERIAL STORAGE ON BRIDGE STRUCTURES
107-1	WORKER VISIBILITY
108-1	LIQUIDATED DAMAGES
600-1	WATER FOR VEGETATION
603-1	MAINTENANCE OF TRAFFIC
604-1	RETROREFLECTIVE SHEETING FOR TRAFFIC CONTROL DEVICES IN CONSTRUCTION ZONES
711-1	CONCRETE PULL BOX
714-1	DESIGN AND MATERIAL REQUIREMENTS FOR TRAFFIC SIGNAL MAST ARMS AND POLES
715-1	DESIGN AND MATERIAL REQUIREMENTS FOR TRAFFIC SIGNAL PEDESTAL POLES
719-2	THERMOPLASTIC PAVEMENT MARKING MATERIAL
JOB 020520	CABINET DRAWER ASSEMBLY
JOB 020520	EDGE CARD VIDEO PROCESSOR
JOB 020520	ELECTRICAL CONDUCTORS FOR LUMINAIRES
JOB 020520	ELECTRICAL CONDUCTORS-IN-CONDUIT
JOB 020520	GOALS FOR DISADVANTAGED BUSINESS ENTERPRISE PARTICIPATION
JOB 020520	INTERNET BIDDING
JOB 020520	LED COUNTDOWN PEDESTRIAN SIGNAL HEAD
JOB 020520	LED TRAFFIC SIGNAL HEAD
JOB 020520	LUMINAIRE ASSEMBLY (CUTOFF TYPE)
JOB 020520	REMOVAL OF TRAFFIC SIGNAL EQUIPMENT
JOB 020520	SERVICE POINT ASSEMBLY
JOB 020520	STREET NAME SIGN (MAST ARM MOUNTED)
JOB 020520	UTILITY ADJUSTMENTS
JOB 020520	VIDEO DETECTOR (COLOR)

LOCATION: HWY. 133/3RD. AVE. & HWY. 133T/3RD. AVE.  
 CITY: CROSSETT  
 COUNTY: ASHLEY  
 DISTRICT: 2 SCALE: N/A DRAWN BY: GWE

DATE: 02-14-12 FILE NAME: t020520.job.dgn

DATE REVISED	DATE FILMED	DATE REVISED	DATE FILMED	FED. RD. DIST. NO.	STATE	FED. AID PROJ. NO.	SHEET NO.	TOTAL SHEETS
				6	ARK.			
				JOB NO.	020520		3	36

② GENERAL NOTES



2-3-12

GENERAL NOTES

1. GRADE LINE DENOTES FINISHED GRADE WHERE SHOWN ON PLANS.
2. ALL PIPE LINES, POWER, TELEPHONE AND TELEGRAPH LINES TO BE MOVED OR LOWERED BY THE RESPECTIVE OWNERS AS PER AGREEMENT WITH SUCH OWNERS.
3. ANY EQUIPMENT OR APPURTENANCE THAT INTERFERES WITH THE PROPOSED CONSTRUCTION AND WHICH MAY BE THE PROPERTY OF UTILITY SERVICE ORGANIZATIONS SHALL BE MOVED BY THE OWNERS UNLESS OTHERWISE PROVIDED.
4. THE CONTRACTOR SHALL BE RESPONSIBLE FOR MAINTAINING U. S. MAILBOXES WITHIN THE PROJECT LIMITS IN SUCH A MANNER THAT THE PUBLIC MAY RECEIVE CONTINUED MAIL SERVICE. PAYMENT WILL BE CONSIDERED INCLUDED IN THE PRICE BID FOR THE VARIOUS BID ITEMS.
5. ALL LAND MONUMENTS LOCATED WITHIN THE CONSTRUCTION AREA SHALL BE PROTECTED IN ACCORDANCE WITH SECTION 107.12 OF THE STANDARD SPECIFICATIONS.
6. ALL TREES THAT DO NOT DIRECTLY INTERFERE WITH THE PROPOSED CONSTRUCTION SHALL BE SPARED AS DIRECTED BY THE ENGINEER. CARE AND DISCRETION SHALL BE USED TO INSURE THAT ALL TREES NOT TO BE REMOVED SHALL BE HARMED AS LITTLE AS POSSIBLE DURING THE CONSTRUCTION OPERATIONS.
7. ALL FLEXIBLE BASE AND ASPHALTIC PAVEMENTS REMOVED SHALL BE PAID FOR UNDER THE ITEM NO 210-UNCLASSIFIED EXCAVATION.
8. UNLESS OTHERWISE INDICATED, ALL DIMENSIONS SHOWN ARE TO THE FACE OF CURB.
9. THIS PROJECT IS COVERED UNDER A NATIONWIDE 14 SECTION 404 PERMIT. REFER TO SECTION 110 OF THE STANDARD SPECIFICATIONS, EDITION OF 2003, FOR PERMIT REQUIREMENTS.

1020520\_job.dgn 02-14-2011

DATE: 01-09-12 FILE NAME: t020520\_job.dgn

LOCATION: HWY. 133/3RD. AVE. & HWY. 133T/3RD. AVE.  
 CITY: CROSSETT  
 COUNTY: ASHLEY  
 DISTRICT: 2 SCALE: N/A DRAWN BY: GWE

# EROSION CONTROL

STATION	STATION	LOCATION	PERMANENT EROSION CONTROL	
			SOLID SODDING	WATER
22+77.80	23+55.91	HWY. 133 ON LT. & RT.	SO. YD.	M. GAL.
			130	10.3
TOTALS			130	10.3

BASIS OF ESTIMATE:

WATER.....12.6 GAL./SQ.YD. OF SOLID SODDING

NOTE: THE TEMPORARY EROSION CONTROL DEVICES SHOWN ABOVE AND ON THE PLANS SHALL BE INSTALLED IN SUCH A SEQUENCE AS TO DETER EROSION AND SEDIMENTATION ON U.S. WATERWAYS AS EXPLAINED BY THE NATIONAL POLLUTANT DISCHARGE ELIMINATION SYSTEM PERMIT.

\*QUANTITIES ARE ESTIMATED. SEE SECTION 104.03 OF THE STD. SPECS.

(E-7) (DROP INLET SILT FENCE)

ESTIMATED AT 25 LIN. FT./DROP INLET.



QUANTITIES ARE ESTIMATED AND ARE TO BE USED IF AND WHERE DIRECTED BY THE ENGINEER.

TEMPORARY EROSION CONTROL GENERAL NOTES:


THE QUANTITIES AND LOCATIONS OF THE TEMPORARY EROSION CONTROL DEVICES SHOWN IN THE PLANS ARE ESTIMATED AND MAY BE ALTERED IF AND WHERE DIRECTED BY THE ENGINEER TO MAXIMIZE THEIR EFFECTIVENESS. THE DEVICES ARE TO BE INSTALLED IN AN AREA ONLY WHEN THE SOIL DISTURBING ACTIVITY IN THAT AREA BEGINS.

DATE REVISED	DATE FILMED	DATE REVISED	DATE FILMED	FED. RD. DIST. NO.	STATE	FED. AID PROJ. NO.	SHEET NO.	TOTAL SHEETS
				6	ARK.		4	36

2 TEMPORARY EROSION CONTROL DETAILS

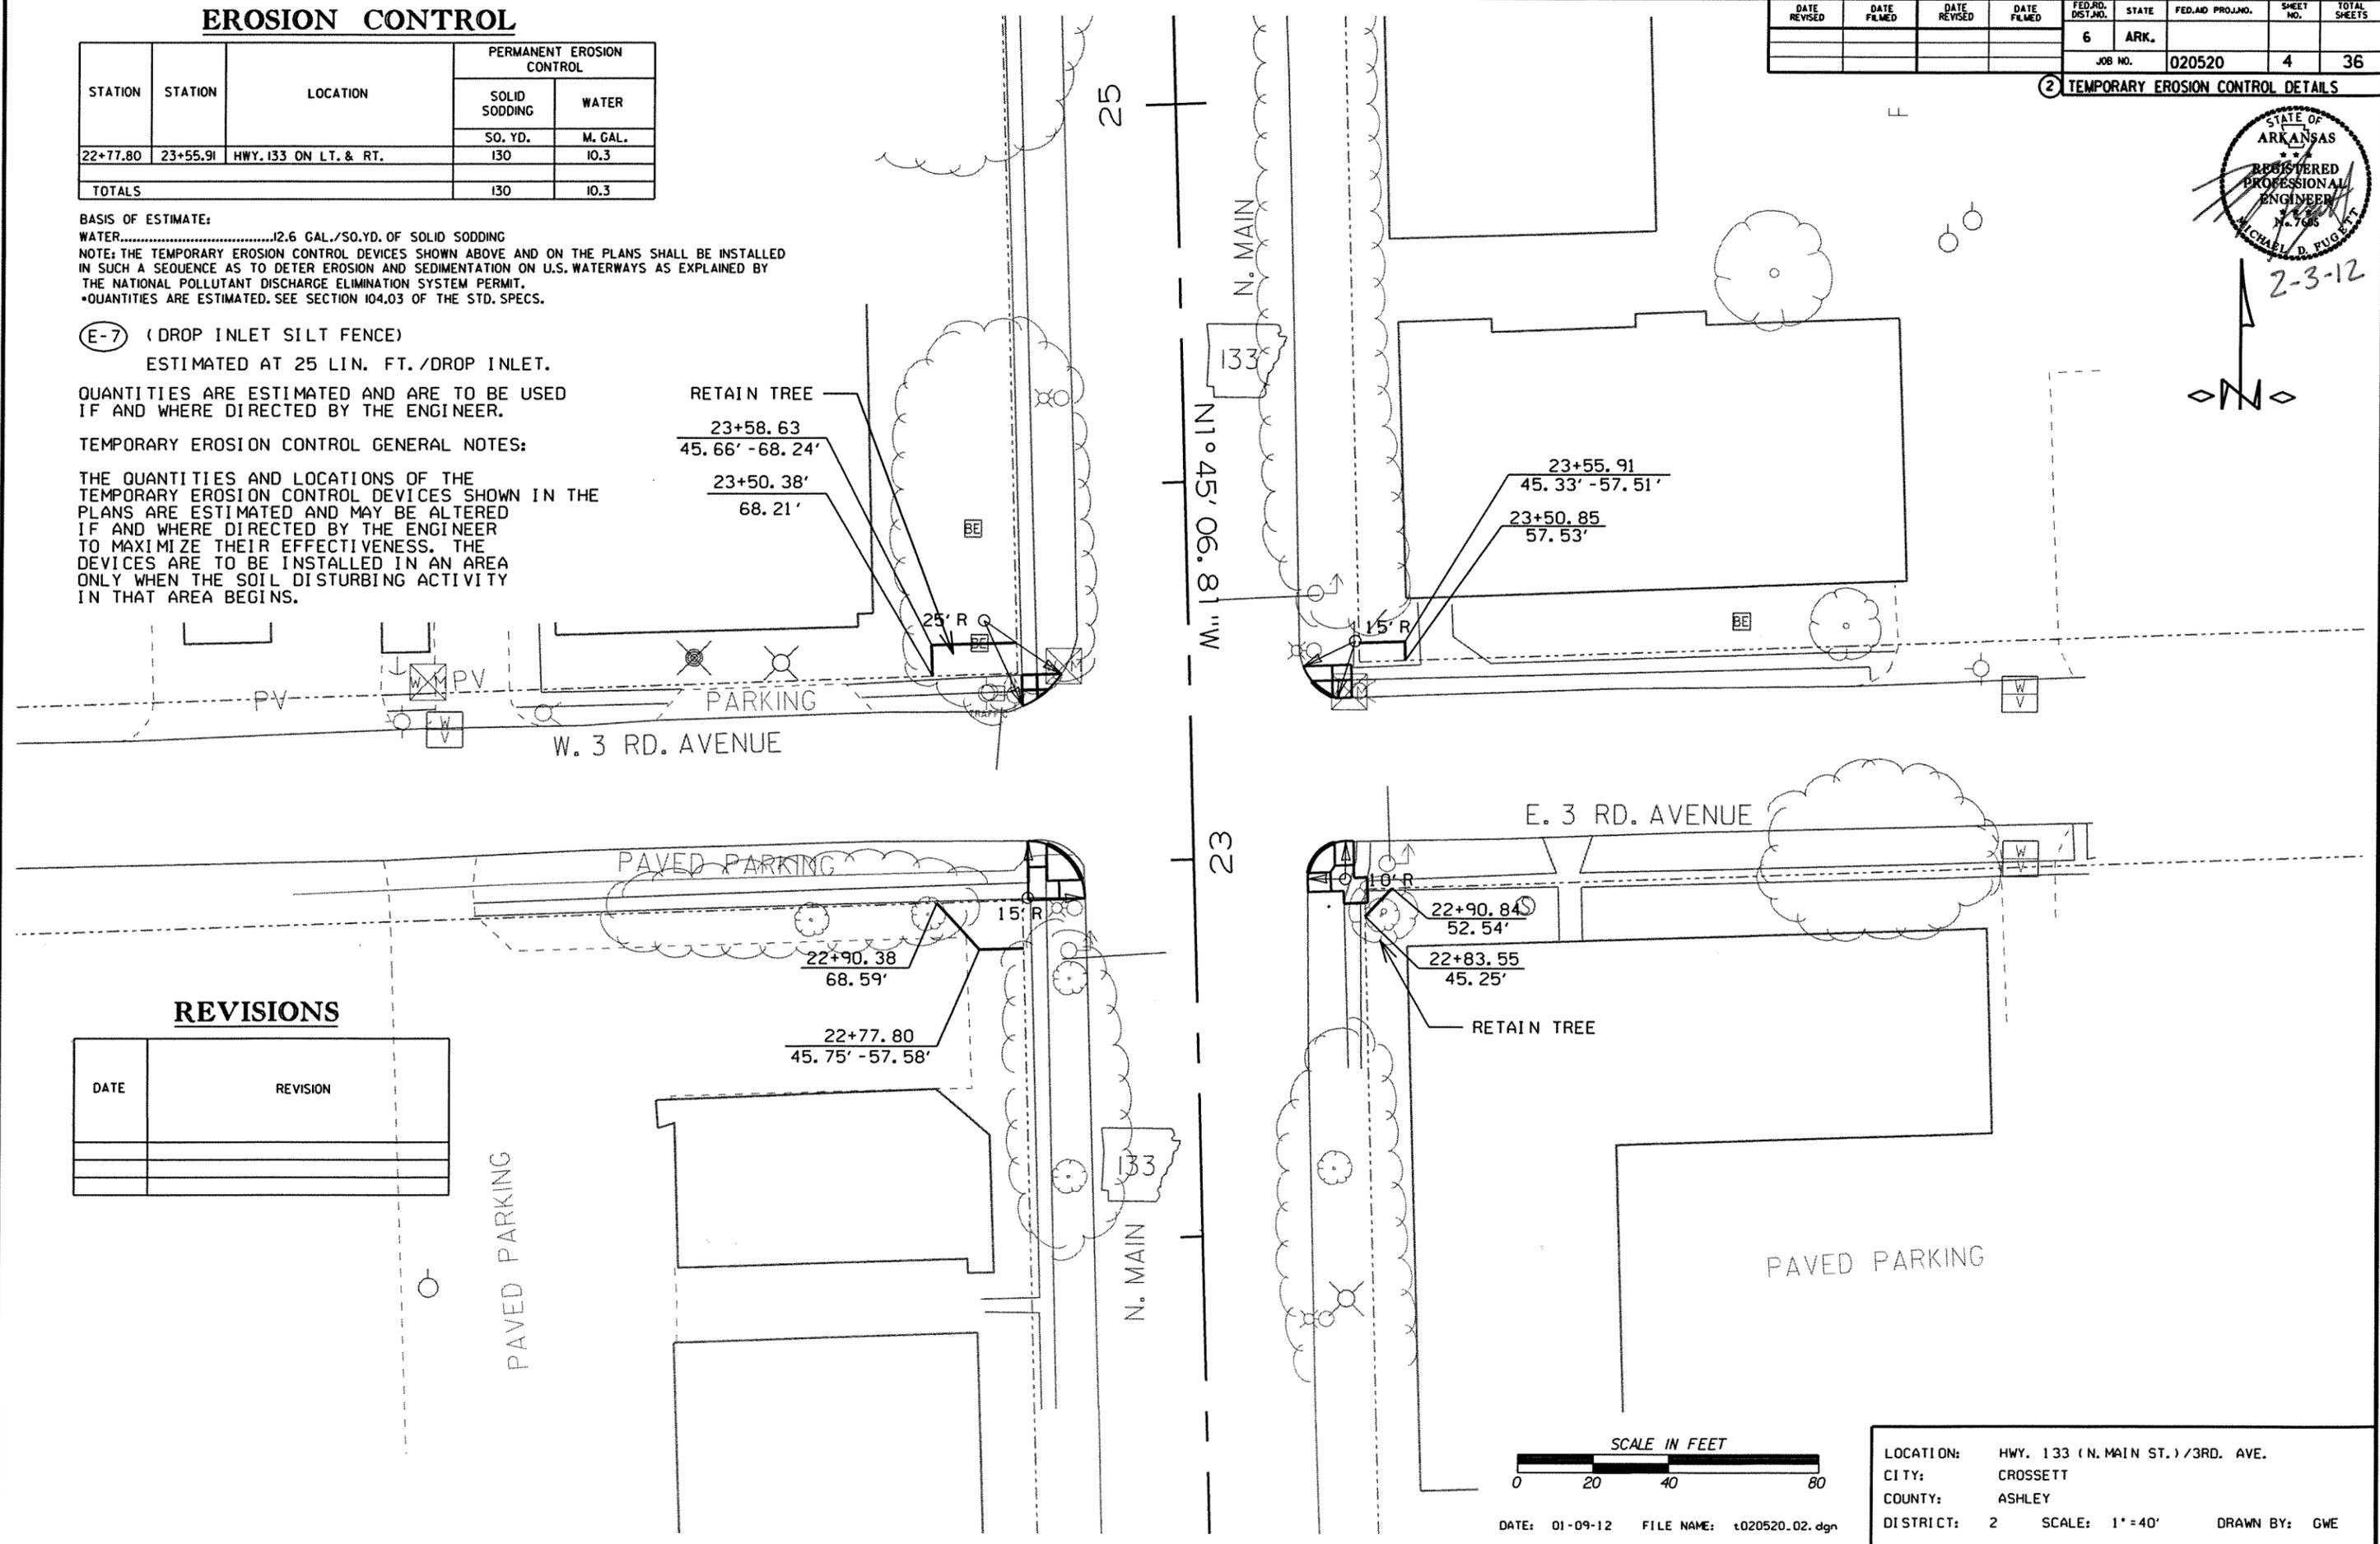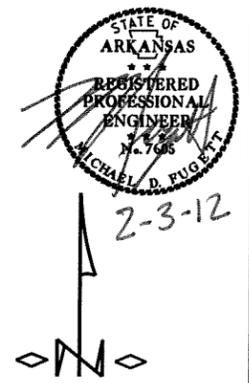

REVISIONS	
DATE	REVISION

 

LOCATION: HWY. 133 (N. MAIN ST.)/3RD. AVE.  
 CITY: CROSSETT  
 COUNTY: ASHLEY  
 DISTRICT: 2 SCALE: 1"=40' DRAWN BY: GWE

1020520\_02.dgn 02-14-2011

DATE: 01-09-12 FILE NAME: t020520.02.dgn

# EROSION CONTROL

STATION	STATION	LOCATION	PERMANENT EROSION CONTROL	
			SOLID SODDING	WATER
32+14.99	33+23.48	HWY. 133T ON LT. & RT.	281	22.3
TOTALS			281	22.3

BASIS OF ESTIMATE:  
 WATER.....12.6 GAL./SQ.YD. OF SOLID SODDING  
 NOTE: THE TEMPORARY EROSION CONTROL DEVICES SHOWN ABOVE AND ON THE PLANS SHALL BE INSTALLED IN SUCH A SEQUENCE AS TO DETER EROSION AND SEDIMENTATION ON U.S. WATERWAYS AS EXPLAINED BY THE NATIONAL POLLUTANT DISCHARGE ELIMINATION SYSTEM PERMIT.  
 \*QUANTITIES ARE ESTIMATED. SEE SECTION 104.03 OF THE STD. SPECS.

(E-7) (DROP INLET SILT FENCE)  
 ESTIMATED AT 25 LIN. FT./DROP INLET.  
 QUANTITIES ARE ESTIMATED AND ARE TO BE USED IF AND WHERE DIRECTED BY THE ENGINEER.


TEMPORARY EROSION CONTROL GENERAL NOTES:  
 THE QUANTITIES AND LOCATIONS OF THE TEMPORARY EROSION CONTROL DEVICES SHOWN IN THE PLANS ARE ESTIMATED AND MAY BE ALTERED IF AND WHERE DIRECTED BY THE ENGINEER TO MAXIMIZE THEIR EFFECTIVENESS. THE DEVICES ARE TO BE INSTALLED IN AN AREA ONLY WHEN THE SOIL DISTURBING ACTIVITY IN THAT AREA BEGINS.

DATE REVISED	DATE FILMED	DATE REVISED	DATE FILMED	FED. RD. DIST. NO.	STATE	FED. AID PROJ. NO.	SHEET NO.	TOTAL SHEETS
				6	ARK.		5	36

## TEMPORARY EROSION CONTROL DETAILS




2-3-12

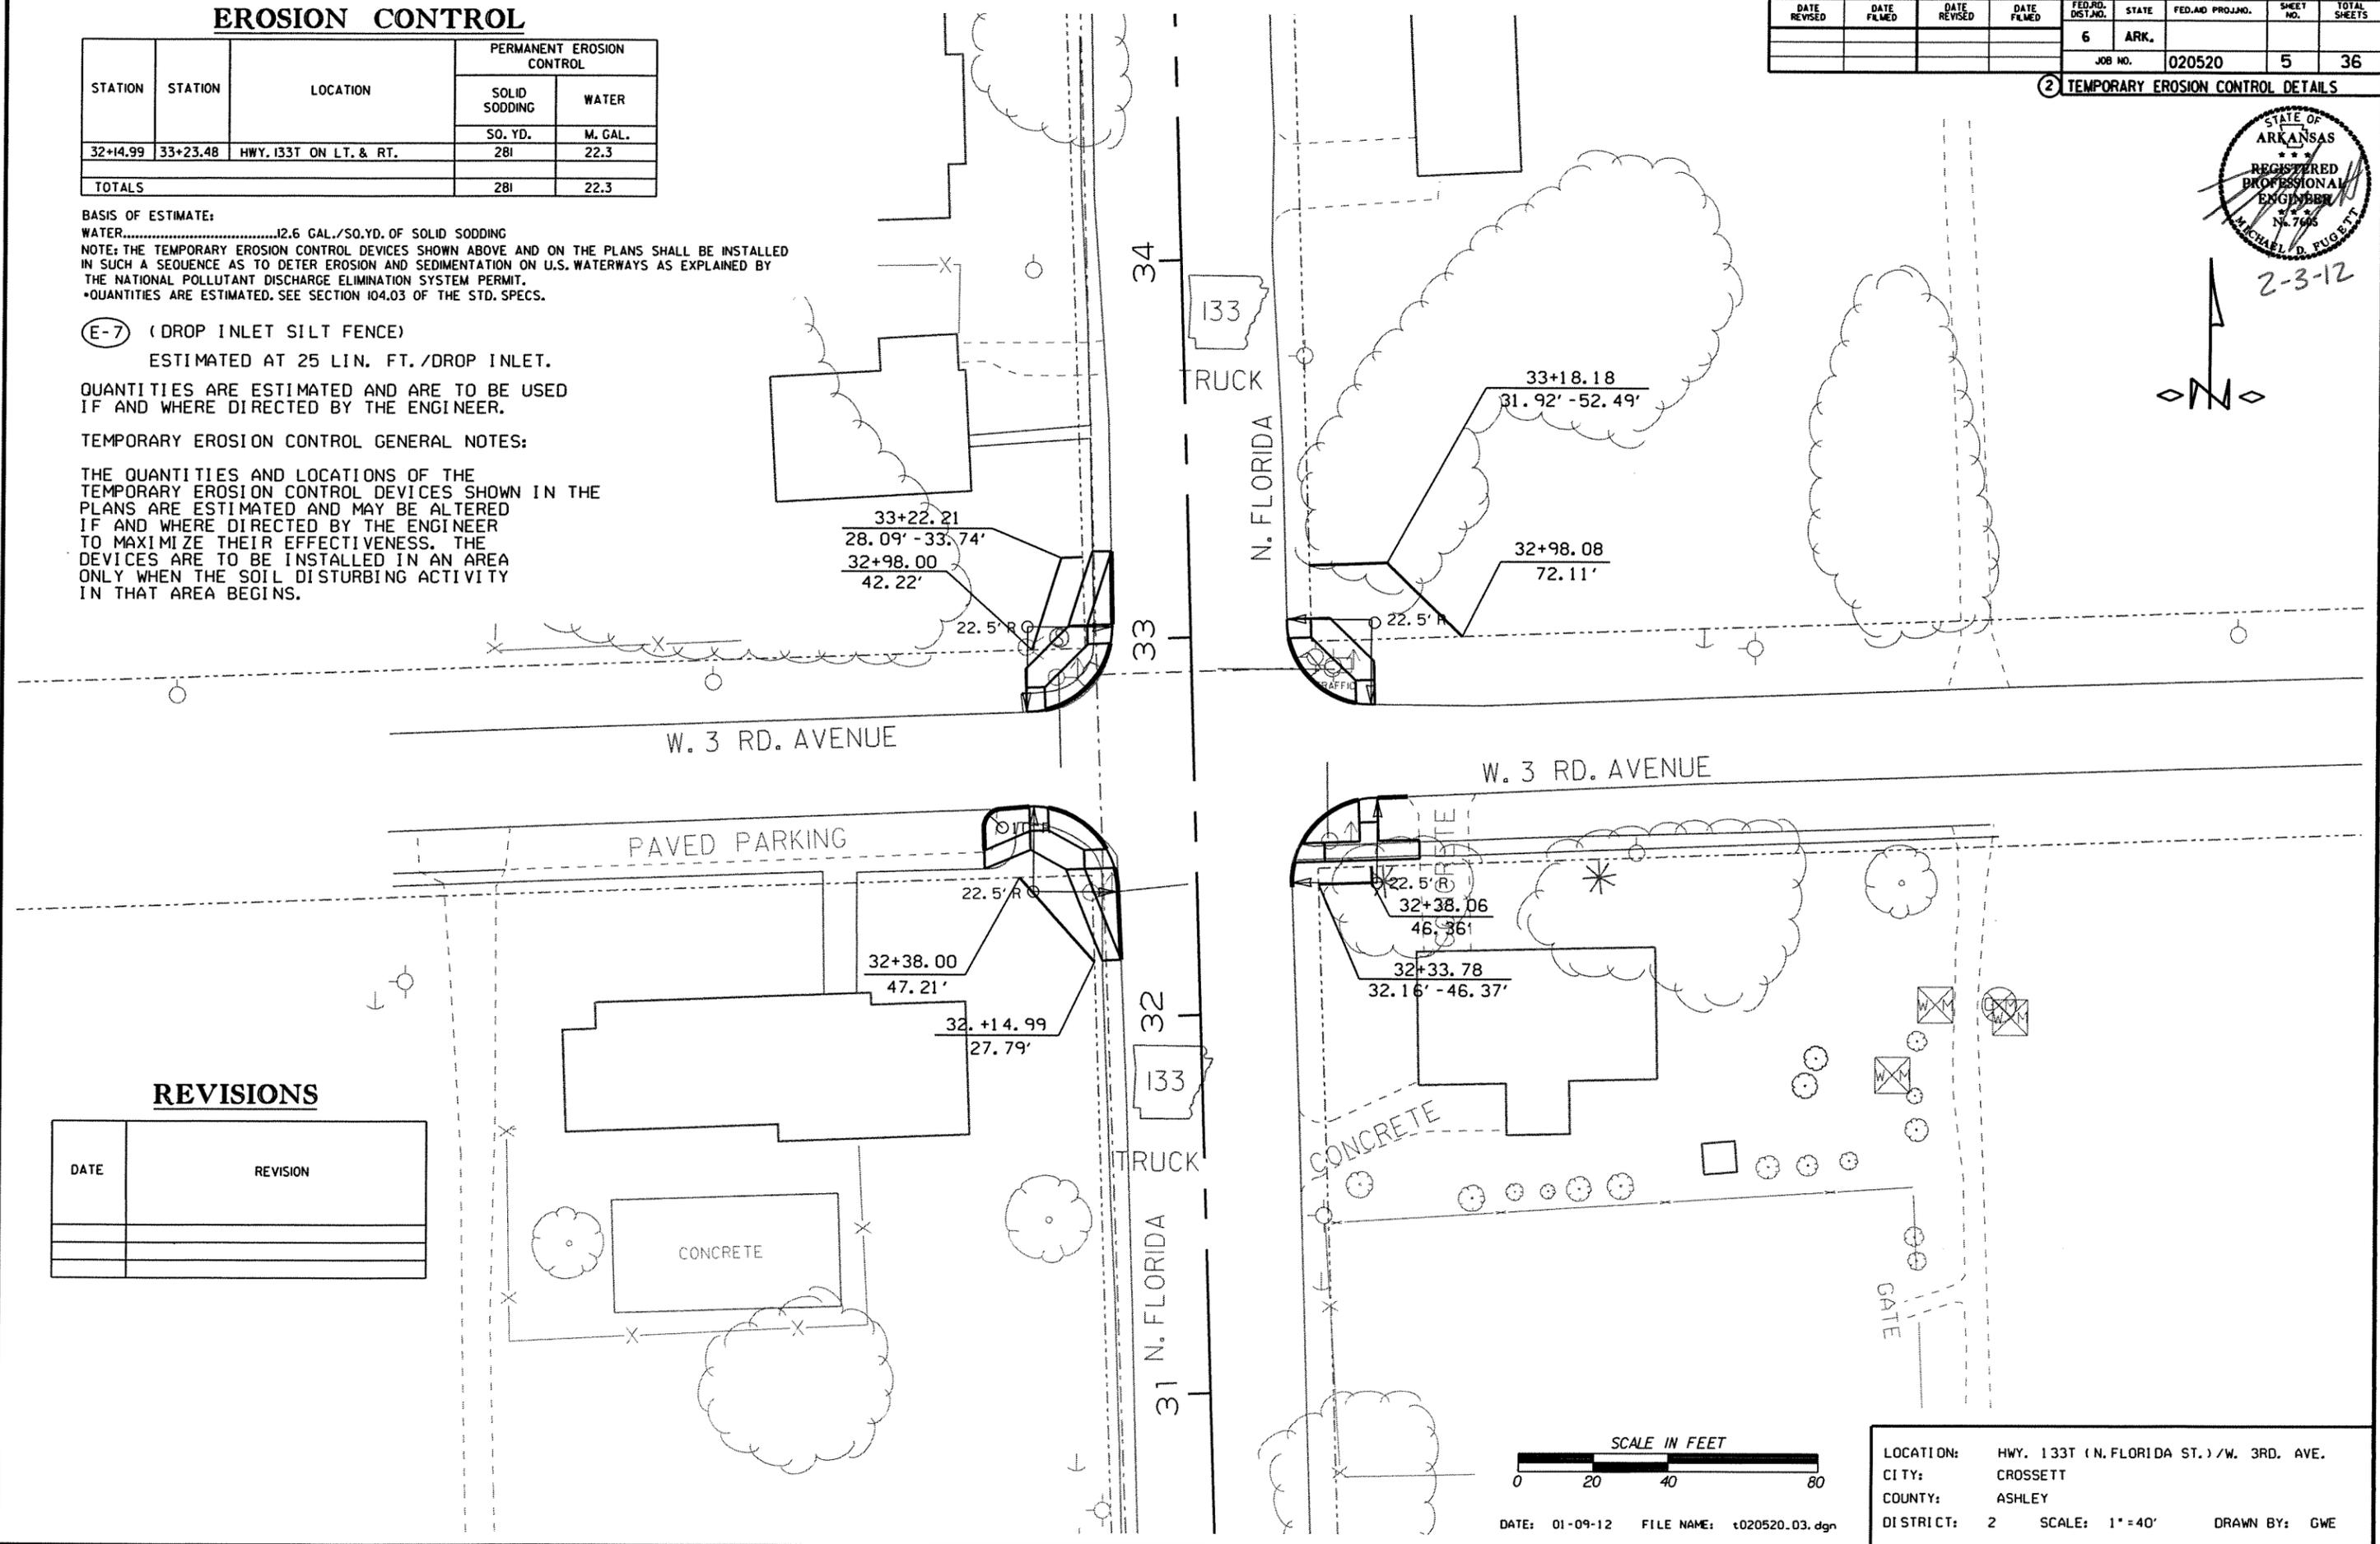

### REVISIONS

 DATE	REVISION




DATE: 01-09-12 FILE NAME: t020520.03.dgn

LOCATION: HWY. 133T (N. FLORIDA ST.) / W. 3RD. AVE.  
 CITY: CROSSETT  
 COUNTY: ASHLEY  
 DISTRICT: 2 SCALE: 1" = 40' DRAWN BY: GWE

1020520\_03.dgn 02-14-2011

DATE REVISED	DATE FILMED	DATE REVISED	DATE FILMED	FED. RD. DIST. NO.	STATE	FED. AID PROJ. NO.	SHEET NO.	TOTAL SHEETS
				6	ARK.			
				JOB NO.	020520		6	36

② INTER. IMPVT. DETAILS

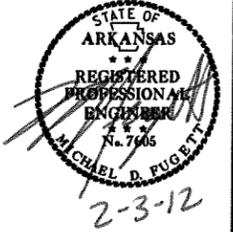



**CONCRETE ITEMS**

STATION	STATION	LOCATION	SIDE	CONCRETE COMBINATION CURB AND GUTTER (TYPE A) (1' 6")	CONCRETE WALKS	CONCRETE ISLAND CURB FACE A	WHEELCHAIR RAMPS (TYPE 3)
				LIN. FT.	SO. YD.	SO. YD.	SO. YD.
22+90.51	23+03.29	HWY. 133	ON RT.	12	8	4	6
22+90.72	23+06.17	HWY. 133	ON LT.	14	7	6	6
23+41.49	23+50.16	HWY. 133	ON RT.	7	2	1	4
23+41.73	23+50.04	HWY. 133	ON LT.	3	2	1	6
TOTALS				36	19	12	22

**EARTHWORK**

STATION	STATION	LOCATION/DESCRIPTION	UNCLASSIFIED EXCAVATION	COMPACTED EMBANKMENT
			CU. YD.	CU. YD.
22+90.51	23+03.29	HWY. 133 ON RT.	15	15
22+90.72	23+06.17	HWY. 133 ON LT.	16	16
23+41.49	23+50.16	HWY. 133 ON RT.	10	10
23+41.73	23+50.04	HWY. 133 ON LT.	10	10
TOTALS			51	51

NOTE: EARTHWORK QUANTITIES SHOWN SHALL BE PAID AS PLAN QUANTITY.

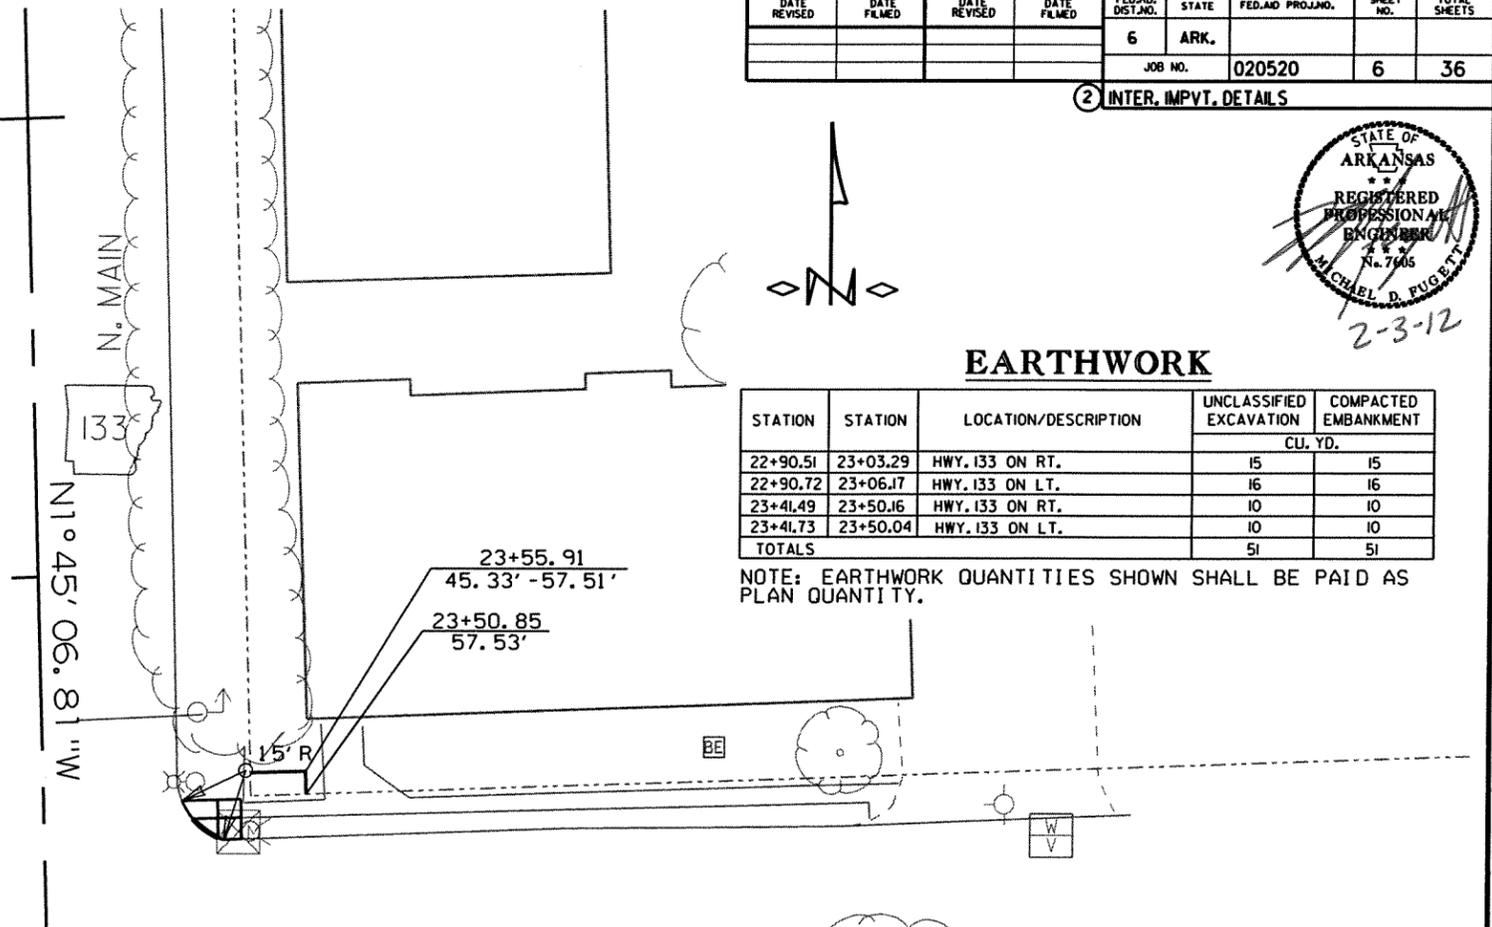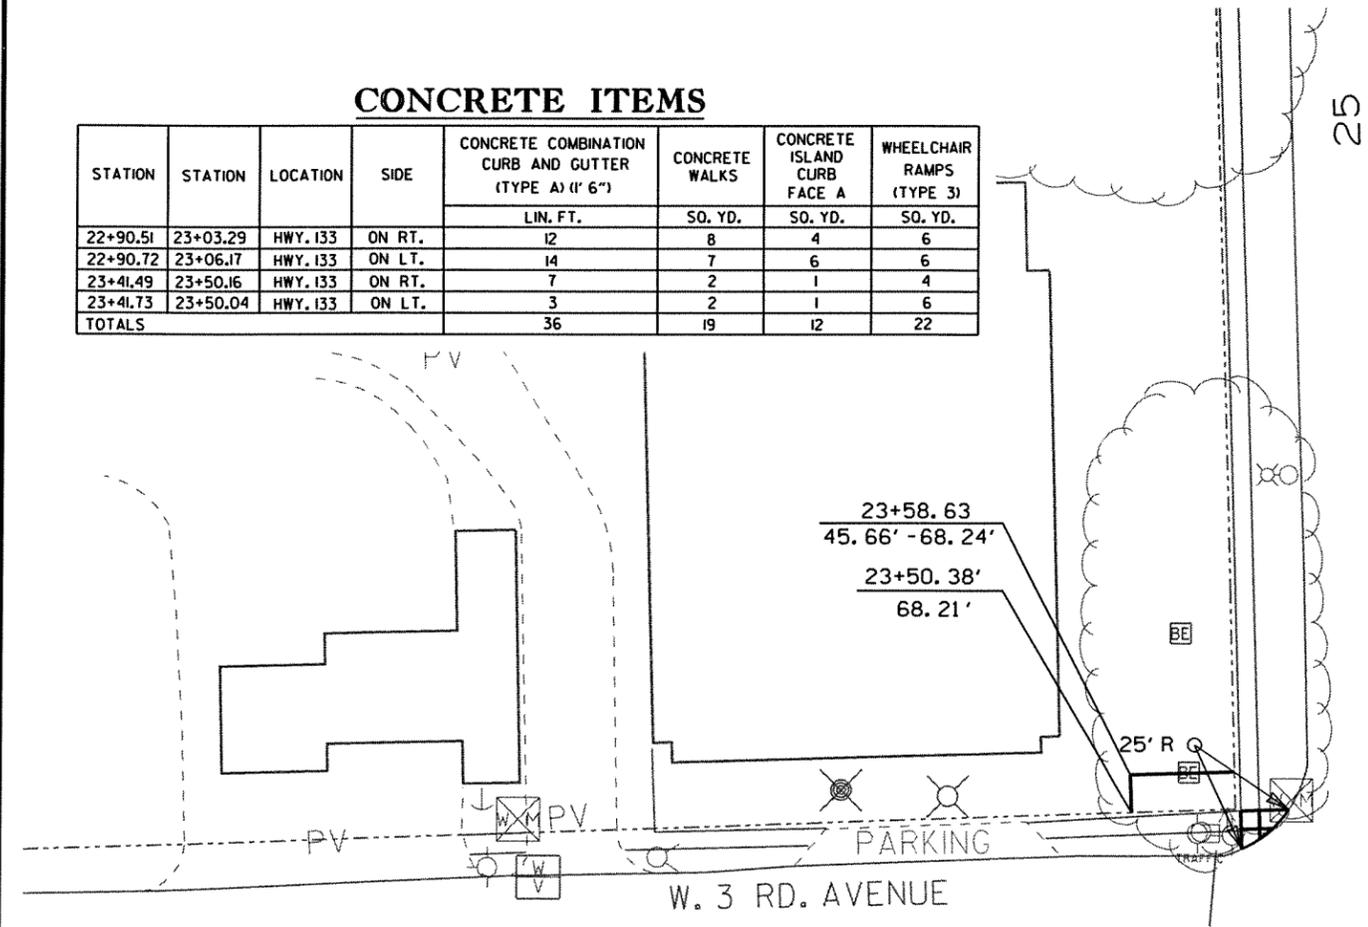


**PORTLAND CEMENT CONCRETE BASE**

STATION	STATION	DESCRIPTION	PORTLAND CEMENT CONCRETE BASE (12" U.T.)	
			WIDTH	SO. YD.
22+90.51	23+03.29	HWY. 133 ON RT.	VARIABLE	1
22+90.72	23+06.17	HWY. 133 ON LT.	VARIABLE	3
23+41.49	23+50.16	HWY. 133 ON RT.	VARIABLE	1
23+41.73	23+50.04	HWY. 133 ON LT.	VARIABLE	1
TOTAL				6

**REMOVAL AND DISPOSAL ITEMS**

STATION	STATION	DESCRIPTION	CURB AND GUTTER	WALKS	CONCRETE ISLANDS	LUMINAIRE POLE AND FOUNDATION	SIGNS	SPRINKLER SYSTEM	CONDUIT	JUNCTION BOXES
			LIN. FT.	SO. YD.	SO. YD.	EACH	EACH	EACH	LIN. FT.	EACH
22+90.51	23+03.29	HWY. 133 ON RT.	22	8						
22+78.00	23+06.17	HWY. 133 ON LT.	26	6		1	1			
23+41.49	23+50.16	HWY. 133 ON RT.	18	8	2	1			10	1
23+41.73	23+60.00	HWY. 133 ON LT.	14	6	1				10	1
TOTALS			80	28	3	2	1	1	10	1

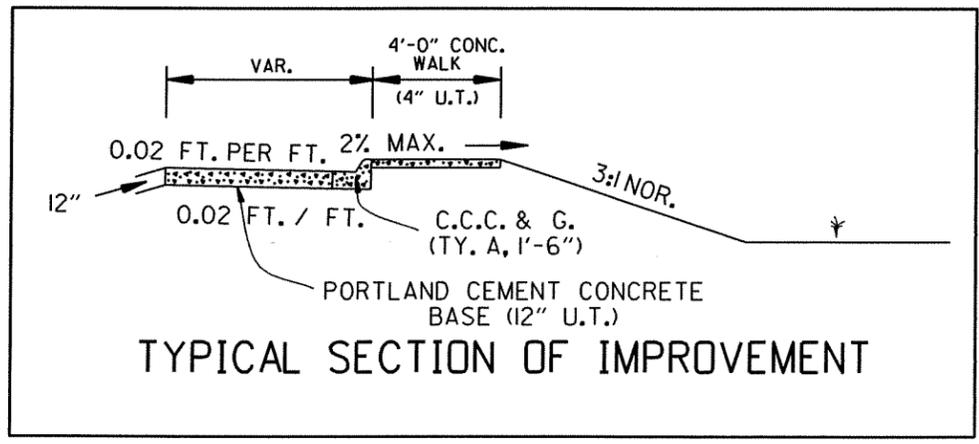

LOCATION: HWY. 133 (N. MAIN ST.) / 3RD. AVE.  
 CITY: CROSSETT  
 COUNTY: ASHLEY  
 DISTRICT: 2 SCALE: 1" = 40' DRAWN BY: GWE

ZBORNER.CEL 8/30/2010

DATE: 01-31-12 FILE NAME: t020520.02.dgn

DATE REVISED	DATE FILMED	DATE REVISED	DATE FILMED	FED. DIST. NO.	STATE	FED. AID PROJ. NO.	SHEET NO.	TOTAL SHEETS
				6	ARK.			
JOB NO. 020520							7	36

② INTER. IMPVT. DETAILS

### CONCRETE ITEMS


STATION	STATION	LOCATION	SIDE	CONCRETE COMBINATION CURB AND GUTTER (TYPE A) (1' 6")		WHEELCHAIR RAMPS (TYPE 3)
				LIN. FT.	SO. YD.	
32+15.35	32+56.64	HWY. I33T	ON LT.	80	31	6
32+33.25	32+56.24	HWY. I33T	ON RT.	35	17	8
32+81.64	33+23.48	HWY. I33T	ON LT.	46	27	6
32+80.82	33+04.06	HWY. I33T	ON RT.	21	16	8
TOTALS				182	91	28



### EARTHWORK

STATION	STATION	LOCATION/DESCRIPTION	UNCLASSIFIED EXCAVATION	COMPACTED EMBANKMENT
			CU. YD.	
32+15.35	32+56.64	HWY. I33T ON LT.	35	35
32+33.25	32+56.24	HWY. I33T ON RT.	23	23
32+81.64	33+23.48	HWY. I33T ON LT.	27	27
32+80.82	33+04.06	HWY. I33T ON RT.	54	54
TOTALS			139	139

NOTE: EARTHWORK QUANTITIES SHOWN SHALL BE PAID AS PLAN QUANTITY.

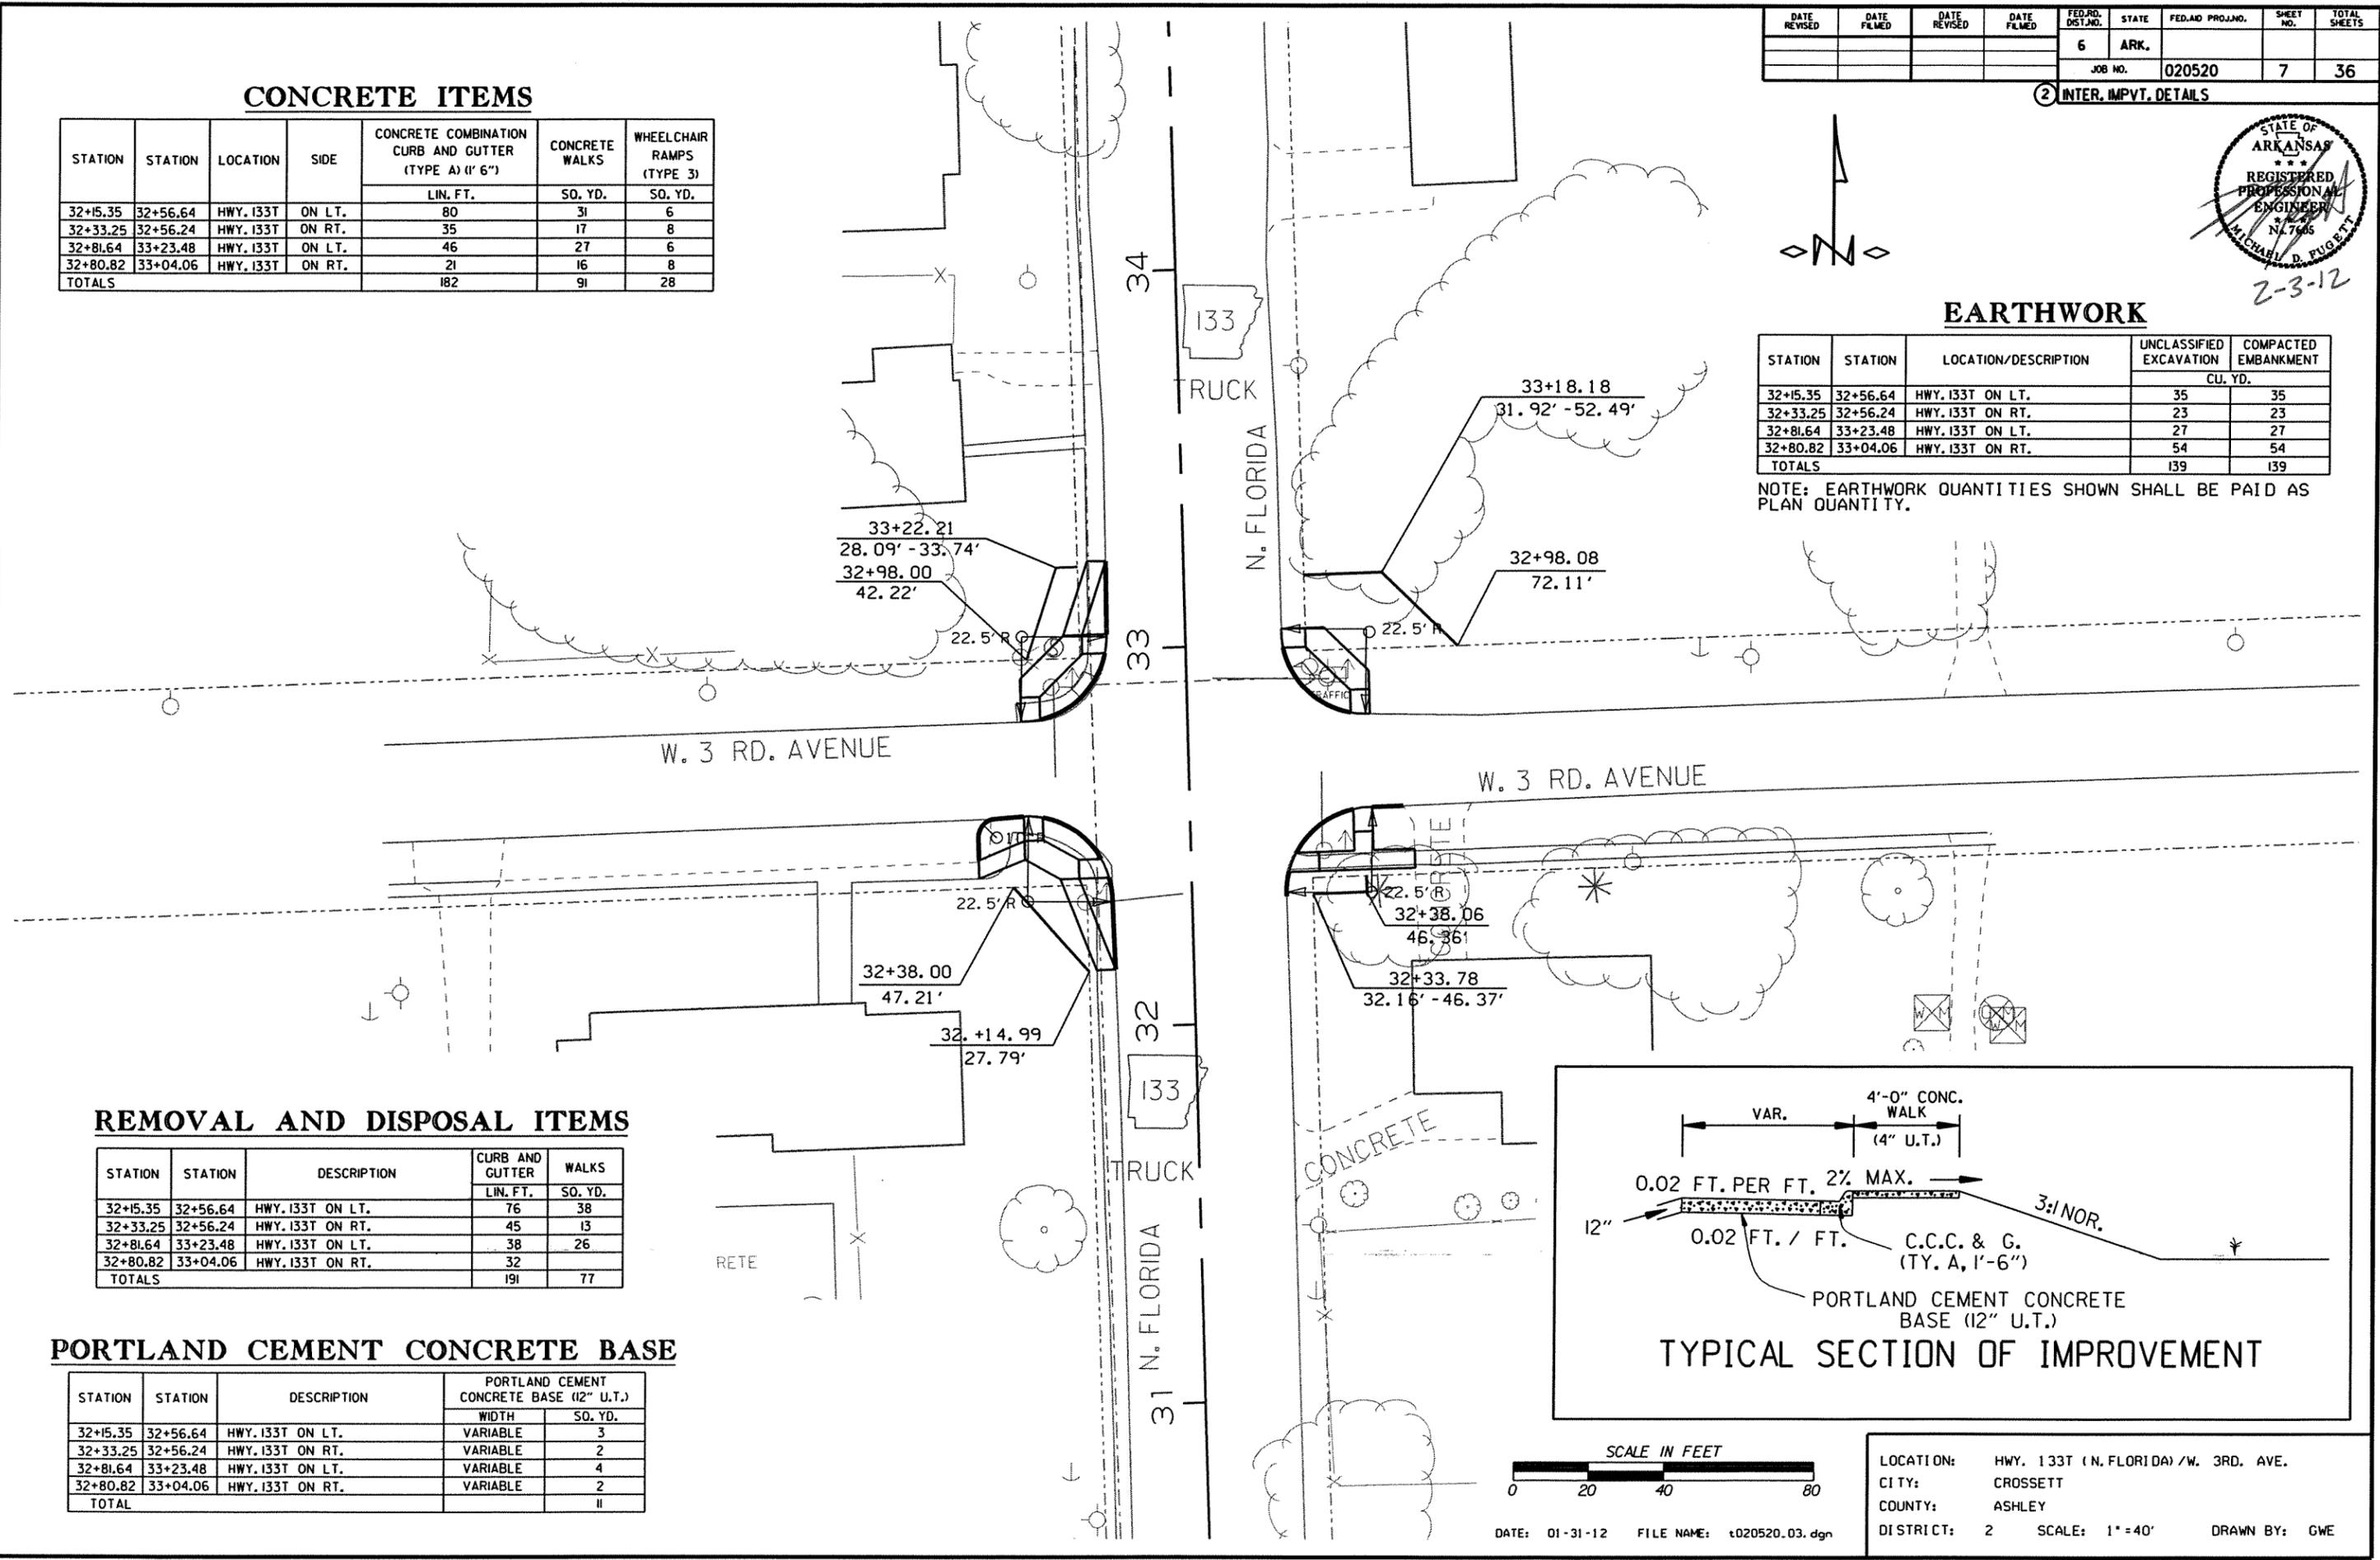


### REMOVAL AND DISPOSAL ITEMS

STATION	STATION	DESCRIPTION	CURB AND GUTTER		WALKS
			LIN. FT.	SO. YD.	
32+15.35	32+56.64	HWY. I33T ON LT.	76	38	
32+33.25	32+56.24	HWY. I33T ON RT.	45	13	
32+81.64	33+23.48	HWY. I33T ON LT.	38	26	
32+80.82	33+04.06	HWY. I33T ON RT.	32		
TOTALS			191	77	

### PORTLAND CEMENT CONCRETE BASE

 STATION	STATION	DESCRIPTION	PORTLAND CEMENT CONCRETE BASE (12" U.T.)	
			WIDTH	SO. YD.
32+15.35	32+56.64	HWY. I33T ON LT.	VARIABLE	3
32+33.25	32+56.24	HWY. I33T ON RT.	VARIABLE	2
32+81.64	33+23.48	HWY. I33T ON LT.	VARIABLE	4
32+80.82	33+04.06	HWY. I33T ON RT.	VARIABLE	2
TOTAL				11



DATE: 01-31-12 FILE NAME: t020520.03.dgn


LOCATION: HWY. I33T (N. FLORIDA) / W. 3RD. AVE.  
 CITY: CROSSETT  
 COUNTY: ASHLEY  
 DISTRICT: 2 SCALE: 1" = 40' DRAWN BY: GWE

# MAINTENANCE OF TRAFFIC

ITEM NO.	ITEM	QUANTITY	UNIT
SS&604	TRAFFIC DRUMS	16	EACH
SS&604	SIGNS	96	SQ. FT.
604	REMOVAL OF PERMANENT PAVEMENT MARKINGS	400	LIN. FT.


DATE REVISED	DATE FILMED	DATE REVISED	DATE FILMED	FED. RD. DIST. NO.	STATE	FED. AID PROJ. NO.	SHEET NO.	TOTAL SHEETS
				6	ARK.		8	36

② MAINT. OF TRAFFIC DETAILS

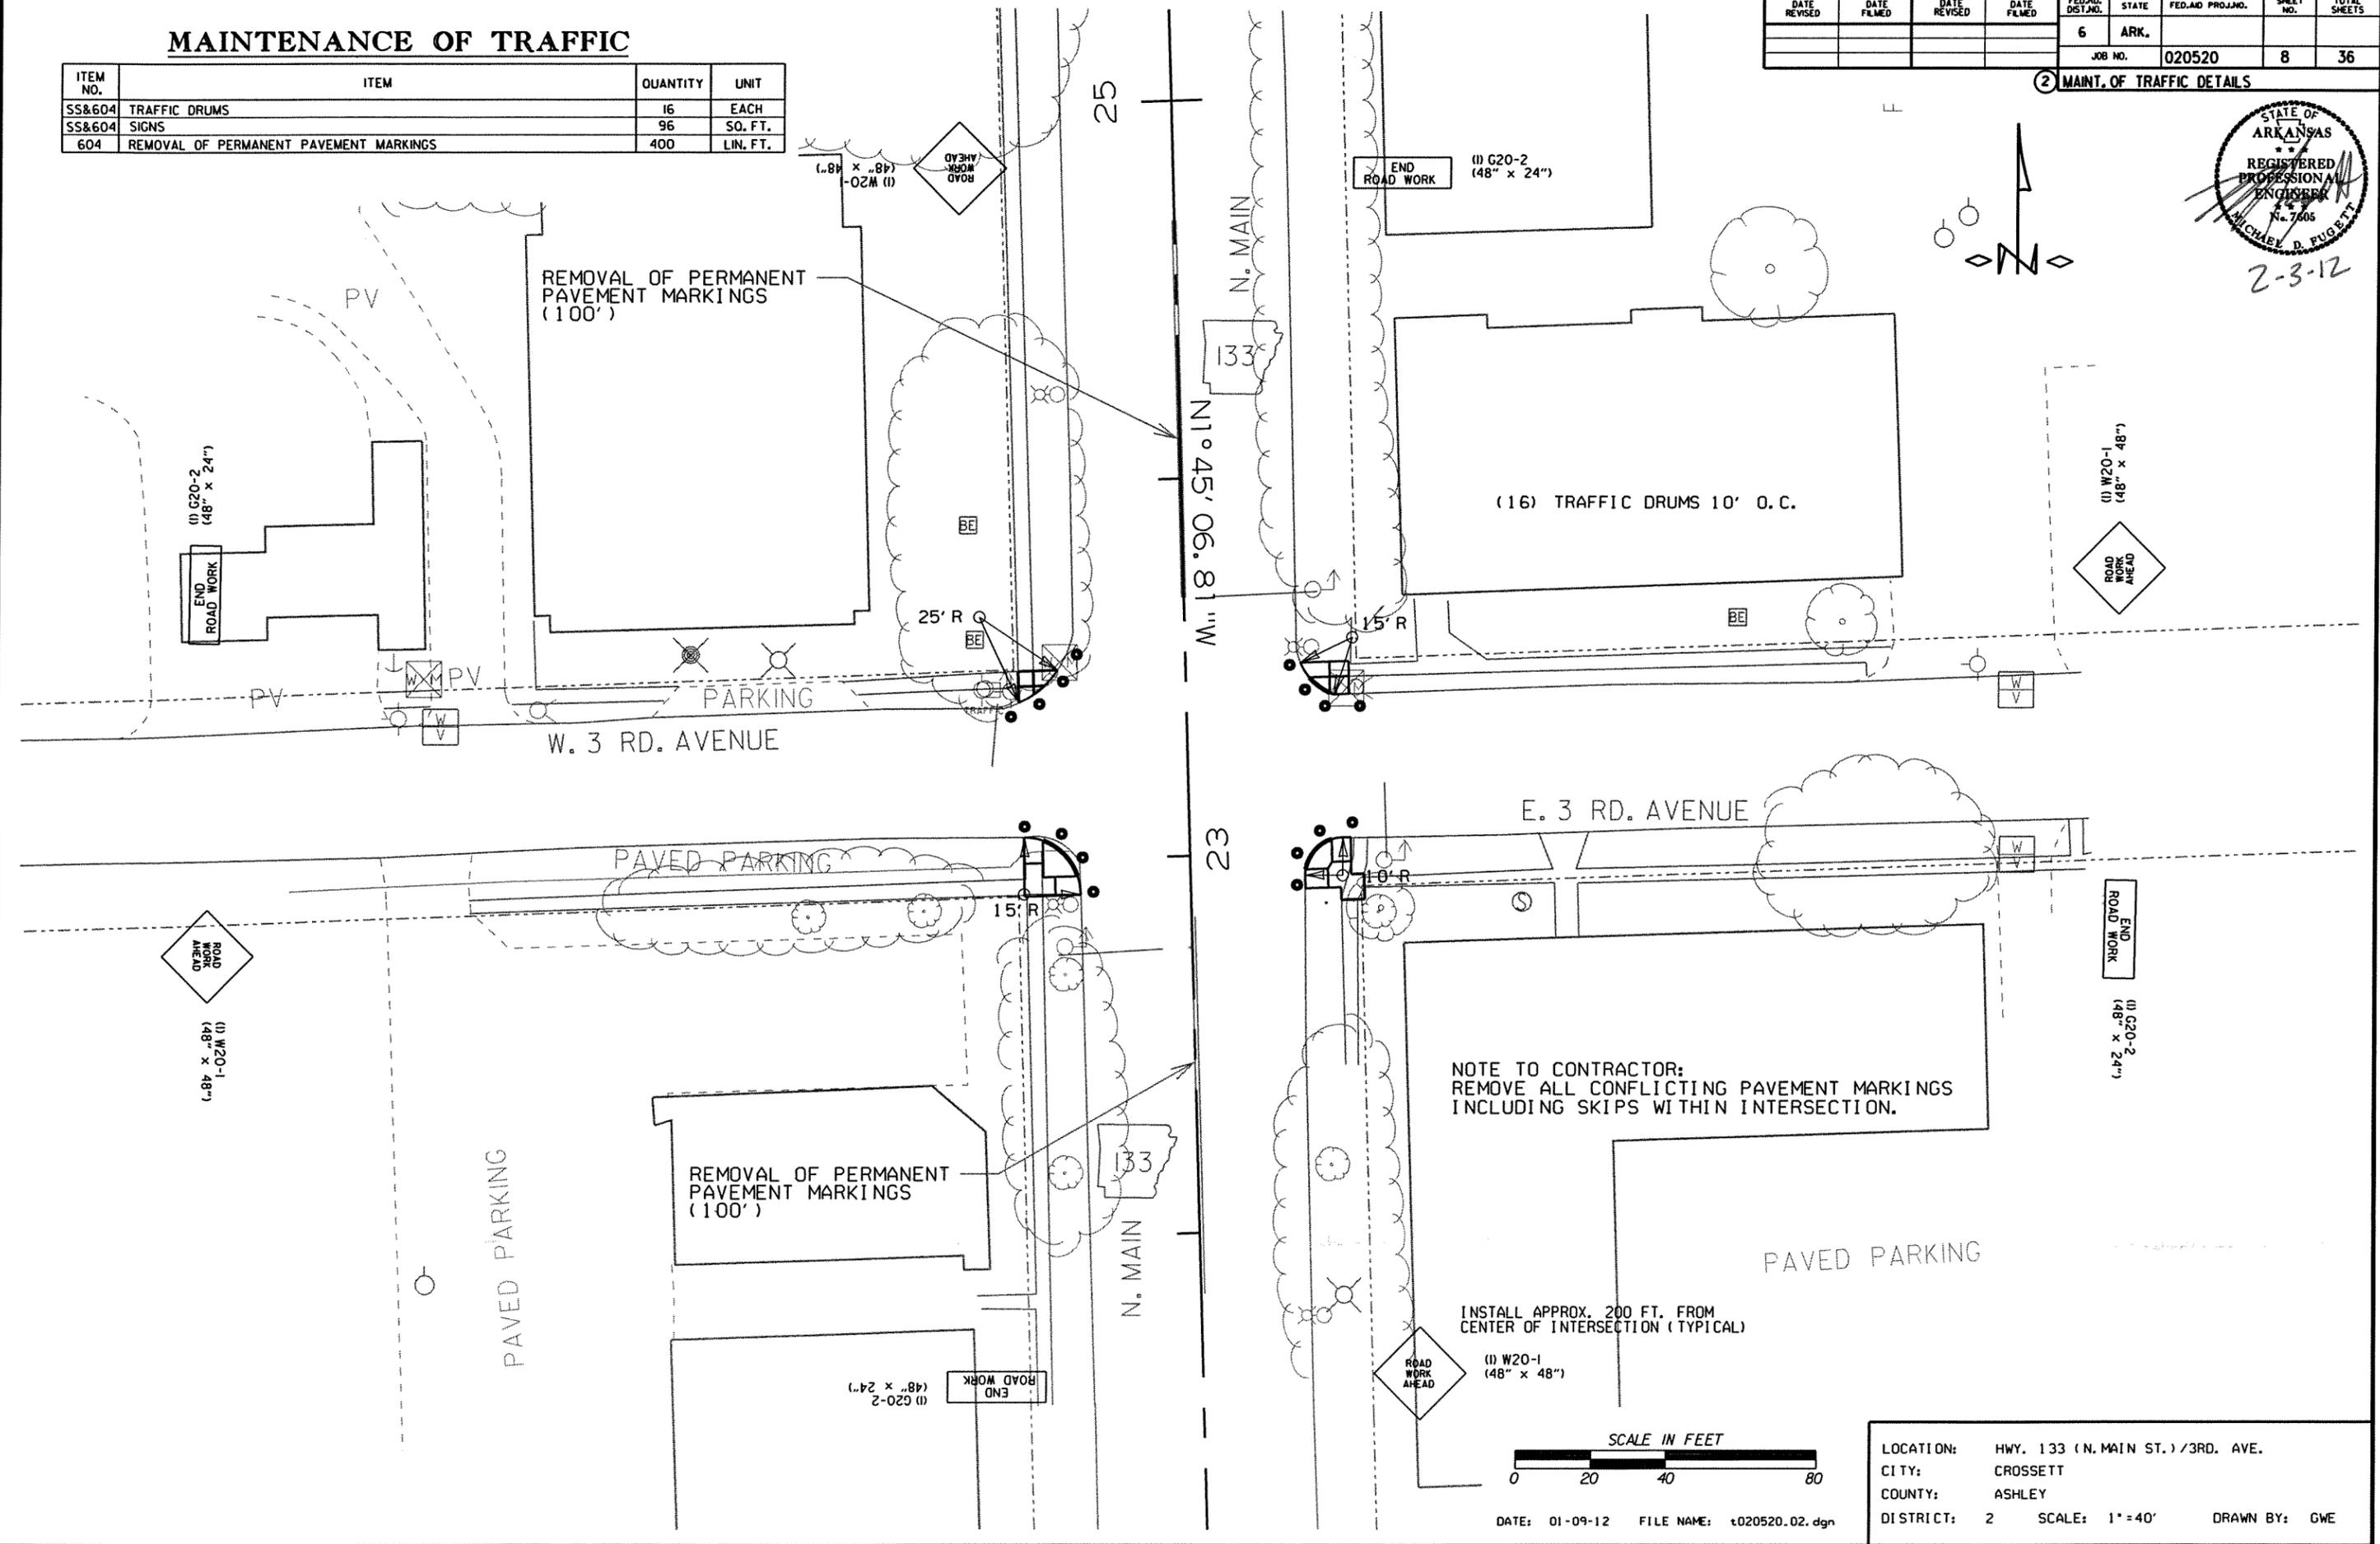

NOTE TO CONTRACTOR:  
REMOVE ALL CONFLICTING PAVEMENT MARKINGS INCLUDING SKIPS WITHIN INTERSECTION.

 INSTALL APPROX. 200 FT. FROM CENTER OF INTERSECTION (TYPICAL)



DATE: 01-09-12 FILE NAME: t020520.02.dgn

LOCATION:	HWY. 133 (N. MAIN ST.) / 3RD. AVE.
CITY:	CROSSETT
COUNTY:	ASHLEY
DISTRICT:	2
SCALE:	1" = 40'
DRAWN BY:	GWE

1020520\_02.dgn 02-14-2011



# MAINTENANCE OF TRAFFIC

 ITEM NO.	ITEM	QUANTITY	UNIT
SS&604	TRAFFIC DRUMS	20	EACH
SS&604	SIGNS	96	SO. FT.
604	REMOVAL OF PERMANENT PAVEMENT MARKINGS	400	LIN. FT.

NOTE TO CONTRACTOR:  
REMOVE ALL CONFLICTING PAVEMENT MARKINGS INCLUDING SKIPS WITHIN INTERSECTION.

DATE REVISED	DATE FILMED	DATE REVISED	DATE FILMED	FED. RD. DIST. NO.	STATE	FED. AID PROJ. NO.	SHEET NO.	TOTAL SHEETS
				6	ARK.		9	36
JOB NO.						020520		

② MAINT. OF TRAFFIC DETAILS

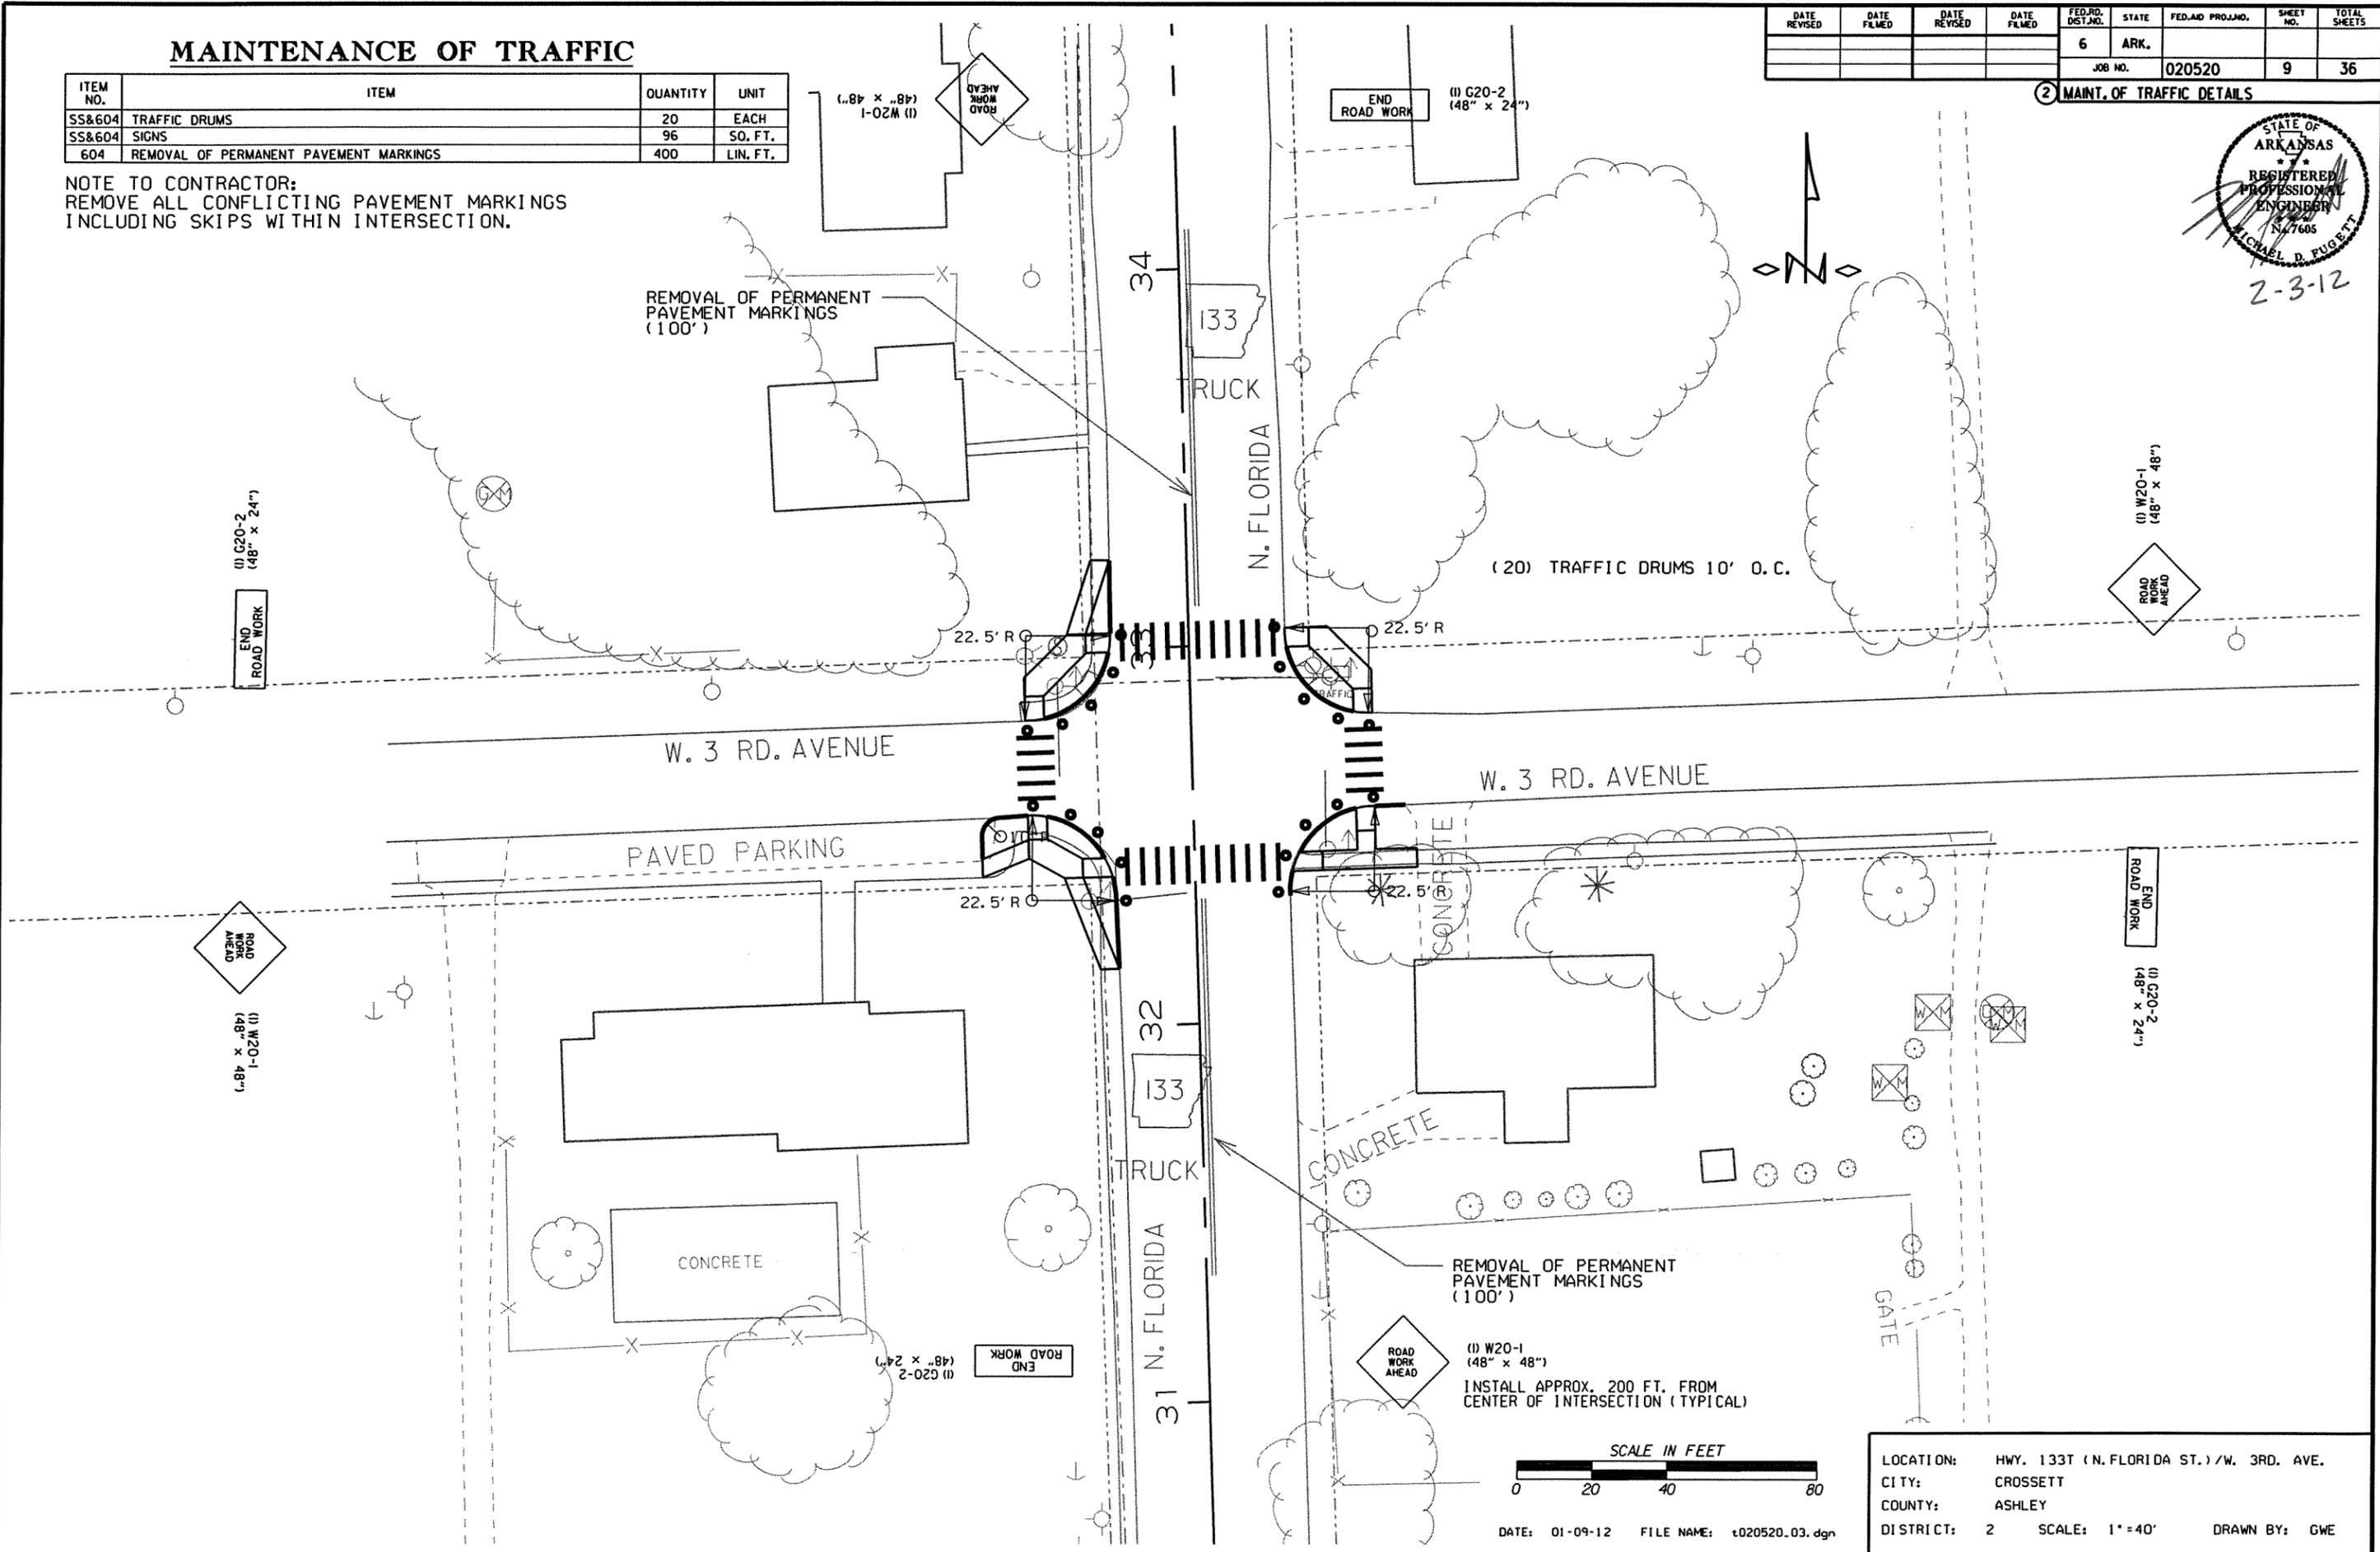

DATE: 01-09-12 FILE NAME: t020520.03.dgn

LOCATION: HWY. 133T (N. FLORIDA ST.) / W. 3RD. AVE.  
 CITY: CROSSETT  
 COUNTY: ASHLEY  
 DISTRICT: 2 SCALE: 1" = 40' DRAWN BY: GWE


1020520\_03.dgn 02-14-2011

# PERMANENT PAVEMENT MARKINGS


DATE REVISED	DATE FILMED	DATE REVISED	DATE FILMED	FED. RD. DIST. NO.	STATE	FED. AID PROJ. NO.	SHEET NO.	TOTAL SHEETS
				6	ARK.			
				JOB NO.	020520		10	36

② PERMANENT PAVEMENT MARKING DETAILS

ITEM NO.	ITEM	QUANTITY	UNIT
SS&719	THERMOPLASTIC PAVEMENT MARKING WHITE (4")	120	LIN. FT.
SS&719	THERMOPLASTIC PAVEMENT MARKING WHITE (12")	579	LIN. FT.
SS&719	THERMOPLASTIC PAVEMENT MARKING YELLOW (4")	800	LIN. FT.
721	RAISED PAVEMENT MARKERS (TYPE II)	20	EACH

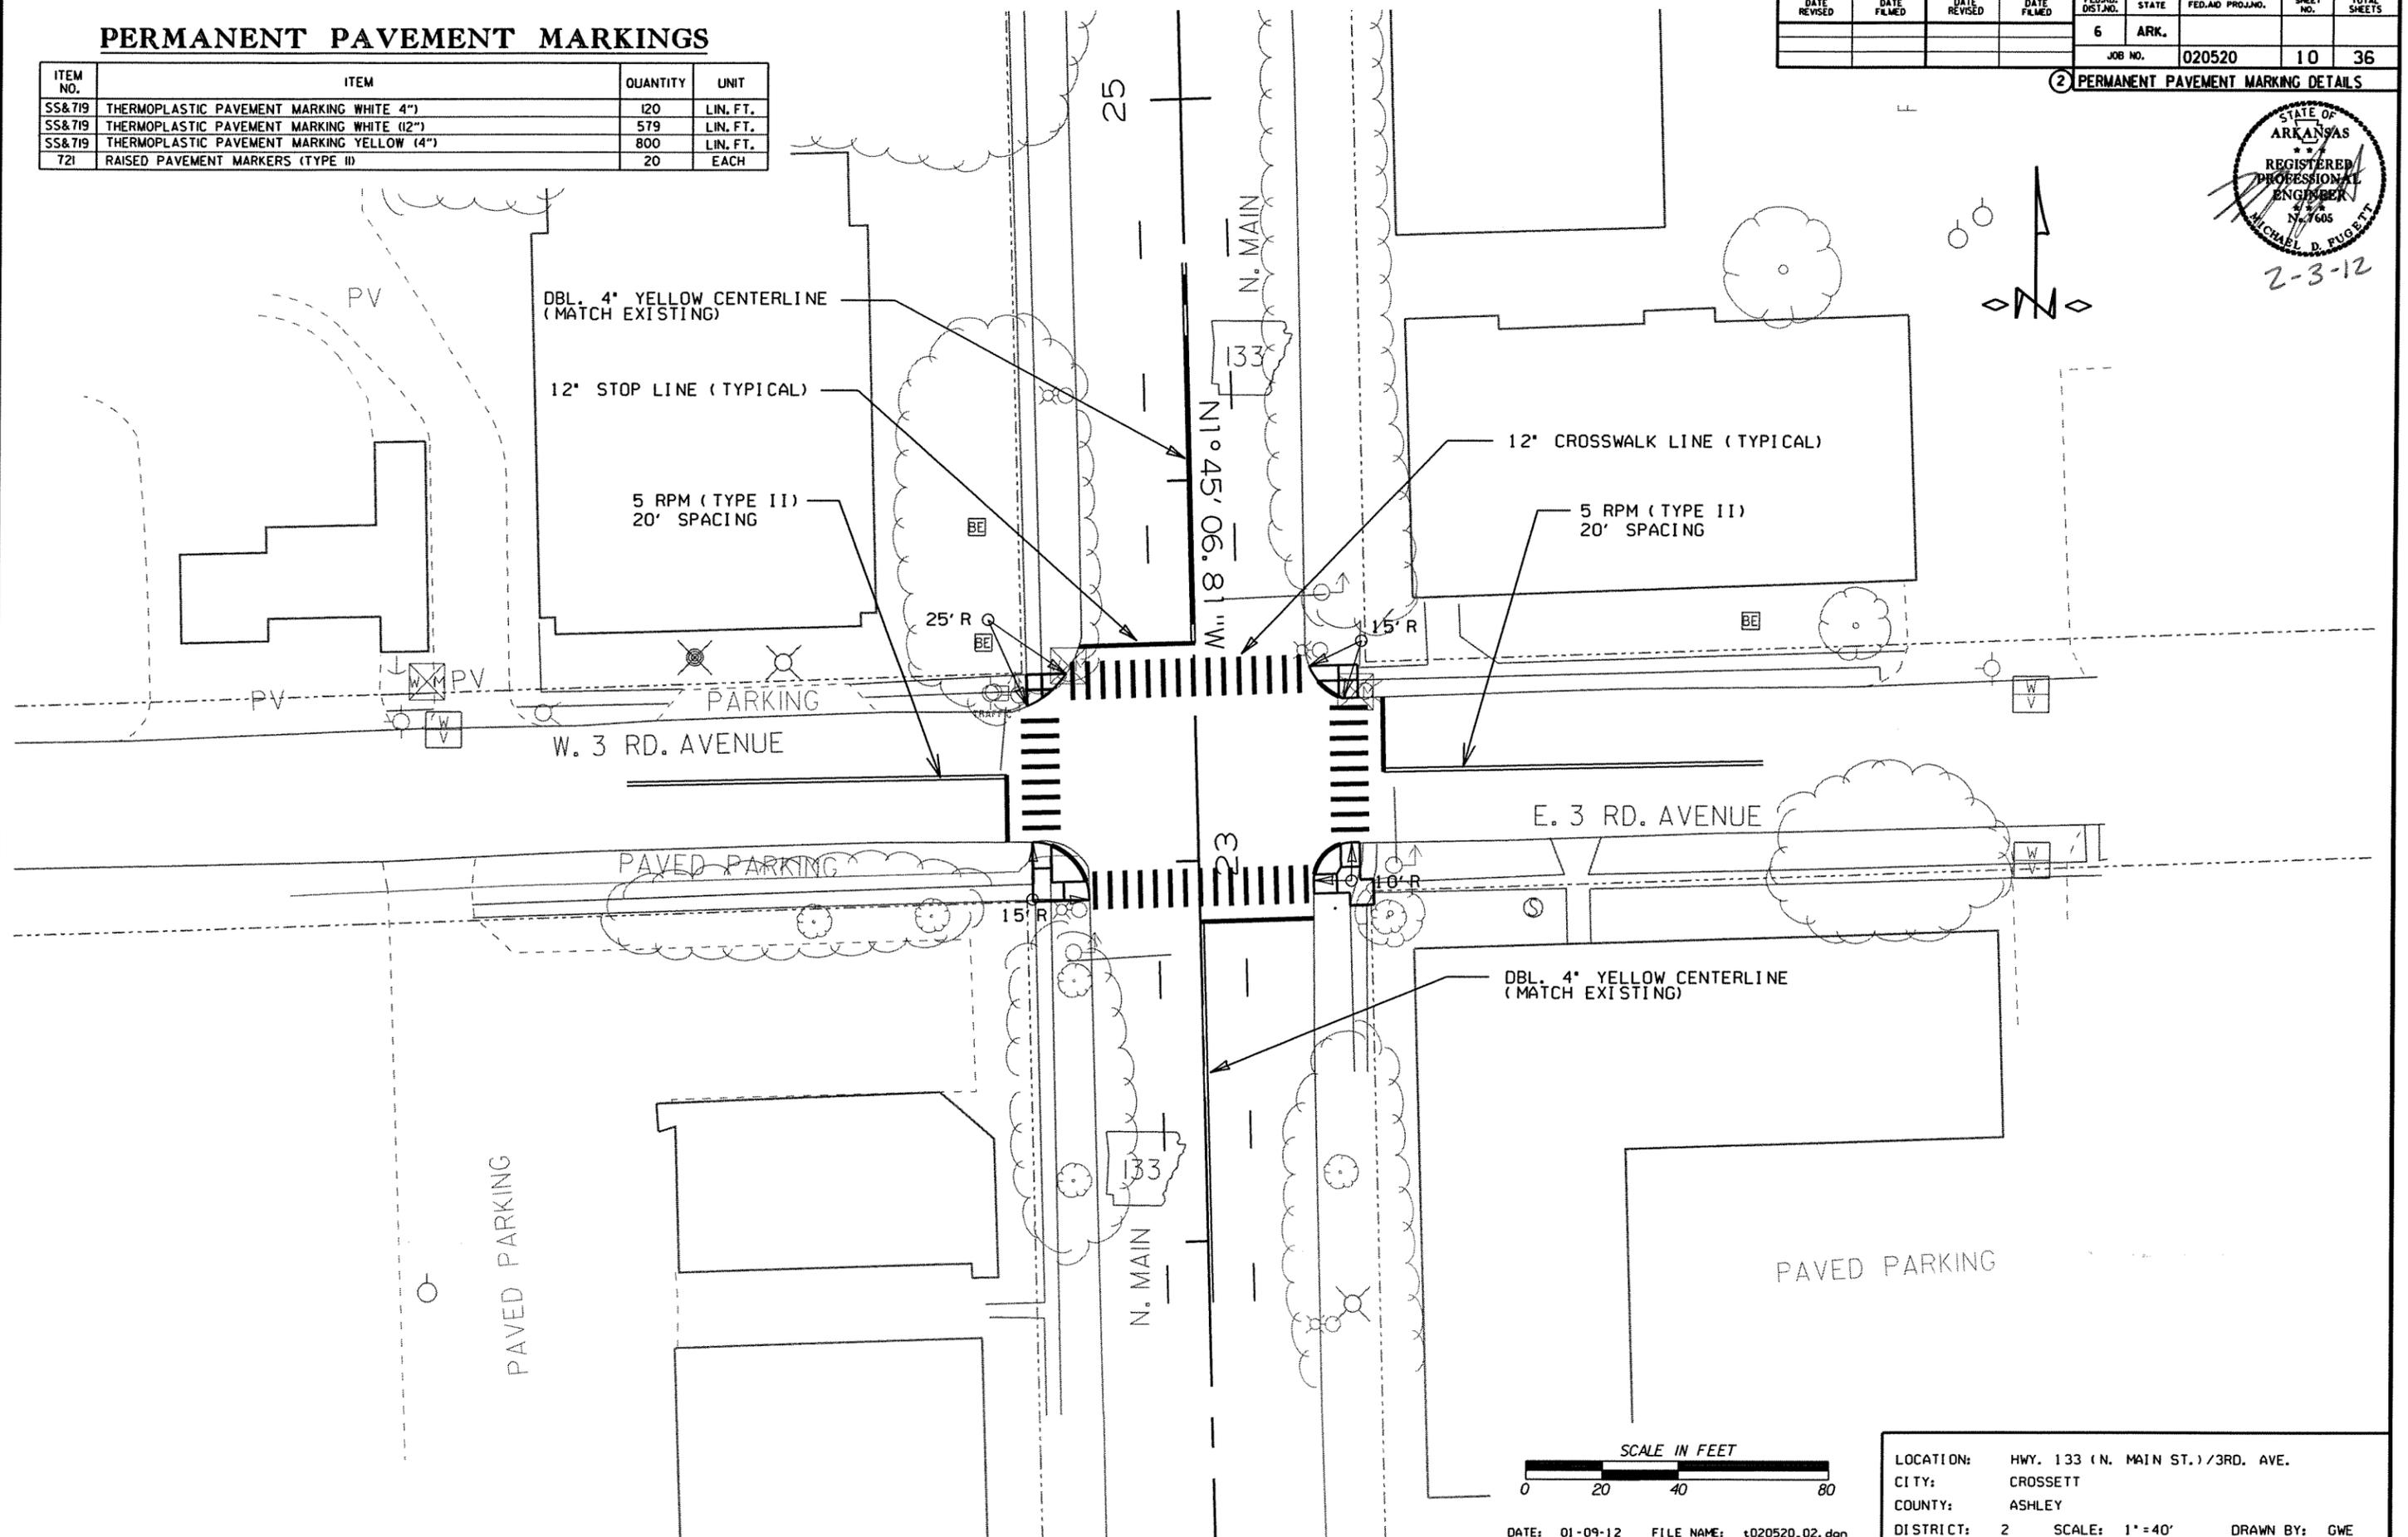

ZBORDER.CEL 8/30/2010

 

DATE: 01-09-12 FILE NAME: t020520.02.dgn



LOCATION: HWY. 133 (N. MAIN ST.) / 3RD. AVE.  
 CITY: CROSSETT  
 COUNTY: ASHLEY  
 DISTRICT: 2 SCALE: 1" = 40' DRAWN BY: GWE

# PERMANENT PAVEMENT MARKINGS

ITEM NO.	ITEM	QUANTITY	UNIT
SS&719	THERMOPLASTIC PAVEMENT MARKING WHITE (4")	120	LIN. FT.
SS&719	THERMOPLASTIC PAVEMENT MARKING WHITE (12")	394	LIN. FT.
SS&719	THERMOPLASTIC PAVEMENT MARKING YELLOW (4")	800	LIN. FT.
721	RAISED PAVEMENT MARKERS (TYPE II)	20	EACH

DATE REVISED	DATE FILMED	DATE REVISED	DATE FILMED	FED. RD. DIST. NO.	STATE	FED. AID PROJ. NO.	SHEET NO.	TOTAL SHEETS
				6	ARK.			
						JOB NO. 020520	11	36

② PERMANENT PAVEMENT MARKING DETAILS

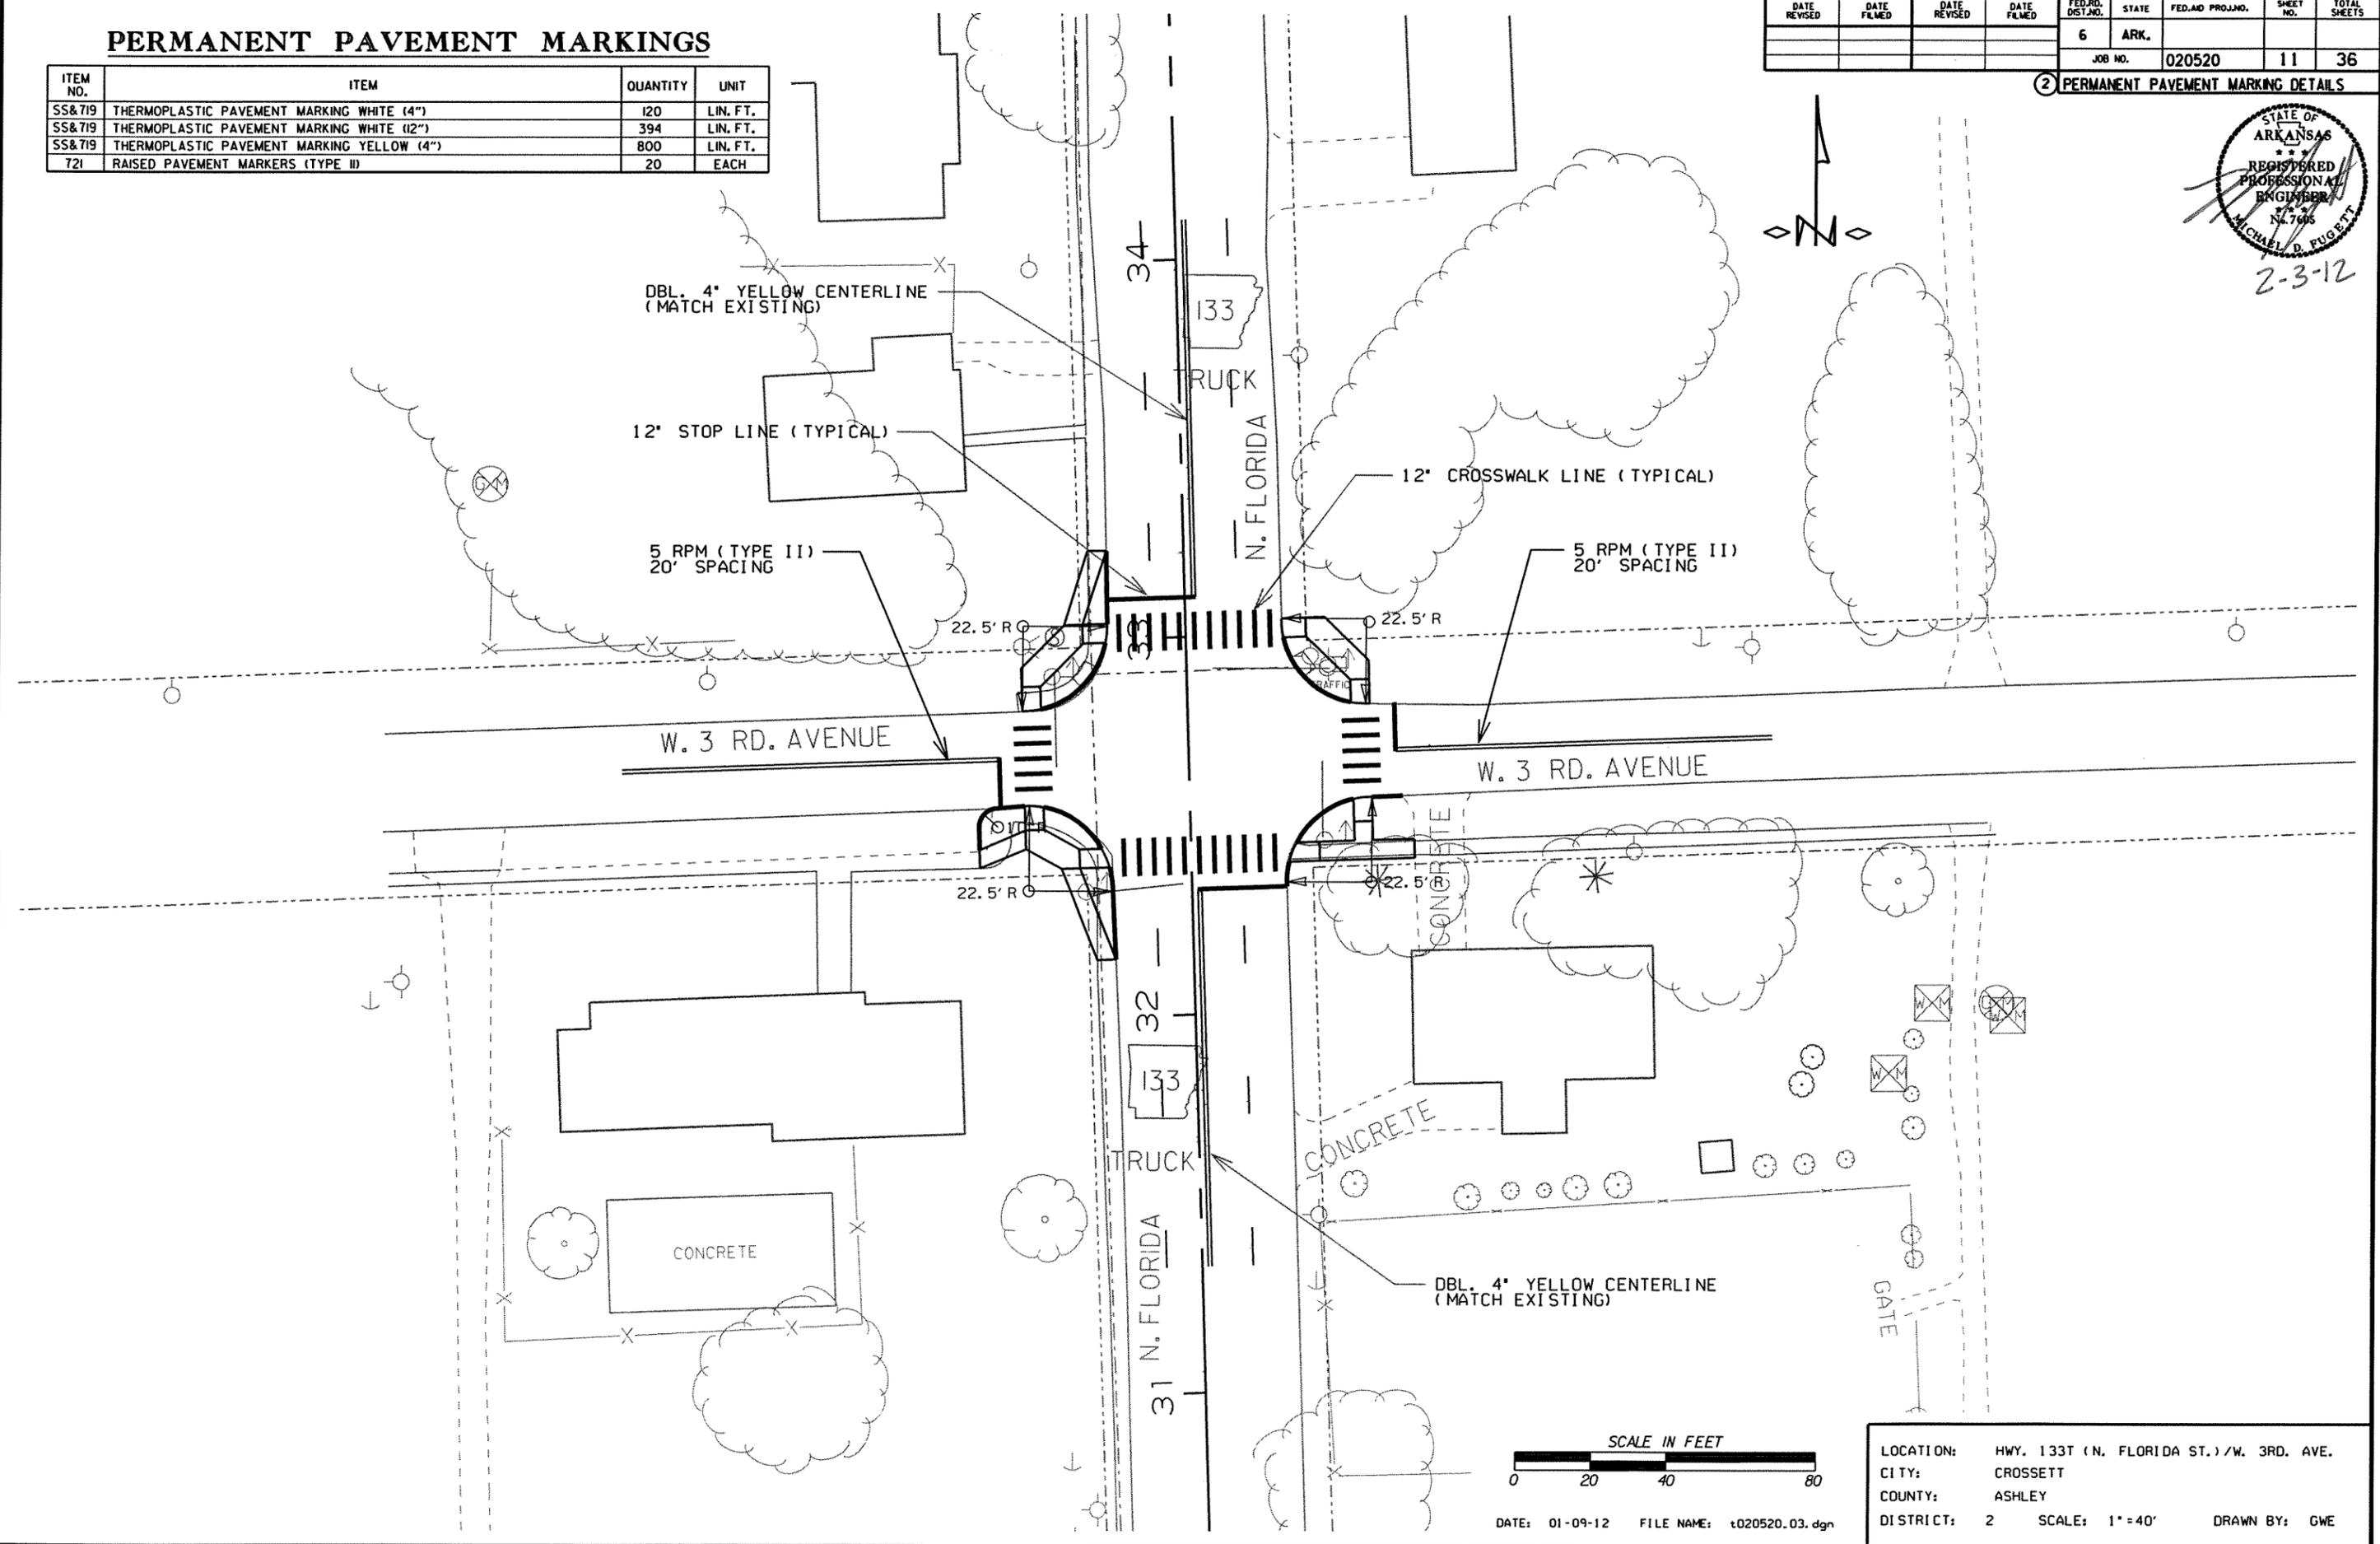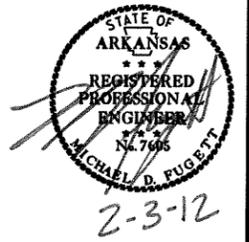

LOCATION: HWY. 133T (N. FLORIDA ST.)/W. 3RD. AVE.  
 CITY: CROSSETT  
 COUNTY: ASHLEY  
 DISTRICT: 2 SCALE: 1" = 40' DRAWN BY: GWE

DATE: 01-09-12 FILE NAME: t020520.03.dgn



DATE REVISED	DATE FILMED	DATE REVISED	DATE FILMED	FED. PROJ. DIST. NO.	STATE	FED. AID PROJ. NO.	SHEET NO.	TOTAL SHEETS
				6	ARK.			
				JOB NO.	020520		13	36

2 SURVEY CONTROL DETAILS

Coordinate System: ARKANSAS STATE PLANE - SOUTH ZONE BASED ON GPS CONTROL,  
PROJECTED TO GROUND.  
Units: U.S. SURVEY FOOT



2-3-12

Point Name	Northing	Easting	Elev	Feature	Description
1	1476084.2723	1324723.1189	157.540	CTL	5/8" REBAR W/2" CAP, 10' NORTH TELEPHONE POLE
2	1476686.9018	1324477.6334	165.435	CTL	5/8" REBAR W/2" CAP, 16' NORTHEAST POWER POLE
3	1478389.1909	1324137.9453	157.729	CTL	5/8" REBAR W/2" CAP, 35' NORTHWEST TELE. POLE
4	1478672.2587	1324144.1712	155.973	CTL	5/8" REBAR W/2" CAP, 12' SOUTHEAST TELE. POLE
5	1479095.1471	1324199.0103	154.949	CTL	5/8" REBAR W/2" CAP, 18' NORTHWEST 6" X6" WOOD POST
6	1481462.7622	1324054.6418	167.169	CTL	5/8" REBAR W/2" CAP, 74' SOUTH GALV LIGHTPOLE
7	1481769.7268	1324117.9267	167.968	CTL	5/8" REBAR W/2" CAP, 17' NORTHWEST 10" OAK TREE
8	1482088.7361	1324025.0379	164.475	CTL	5/8" REBAR W/2" CAP, 58' SOUTHEAST 14" OAK TREE
9	1481412.9117	1322441.0038	146.843	CTL	5/8" REBAR W/2" CAP, 31' SOUTH COMBINATION POLE
10	1481708.0060	1322363.9719	151.005	CTL	5/8" REBAR W/2" CAP, 12' NORTHWEST TRAFF. SIGNAL POLE
11	1482049.2529	1322418.4790	155.324	CTL	5/8" REBAR W/2" CAP, 82' SOUTH COMBINATION POLE
12	1482780.0962	1321859.0930	163.413	CTL	5/8" REBAR W/2" CAP, 48' EAST NORTHEAST POWER POLE
13	1482865.1968	1322322.3213	165.159	CTL	5/8" REBAR W/2" CAP, 7' NORTHEAST LIGHT POLE
14	1482783.1726	1322762.3578	164.385	CTL	5/8" REBAR W/2" CAP, 10' NORTHEAST FIRE HYDRANT
15	1482853.5386	1323751.3685	166.075	CTL	5/8" REBAR W/2" CAP, 32' NORTH CENTERLINE HWY. 82
16	1482856.0034	1324091.3254	167.362	CTL	5/8" REBAR W/2" CAP, 5' EAST SIGNAL POLE
17	1482769.6101	1324497.9807	162.909	CTL	5/8" REBAR W/2" CAP, 19' SOUTH FIRE HYDRANT
18	1482809.2134	1324863.4572	156.057	CTL	5/8" REBAR W/2" CAP, 7' SOUTH SIGNAL POLE
19	1482829.4406	1325432.4302	151.330	CTL	5/8" REBAR W/2" CAP, 15' WEST POWER POLE
20	1483056.1648	1326479.5455	158.423	CTL	5/8" REBAR W/2" CAP, 43' NORTH RAILROAD SWITCH BOX
21	1483548.1172	1326479.1108	146.977	CTL	5/8" REBAR W/2" CAP, 16' N. WEST CORNER CONC. DRIVE EXXON
22	1485351.5534	1326466.0694	147.125	CTL	5/8" REBAR W/2" CAP, 47' NORTHEAST TELE. BOX #1253
23	1485826.6230	1326433.9225	148.562	CTL	5/8" REBAR W/2" CAP, 28' SOUTH TRAFFIC SIGNAL POLE
24	1486312.5133	1326388.9824	153.759	CTL	5/8" REBAR W/2" CAP, 57' NORTH CATCH BASIN
25	1483876.6958	1329911.9617	170.228	CTL	5/8" REBAR W/2" CAP, 20' SOUTHEAST TELE. BOX #35
26	1483886.3977	1330310.1176	169.991	CTL	5/8" REBAR W/2" CAP, 22' SOUTHEAST COMBINATION POLE 2GY
27	1483815.5456	1330596.7962	167.814	CTL	5/8" REBAR W/2" CAP, 53' SOUTHEAST TELE. BOX #3561
28	1476341.8717	1323902.5762	165.466	CTL	5/8" REBAR W/2" CAP
29	1484137.6087	1326443.5404	145.629	CTL	5/8" REBAR W/2" CAP
30	1479006.5980	1322561.0472	159.087	CTL	5/8" REBAR W/2" CAP
100	1476337.2764	1324697.3823	160.265	GPS	AHTD GPS 020002
101	1475469.0117	1324966.9596	161.147	GPS	AHTD GPS 020025

HWY. 133 (N. MAIN ST.)/3RD. AVE.

POINT NO.	TYPE	STATION	NORTHING	EASTING
8002	POB	20+00.00	1481475.8195	1324091.7614
8003	POE	25+95.32	1482070.8611	1324073.5616

HWY. 133T (N. FLORIDA ST.)/W. 3RD. AVE.

POINT NO.	TYPE	STATION	NORTHING	EASTING
8004	POB	30+00.00	1481470.7210	1322409.9826
8005	POE	35+65.02	1482035.4245	1322391.0111

\*Note - Rebar and Cap - Standard - 5/8" Rebar with 2" Aluminum Cap stamped  
\*(standard markings common to all caps), or as indicated  
(other markings indicated in the point description of the individual point).  
ALL DISTANCES ARE GROUND.  
USE CAF = 1.0 FOR STAKEOUT FOR THIS PROJECT.  
A PROJECT CAF OF 1.000032537 HAS BEEN USED TO COMPUTE THE ABOVE GROUND COORDINATES.  
THIS CAF IS INTENDED FOR USE WITHIN THE PROJECT LIMITS.  
GRID DISTANCE = GROUND DISTANCE X CAF.  
GRID COORDINATES ARE STORED UNDER FILE NAME, S020520G1.CTL  
HORIZONTAL DATUM: NAD 83 (1997)  
VERTICAL DATUM: NAVD 88 POSITIONAL ACCURACY, RTK ELEV.

REFERENCE POINTS (1500 SERIES) ARE TO BE USED TO ESTABLISH CONTROL  
IF THE PRIMARY CONTROL POINTS LISTED ABOVE HAVE BEEN DESTROYED.  
REFERENCE POINTS ARE NOT TO BE USED FOR VERTICAL CONTROL.

BASIS OF BEARING:  
ARKANSAS STATE PLANE GRID BEARINGS - 0302-SOUTH ZONE  
DETERMINED FROM GPS CONTROL POINTS: 020002-020025  
CONVERGENCE ANGLE: 00-01-26RIGHT AT LT: 33-08-07.16 LG: 91-57-25.46  
GRID AZIMUTH = ASTRONOMICAL AZIMUTH - CONVERGENCE ANGLE.



LOCATION: HWY. 133/3RD. AVE. & HWY. 133T/3RD. AVE.  
CITY: CROSSETT  
COUNTY: ASHLEY  
DISTRICT: 2 SCALE: N/A DRAWN BY: GWE

DATE: 01-09-12 FILE NAME: t020520.job.dgn



DATE REVISED	DATE FILMED	DATE REVISED	DATE FILMED	FED. RD. DIST. NO.	STATE	FED. AID PROJ. NO.	SHEET NO.	TOTAL SHEETS
				6	ARK.			
JOB NO. 020520							15	36

 2 SURVEY CONTROL DETAILS

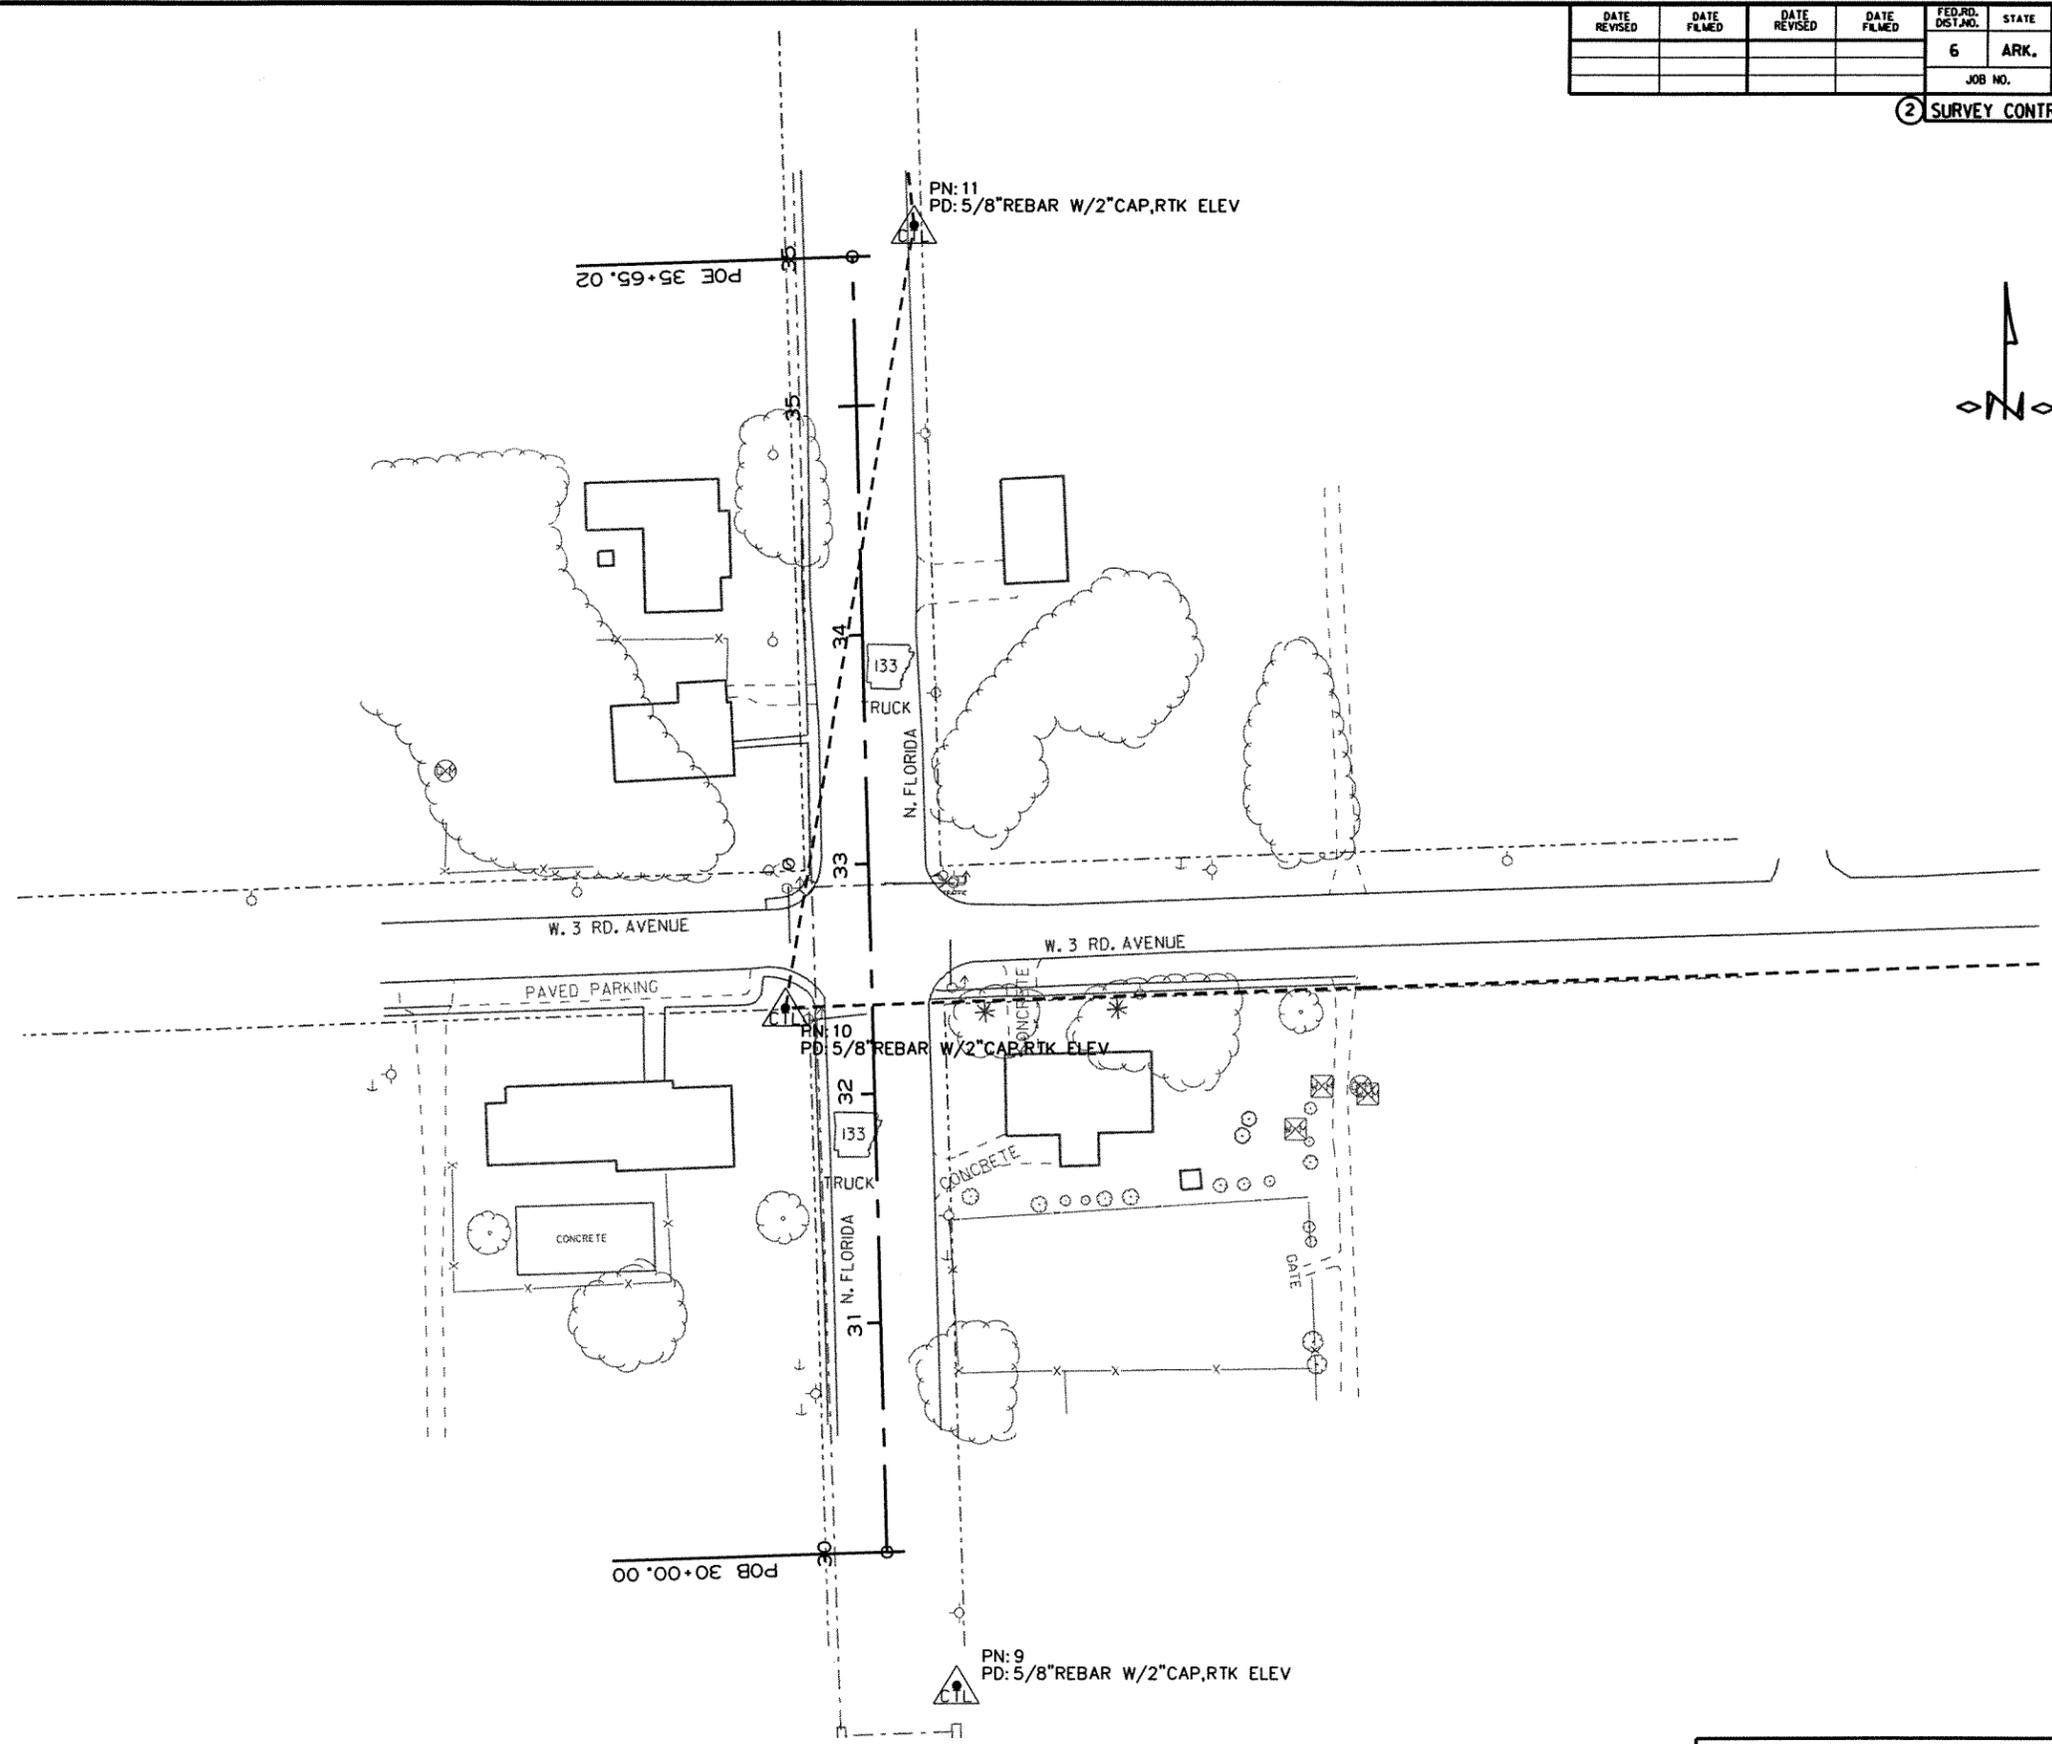

DATE: 01-09-12 FILE NAME: t020520.03.dgn

LOCATION: HWY. 133T (N. FLORIDA ST.) / W. 3RD. AVE.  
 CITY: CROSSETT  
 COUNTY: ASHLEY  
 DISTRICT: 2 SCALE: 1"=80' DRAWN BY: GWE

**TRAFFIC SIGNAL NOTES:**

1. PERFORM ELECTRICAL WORK IN ACCORDANCE WITH THE CURRENT EDITIONS OF THE NFPA 70 (2002) NATIONAL ELECTRICAL CODE, NFPA 101(2000) LIFE SAFETY CODE, STATE ELECTRICAL CODE AND LOCAL ELECTRICAL CODE.
2. EXTEND GREEN EQUIPMENT GROUNDING CONDUCTOR (EGC) FROM GROUND BAR AT MAIN BREAKER TO CONTROL PANEL AND TO FIRST POLE, SOLIDLY BOND EGC TO GROUND LUG OF CONTROL CABINET AND TO POLE GROUND, ENSURE THAT ONLY ONE NEUTRAL-TO-GROUND BOND EXISTS IN THE SYSTEM AND THAT IT IS AT THE MAIN BREAKER.
3. ELECTRICAL SERVICE SHALL BE PROVIDED BY THE CITY TO A SERVICE POLE WITH EXTERNAL RAIN TIGHT BREAKER (MAIN BREAKER), GALVANIZED STEEL SERVICE RISER, METER LOOP (IF REQUIRED), AND WEATHERHEAD AT A MUTUALLY ACCEPTABLE POINT WITHIN THE RIGHT-OF-WAY. IF THE SERVICE POINT IS OVER 10 FEET FROM THE CONTROLLER, THE CONTRACTOR SHALL PROVIDE AND INSTALL A SEPARATE TWO CIRCUIT EXTERNAL BREAKER (SECONDARY BREAKER) ON OR NEAR THE TRAFFIC SIGNAL CONTROLLER CABINET AND SHALL INSTALL CONDUIT, ELECTRICAL SERVICE WIRE (2c/\*6 USE RATED, WITH GROUND TYPICAL), AND PERFORM WIRING TO TAP INTO THE CITY'S MAIN BREAKER AS PART OF THIS CONTRACT. CONDUIT IS PAID FOR AS A SEPARATE ITEM OF THIS CONTRACT. TWO CIRCUIT BREAKERS, CONSIDERED SUBSIDIARY TO THE CONTROL EQUIPMENT WHERE STREET LIGHTING IS INCLUDED. AS PART OF THE SIGNAL INSTALLATION, STREET LIGHTING CIRCUIT (2c/\*12 AWG UF RATED, TYPICAL) SHALL BE KEPT FROM THE CIRCUIT SERVING THE TRAFFIC SIGNAL CONTROL EQUIPMENT FROM THE POINT OF TIE-IN AT THE SECONDARY BREAKER PROVIDED BY THE CONTRACTOR.
4. CONTRACTOR SHALL CONNECT A SEPARATE NEUTRAL FOR EACH LOAD SWITCH REPRESENTED ON EACH SIGNAL POLE.
5. TRAFFIC CONTROLLER CABINET SHALL HAVE 16 LOAD BAYS AND LAYOUT SHALL BE SUCH THAT IT IS NOT NECESSARY TO SHUT DOWN POWER OR REMOVE LOAD SWITCHES IN ORDER TO EASILY TEST OR MODIFY DETECTOR INPUTS TO THE CONTROLLER.
6. CONTROLLER CABINET SHALL BE WIRED SUCH THAT DURING FLASH OPERATIONS POWER TO THE LOAD SWITCHES CANNOT BACKFEED TO LOAD SWITCH POWER BUSS.
7. ALL PARTS OF THIS INSTALLATION SHALL BE IN ACCORDANCE WITH THE ARKANSAS HIGHWAY AND TRANSPORTATION DEPARTMENT STANDARDS AND DETAILS, AND WITH THE MANUAL ON UNIFORM TRAFFIC CONTROL DEVICES, CURRENT EDITIONS.
8. CONDUIT INSTALLED UNDER ROADWAY SURFACES SHALL BE INSTALLED BY PUSHING OR BORING METHODS. IF THE ENGINEER DETERMINES THIS IS NOT FEASIBLE, THEN A TRENCHING METHOD MAY BE USED.
9. TRAFFIC SIGNAL POLES SHALL BE GALVANIZED. BACKPLATES SHALL BE SUPPLIED FOR ALL SIGNAL HEADS.
10. PAVEMENT MARKING SHOWN FOR REFERENCE ONLY. SEE PAVEMENT MARKING PLAN SHEETS.
11. FOUNDATION FOR ALL POLES SHALL BE EXTENDED IF NECESSARY TO ACCOMMODATE THE REQUIREMENTS FOR SIGNAL HEAD CLEARANCE ABOVE ROADWAY ONLY AT LOCATIONS WHERE THE GROUND ELEVATION AT THE POLE IS BELOW THE ELEVATION OF THE ROADWAY (SEE NOTES ON SPECIAL DETAILS). PAYMENT WILL BE INCLUDED IN SECTION 714, AHTD STANDARD SPECIFICATIONS FOR HIGHWAY CONSTRUCTION.
12. ALL BOXES SHALL BE (TYPE 2 HD) UNLESS OTHERWISE INDICATED. ALL CONDUIT SHALL BE 3" DIAMETER UNLESS SPECIFIED ON PLANS.
13. CONTRACTOR SHALL NOTIFY ALL EXISTING UTILITY OWNERS BEFORE BEGINNING WORK ON THIS PROJECT.
14. LUMINAIRE ASSEMBLIES SHALL BE OF THE FULL CUTOFF TYPE.
15. HARDWARE INPUTS MAY BE DETERMINED BY SUPPLIER. EACH DETECTOR OUTPUT SHALL INPUT THE CONTROLLER THROUGH A SEPARATE INPUT UNLESS OTHERWISE NOTED AND BE PROGRAMMED TO ACTUATE THE ASSOCIATED PHASE. COMBINATION (COMB.) DETECTORS SHALL ALSO BE PROGRAMMED TO PROVIDE VEHICLE COUNT/OCCUPANCY DATA.
16. TO DETERMINE UTILITY CLEARANCES ABOVE THE TRAFFIC SIGNAL POLE, REFER TO THE POLE SCHEDULE FOR VERTICAL SHAFT HEIGHT. WHERE THE POLE SCHEDULE INDICATES THAT A LUMINAIRE ARM WILL BE USED, 38 FEET SHOULD BE USED TO DETERMINE UTILITY CLEARANCE ABOVE THE LUMINAIRE ARM. WHERE THE POLE SCHEDULE INDICATES A TRAFFIC SIGNAL POLE WITHOUT A LUMINAIRE ARM, A HEIGHT OF 21' SHOULD BE USED TO DETERMINE UTILITY CLEARANCE ABOVE THE TRAFFIC SIGNAL MAST ARM. AN ADDITIONAL 6 FEET SHOULD BE USED DIRECTLY ABOVE "VIDEO DETECTOR" AT LOCATIONS SHOWN ON THE SIGNAL PLANS.
17. THE DESIRABLE MINIMUM DISTANCE FROM THE FACE OF ROADWAY CURB OR SHOULDER EDGE TO THE FACE OF NON-BREAKAWAY POLE OR OBSTRUCTION IS 6 FEET. REFER TO TRAFFIC SIGNAL PLANS FOR SPECIFIC LOCATION OF POLES, CONTROLLER AND ANY OTHER NON-BREAKAWAY OBSTRUCTIONS. REFER TO "DESIGN PARAMETERS, MINIMUM CLEAR ZONE DISTANCE" FOR MINIMUM DISTANCE FROM THE EDGE OF TRAVELED WAY TO THE FACE OF A NON-BREAKAWAY POLE OR OBSTRUCTION. TRAFFIC SIGNAL POLES OR ANY OTHER NON-BREAKAWAY OBSTRUCTION SHALL NOT BE INSTALLED WITHIN THE CLEAR ZONE.
18. AS DETERMINED BY THE ENGINEER, FOUNDATION EMBEDMENT MAY BE DECREASED BY A MAXIMUM OF TWO FEET IF COMPETENT ROCK IS ENCOUNTERED PRIOR TO ACHIEVING PLAN EMBEDMENT AND AT LEAST HALF OF THE REMAINING PLAN EMBEDMENT LENGTH IS KEYED INTO COMPETENT ROCK.
19. CONNECTION OF TRAFFIC SIGNAL DISPLAY TO FIELD WIRING SHALL UTILIZE AN APPROVED TERMINAL STRIP BEHIND HAND-HOLE COVER AT BASE OF POLE. TERMINAL STRIP SHALL PROVIDE PROTECTION TO PREVENT EXPOSURE TO THE PUBLIC IN THE EVENT THAT POLE COVER IS MISSING. PAYMENT FOR TERMINAL STRIPS SHALL BE INCLUDED IN ITEM 714-TRAFFIC SIGNAL MAST ARM AND POLE WITH FOUNDATION.
20. CONTROLLER CABINET LAYOUT AND ORIENTATION SHALL CONFORM TO ISMA STANDARDS.
21. ONE VIDEO PROGRAMMING MODULE SHALL BE PROVIDED FOR AIMING AND SETUP OF DETECTORS IF THE VIDEO SYSTEM CANNOT BE ADJUSTED THROUGH HARDWARE AND SOFTWARE PROVIDED BY ITEMS WITHIN THE JOB.
22. TRAFFIC SIGNAL CONTRACTOR MUST NOTIFY RESIDENT ENGINEER OR ASSIGNED DEPARTMENT PROJECT INSPECTOR EACH DAY PRIOR TO SIGNAL RELATED WORK. NO WORK ON TRAFFIC SIGNALS WILL BE ALLOWED OR APPROVED WITHOUT THIS PRIOR NOTIFICATION.
23. ALL STEEL POLES SHALL BE DESIGNED TO MEET THE AASHTO STANDARD SPECIFICATIONS FOR STRUCTURAL SUPPORTS FOR HIGHWAY SIGNS, LUMINAIRES AND TRAFFIC SIGNALS, 4TH EDITION (2001) WITH 2003 AND 2006 INTERIMS.

DATE REVISED	DATE FILMED	DATE REVISED	DATE FILMED	FED. RD. DIST. NO.	STATE	FED. AID PROJ. NO.	SHEET NO.	TOTAL SHEETS
				6	ARK.			
				JOB NO.	020520		16	36

② TRAFFIC SIGNAL NOTES



2-3-12

LOCATION: HWY. 133/3RD. AVE. & HWY. 133T/3RD. AVE.  
 CITY: CROSSETT  
 COUNTY: ASHLEY  
 DISTRICT: 2 SCALE: N/A DRAWN BY: GWE


DATE REVISED	DATE FILMED	DATE REVISED	DATE FILMED	FED. DIST. NO.	STATE	FED. AID PROJ. NO.	SHEET NO.	TOTAL SHEETS
				6	ARK.			
				JOB NO.	020520		17	36

2 SIGNALIZATION PLAN SHEET



ITEM NO.	ITEM	QUANTITY	UNIT
SP&701	ACTUATED CONTROLLER TS 2-TYPE 2 (8 PHASES)	1	EACH
SP&706	TRAFFIC SIGNAL HEAD, LED, (3 SECTION, 1WAY)	8	EACH
SP&707	COUNTDOWN PEDESTRIAN SIGNAL HEAD, LED	8	EACH
708	TRAFFIC SIGNAL CABLE (5C/14 A.W.G.)	820	LIN. FT.
708	TRAFFIC SIGNAL CABLE (7C/14 A.W.G.)	226	LIN. FT.
708	TRAFFIC SIGNAL CABLE (20C/14 A.W.G.)	418	LIN. FT.
709	GALVANIZED STEEL CONDUIT (1.25")	20	LIN. FT.
710	NON-METALLIC CONDUIT (1.25")	20	LIN. FT.
710	NON-METALLIC CONDUIT (2")	20	LIN. FT.
710	NON-METALLIC CONDUIT (3")	297	LIN. FT.
SS&711	CONCRETE PULL BOX (TYPE 2 HD)	5	EACH
SS&714	TRAFFIC SIGNAL MAST ARM AND POLE WITH FOUNDATION (26')	1	EACH
SS&714	TRAFFIC SIGNAL MAST ARM AND POLE WITH FOUNDATION (30')	1	EACH
SS&714	TRAFFIC SIGNAL MAST ARM AND POLE WITH FOUNDATION (42')	1	EACH
SS&714	TRAFFIC SIGNAL MAST ARM AND POLE WITH FOUNDATION (44')	1	EACH
SS&715	TRAFFIC SIGNAL PEDESTAL POLE WITH FOUNDATION	1	EACH
SP&733	VIDEO DETECTOR (CLR)	5	EACH
733	VIDEO CABLE	650	LIN. FT.
733	VIDEO MONITOR (CLR)	1	EACH
SP&733	VIDEO PROCESSOR, EDGE CARD (2 CAMERA)	4	EACH
SP&733	VEHICLE DETECTOR RACK (16 CHANNEL)	1	EACH
SP	ELECTRICAL CONDUCTORS FOR LUMINAIRES	241	LIN. FT.
SP	ELECTRICAL CONDUCTORS-IN-CONDUIT (1C/8 A.W.G., EGC)	388	LIN. FT.
SP	ELECTRICAL CONDUCTORS-IN-CONDUIT (1C/12 A.W.G., EGC)	100	LIN. FT.
SP	ELECTRICAL CONDUCTORS-IN-CONDUIT (2C/6 A.W.G.)	20	LIN. FT.
SP	LUMINAIRE ASSEMBLY	2	EACH
SP	REMOVAL OF TRAFFIC SIGNAL EQUIPMENT	0.50	LUMP SUM
SP	SERVICE POINT ASSEMBLY (2 CIRCUITS)	1	EACH
SP	18" STREET NAME SIGN	4	EACH

\*QUANTITIES INCLUDE ONE SPARE VIDEO DETECTOR AND ONE SPARE VIDEO PROCESSOR.

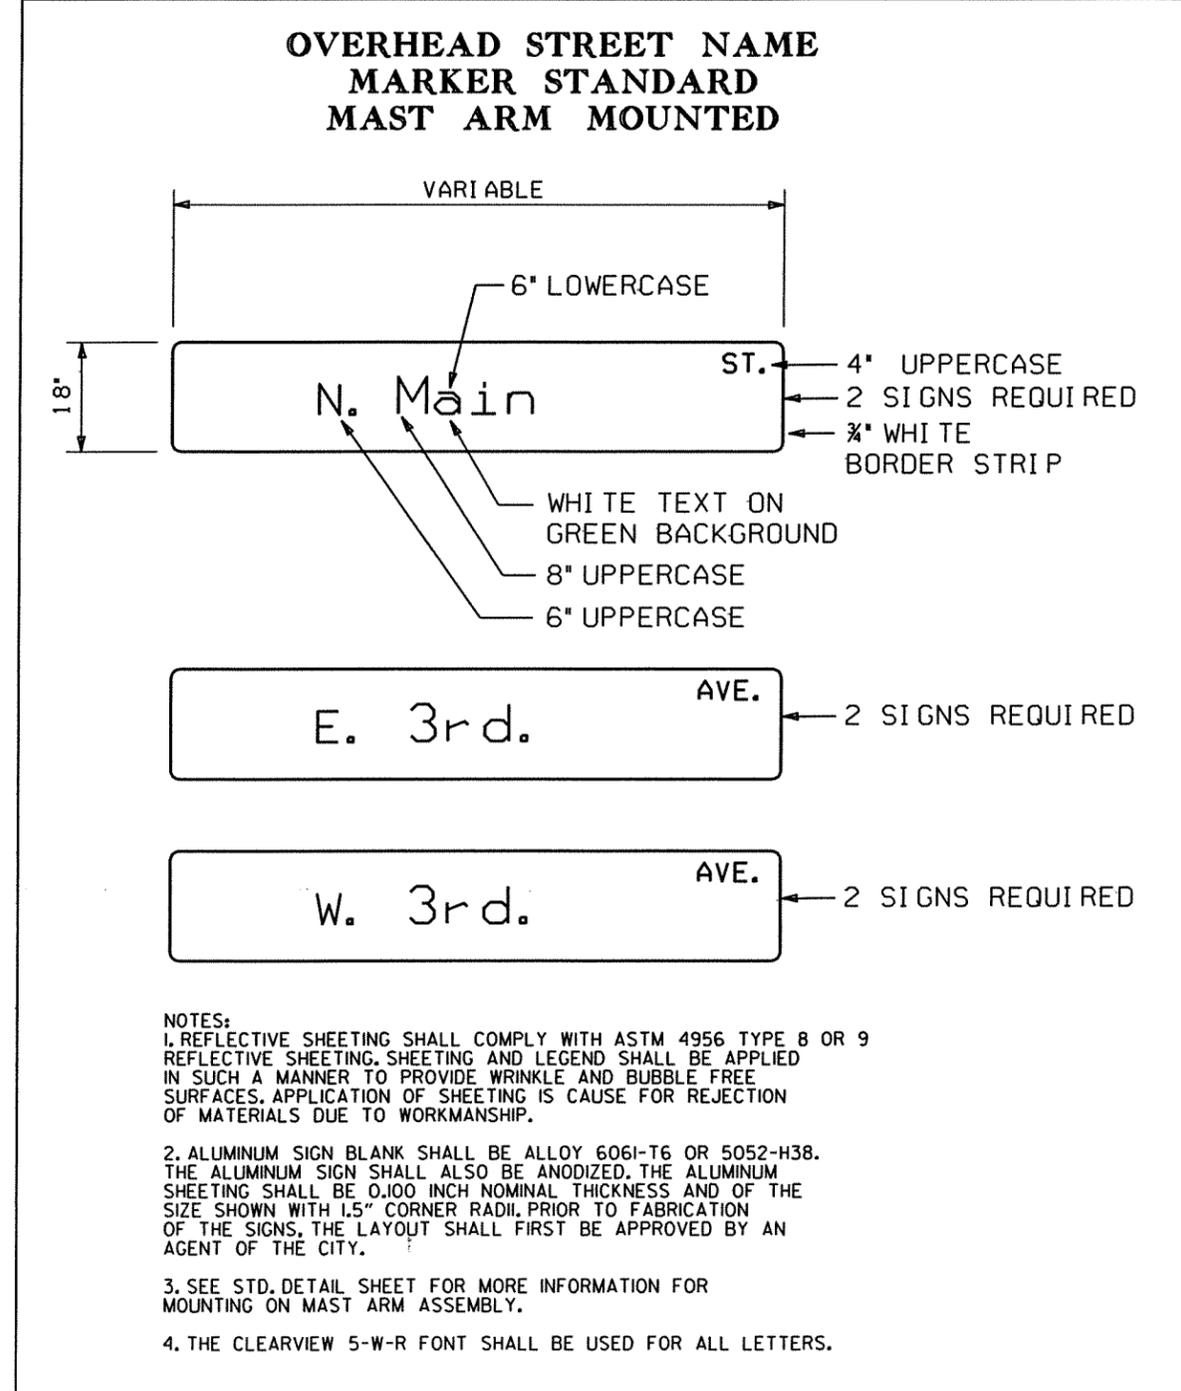

LOCATION: HWY. 133 (N. MAIN ST.) / 3RD. AVE.  
 CITY: CROSSETT  
 COUNTY: ASHLEY  
 DISTRICT: 2 SCALE: N/A DRAWN BY: GWE

DATE: 01-31-12 FILE NAME: t020520.02.dgn


1020520\_02.dgn 02-14-2011

DATE REVISED	DATE FILMED	DATE REVISED	DATE FILMED	FED. RD. DIST. NO.	STATE	FED. AID PROJ. NO.	SHEET NO.	TOTAL SHEETS
				6	ARK.		18	36


② SIGNALIZATION PLAN SHEET



**PHASING DIAGRAM**

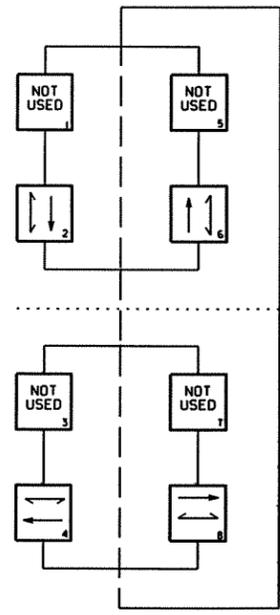

**SIGNAL FACES**

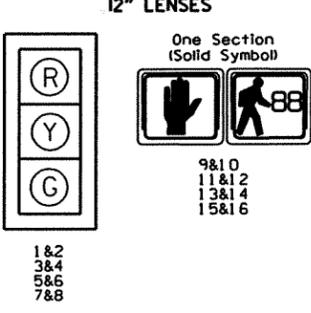

- NOTES:  
 1. ALL SIGNAL HEADS SHALL HAVE BACKPLATES.  
 2. REFER TO SPECIAL PROVISIONS FOR DETAILS ON NEW REQUIREMENTS FOR PEDESTRIAN SIGNAL HEADS

P.O.E. STA. 25+95.32  
 P.I. STA. 25+95.32

Vz21 LOCATED 220' BEHIND STOP LINE

Vz22 LOCATED 70' BEHIND STOP LINE

VIRTUAL 6' X 6' PULSE LOOP (TYPICAL)  
 Vz51 LOCATED 85' BEHIND STOP LINE

VIRTUAL 6' X 50' PRESENCE LOOP (TYPICAL)

Vz41 LOCATED 85' BEHIND STOP LINE

Vz81 COMB. Ø8 Vz82

Vz42 Ø4 Vz41 COMB.

EXIST. R/W 22+90.38  
 68.59'  
 SERVICE POINT AND MAIN BREAKER BY CONTROLLER WITHIN 10' OF

VIDEO DETECTOR (TYPICAL)  
 EXIST. R/W

Vz11 LOCATED 85' BEHIND STOP LINE


Vz62 LOCATED 70' BEHIND STOP LINE

Vz61 LOCATED 220' BEHIND STOP LINE

**HWY. 133/3RD. AVE. POLE DIMENSIONS**

 POLE	MAST ARM	MAST ARM ANGLE	VERT. SHAF. ANGLE	LUM. ARM	LUM. ANGLE
A	42'	270°	35'	15'	180°
B	30'	270°	21'	N/A	N/A
C	N/A	N/A	15'	N/A	N/A
D	44'	180°	21'	N/A	N/A
E	26'	270°	35'	15'	180°

ANGLE MEASURED CLOCKWISE FROM HAND HOLE.




DATE: 01-09-12 FILE NAME: t020520.02.dgn

LOCATION: HWY. 133 (N. MAIN ST.)/3RD. AVE.  
 CITY: CROSSETT  
 COUNTY: ASHLEY  
 DISTRICT: 2 SCALE: 1"=60' DRAWN BY: GWE

1020520\_02.dgn 02-14-2011

DATE REVISED	DATE FILMED	DATE REVISED	DATE FILMED	FED. RD. DIST. NO.	STATE	FED. AID PROJ. NO.	SHEET NO.	TOTAL SHEETS
				6	ARK.			
JOB NO. 020520							19	36

② SIGNALIZATION PLAN SHEET

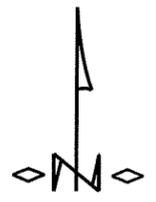


**DESIGN PARAMETERS**


POSTED SPEED LIMIT:  
 30 MPH EAST AND WEST APPROACH  
 30 MPH NORTH AND SOUTH APPROACH  
 NO BUS STOPS  
 NO RAILROAD TRACKS  
 NO EXISTING INTERCONNECTIONS  
 NO FIRE STATION  
 NO PARKING  
 NO SIGHT DISTANCE RESTRICTIONS

LOCATION OF STOP BARS  
 SHOWN ON PAVEMENT MARKING PLAN.  
 SEE SEPARATE SHEET.

MINIMUM CLEAR ZONE DISTANCE  
 1.5 FEET FROM HWY. 133T

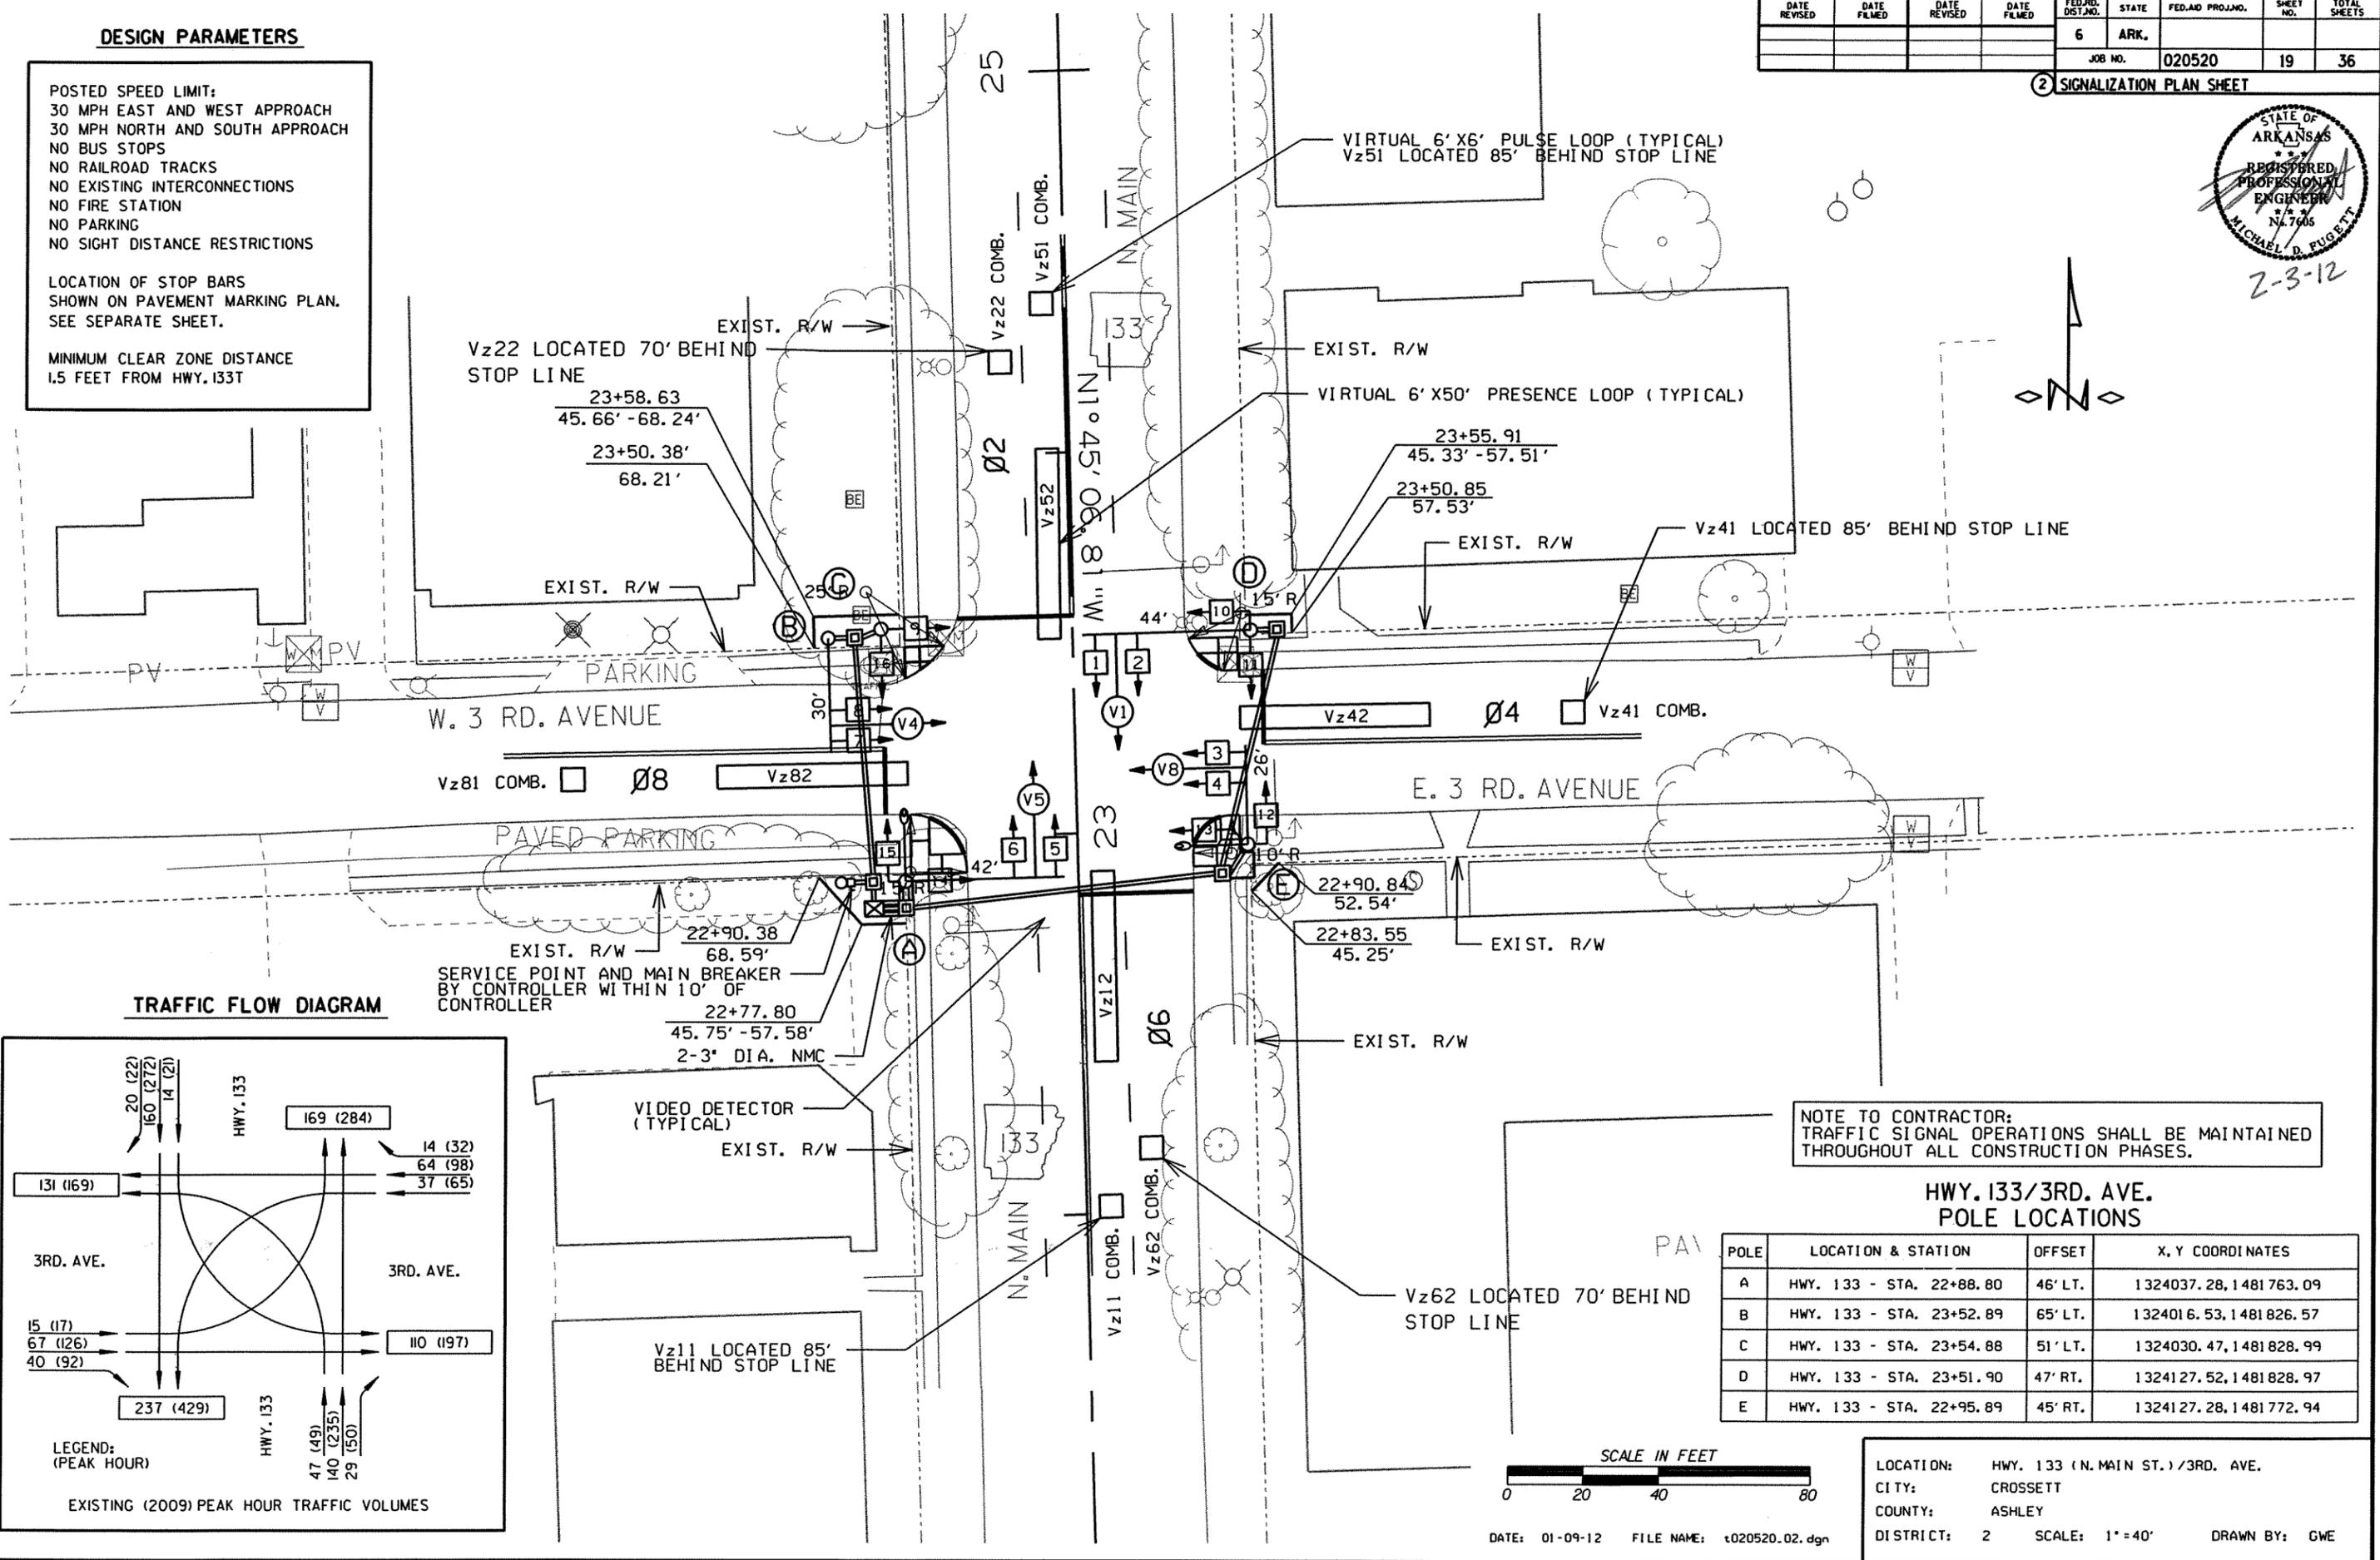


**TRAFFIC FLOW DIAGRAM**

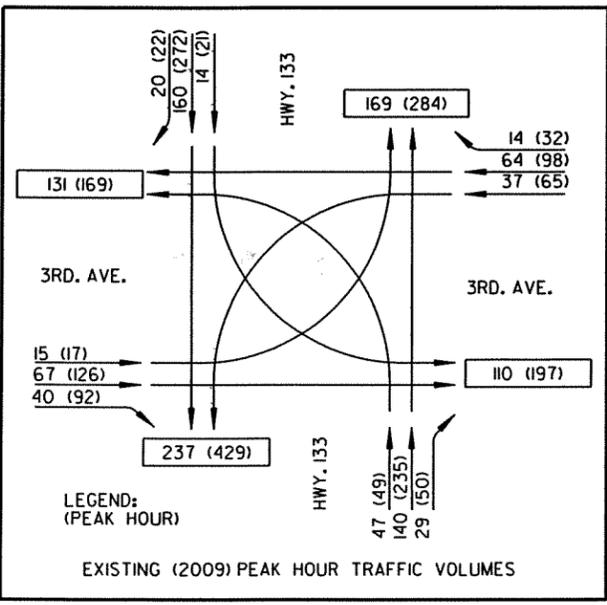

NOTE TO CONTRACTOR:  
 TRAFFIC SIGNAL OPERATIONS SHALL BE MAINTAINED  
 THROUGHOUT ALL CONSTRUCTION PHASES.

**HWY. 133/3RD. AVE.  
 POLE LOCATIONS**

POLE	LOCATION & STATION	OFFSET	X, Y COORDINATES
A	HWY. 133 - STA. 22+88.80	46' LT.	1324037.28, 1481763.09
B	HWY. 133 - STA. 23+52.89	65' LT.	1324016.53, 1481826.57
C	HWY. 133 - STA. 23+54.88	51' LT.	1324030.47, 1481828.99
D	HWY. 133 - STA. 23+51.90	47' RT.	1324127.52, 1481828.97
E	HWY. 133 - STA. 22+95.89	45' RT.	1324127.28, 1481772.94

 

DATE: 01-09-12 FILE NAME: t020520.02.dgn

LOCATION: HWY. 133 (N. MAIN ST.)/3RD. AVE.  
 CITY: CROSSETT  
 COUNTY: ASHLEY  
 DISTRICT: 2 SCALE: 1" = 40' DRAWN BY: GWE

1020520\_02.dgn 02-14-2011



DATE REVISED	DATE FILMED	DATE REVISED	DATE FILMED	FED. DIST. NO.	STATE	FED. PROJ. NO.	SHEET NO.	TOTAL SHEETS
				6	ARK.			
				JOB NO.	020520		21	36


2 SIGNALIZATION PLAN SHEET



2-3-12

ITEM NO.	ITEM	QUANTITY	UNIT
SP&701	ACTUATED CONTROLLER TS 2-TYPE 2 (8 PHASES)	1	EACH
SP&706	TRAFFIC SIGNAL HEAD, LED, (3 SECTION, 1WAY)	8	EACH
SP&707	COUNTDOWN PEDESTRIAN SIGNAL HEAD, LED	8	EACH
708	TRAFFIC SIGNAL CABLE (5C/14 A.W.G.)	606	LIN. FT.
708	TRAFFIC SIGNAL CABLE (7C/14 A.W.G.)	232	LIN. FT.
708	TRAFFIC SIGNAL CABLE (20C/14 A.W.G.)	398	LIN. FT.
709	GALVANIZED STEEL CONDUIT (1.25")	20	LIN. FT.
710	NON-METALLIC CONDUIT (1.25")	20	LIN. FT.
710	NON-METALLIC CONDUIT (2")	20	LIN. FT.
710	NON-METALLIC CONDUIT (3")	275	LIN. FT.
SS&711	CONCRETE PULL BOX (TYPE 2 HD)	5	EACH
SS&714	TRAFFIC SIGNAL MAST ARM AND POLE WITH FOUNDATION (30')	1	EACH
SS&714	TRAFFIC SIGNAL MAST ARM AND POLE WITH FOUNDATION (34')	1	EACH
SS&714	TRAFFIC SIGNAL MAST ARM AND POLE WITH FOUNDATION (42')	2	EACH
SP&733	VIDEO DETECTOR (CLR)	4	EACH
733	VIDEO CABLE	611	LIN. FT.
733	VIDEO MONITOR (CLR)	1	EACH
SP&733	VIDEO PROCESSOR, EDGE CARD (2 CAMERA)	3	EACH
SP&733	VEHICLE DETECTOR RACK (16 CHANNEL)	1	EACH
SP	ELECTRICAL CONDUCTORS FOR LUMINAIRES	215	LIN. FT.
SP	ELECTRICAL CONDUCTORS-IN-CONDUIT (1C/8 A.W.G., EGC)	386	LIN. FT.
SP	ELECTRICAL CONDUCTORS-IN-CONDUIT (1C/12 A.W.G., EGC)	50	LIN. FT.
SP	ELECTRICAL CONDUCTORS-IN-CONDUIT (2C/6 A.W.G.)	20	LIN. FT.
SP	LUMINAIRE ASSEMBLY	1	EACH
SP	REMOVAL OF TRAFFIC SIGNAL EQUIPMENT	0.50	LUMP SUM
SP	SERVICE POINT ASSEMBLY (2 CIRCUITS)	1	EACH
SP	18" STREET NAME SIGN	4	EACH

### OVERHEAD STREET NAME MARKER STANDARD MAST ARM MOUNTED

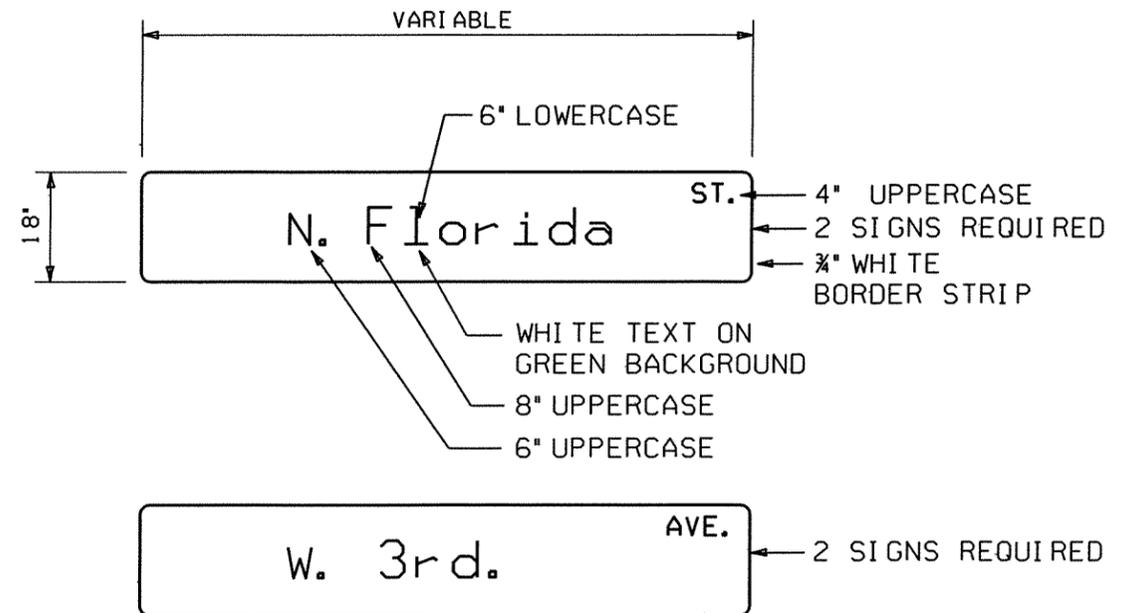

**NOTES:**

1. REFLECTIVE SHEETING SHALL COMPLY WITH ASTM 4956 TYPE 8 OR 9 REFLECTIVE SHEETING. SHEETING AND LEGEND SHALL BE APPLIED IN SUCH A MANNER TO PROVIDE WRINKLE AND BUBBLE FREE SURFACES. APPLICATION OF SHEETING IS CAUSE FOR REJECTION OF MATERIALS DUE TO WORKMANSHIP.

2. ALUMINUM SIGN BLANK SHALL BE ALLOY 6061-T6 OR 5052-H38. THE ALUMINUM SIGN SHALL ALSO BE ANODIZED. THE ALUMINUM SHEETING SHALL BE 0.100 INCH NOMINAL THICKNESS AND OF THE SIZE SHOWN WITH 1.5" CORNER RADII. PRIOR TO FABRICATION OF THE SIGNS, THE LAYOUT SHALL FIRST BE APPROVED BY AN AGENT OF THE CITY.


3. SEE STD. DETAIL SHEET FOR MORE INFORMATION FOR MOUNTING ON MAST ARM ASSEMBLY.

4. THE CLEARVIEW 5-W-R FONT SHALL BE USED FOR ALL LETTERS.


LOCATION: HWY. 133T (N. FLORIDA ST.) / W. 3RD. AVE.  
CITY: CROSSETT  
COUNTY: ASHLEY  
DISTRICT: 2 SCALE: N/A DRAWN BY: GWE

DATE: 01-11-12 FILE NAME: t020520.03.dgn

PHASING DIAGRAM

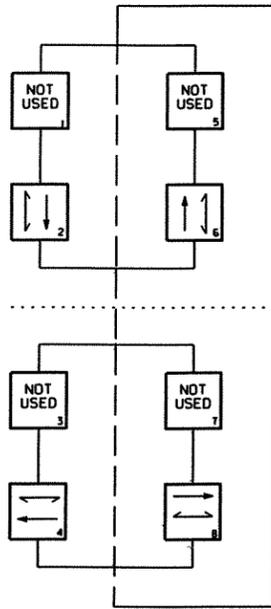

SIGNAL FACES  
12" LENSES

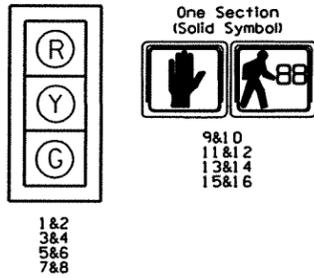


- NOTES:  
1. ALL SIGNAL HEADS SHALL HAVE BACKPLATES.  
2. REFER TO SPECIAL PROVISIONS FOR DETAILS ON NEW REQUIREMENTS FOR PEDESTRIAN SIGNAL HEADS

DATE REVISED	DATE FILMED	DATE REVISED	DATE FILMED	FED. RD. DIST. NO.	STATE	FED. AID PROJ. NO.	SHEET NO.	TOTAL SHEETS
				6	ARK.		22	36

2 SIGNALIZATION PLAN SHEET



2-3-12

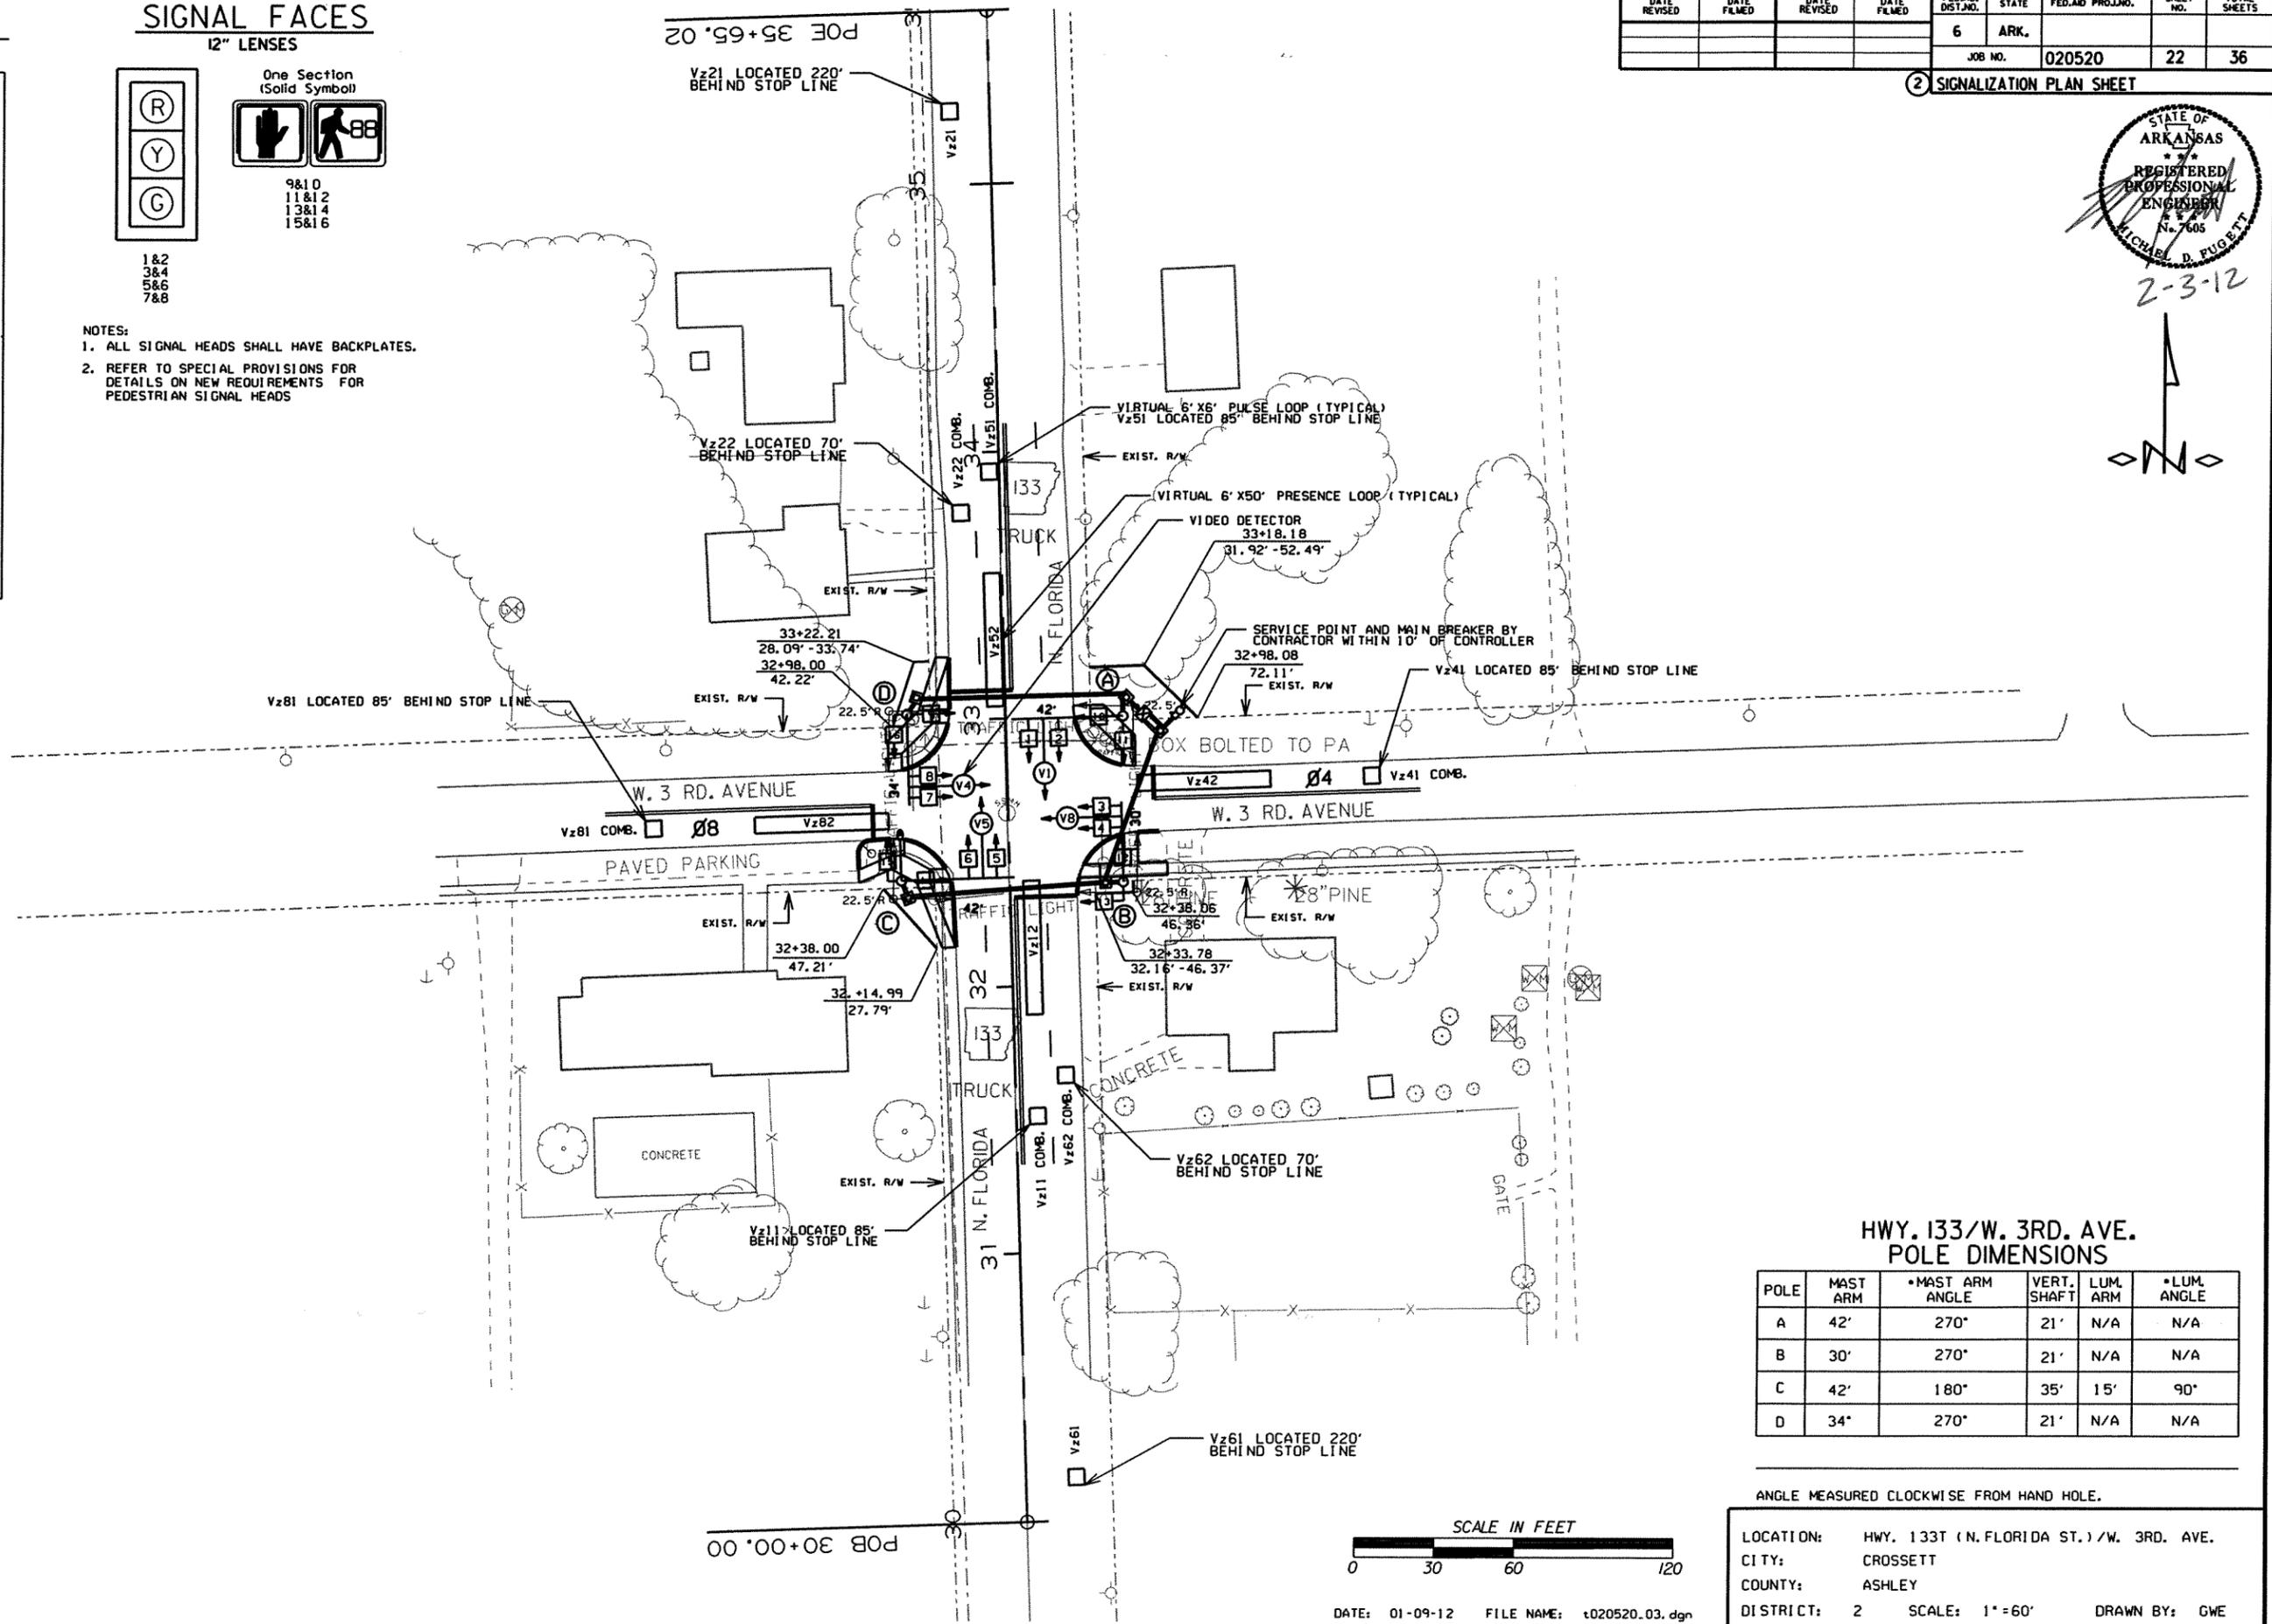


HWY. 133/W. 3RD. AVE.  
POLE DIMENSIONS

POLE	MAST ARM	MAST ARM ANGLE	VERT. SHAFT	LUM. ARM	LUM. ANGLE
A	42'	270°	21'	N/A	N/A
B	30'	270°	21'	N/A	N/A
C	42'	180°	35'	15'	90°
D	34'	270°	21'	N/A	N/A

ANGLE MEASURED CLOCKWISE FROM HAND HOLE.

 
LOCATION: HWY. 133 (N. FLORIDA ST.) / W. 3RD. AVE.  
CITY: CROSSETT  
COUNTY: ASHLEY  
DISTRICT: 2 SCALE: 1" = 60' DRAWN BY: GWE



DATE: 01-09-12 FILE NAME: t020520.03.dgn


1020520\_03.dgn 02-14-2011

**TRAFFIC FLOW DIAGRAM**

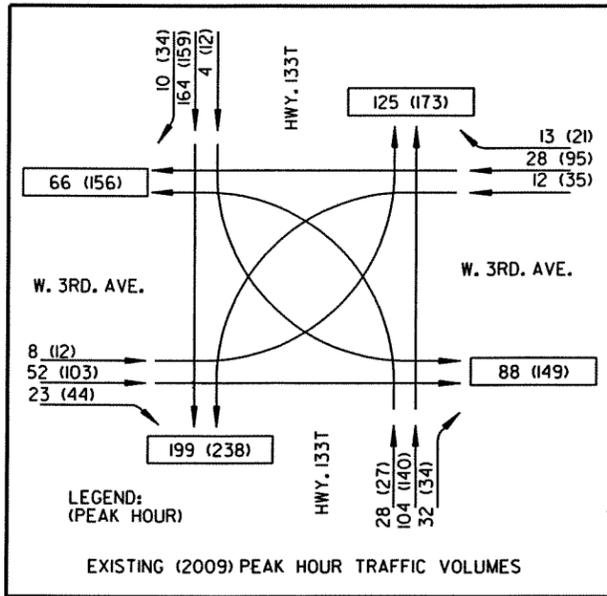

DATE REVISED	DATE FILMED	DATE REVISED	DATE FILMED	FED. RD. DIST. NO.	STATE	FED. AID PROJ. NO.	SHEET NO.	TOTAL SHEETS
				6	ARK.		23	36

2 SIGNALIZATION PLAN SHEET

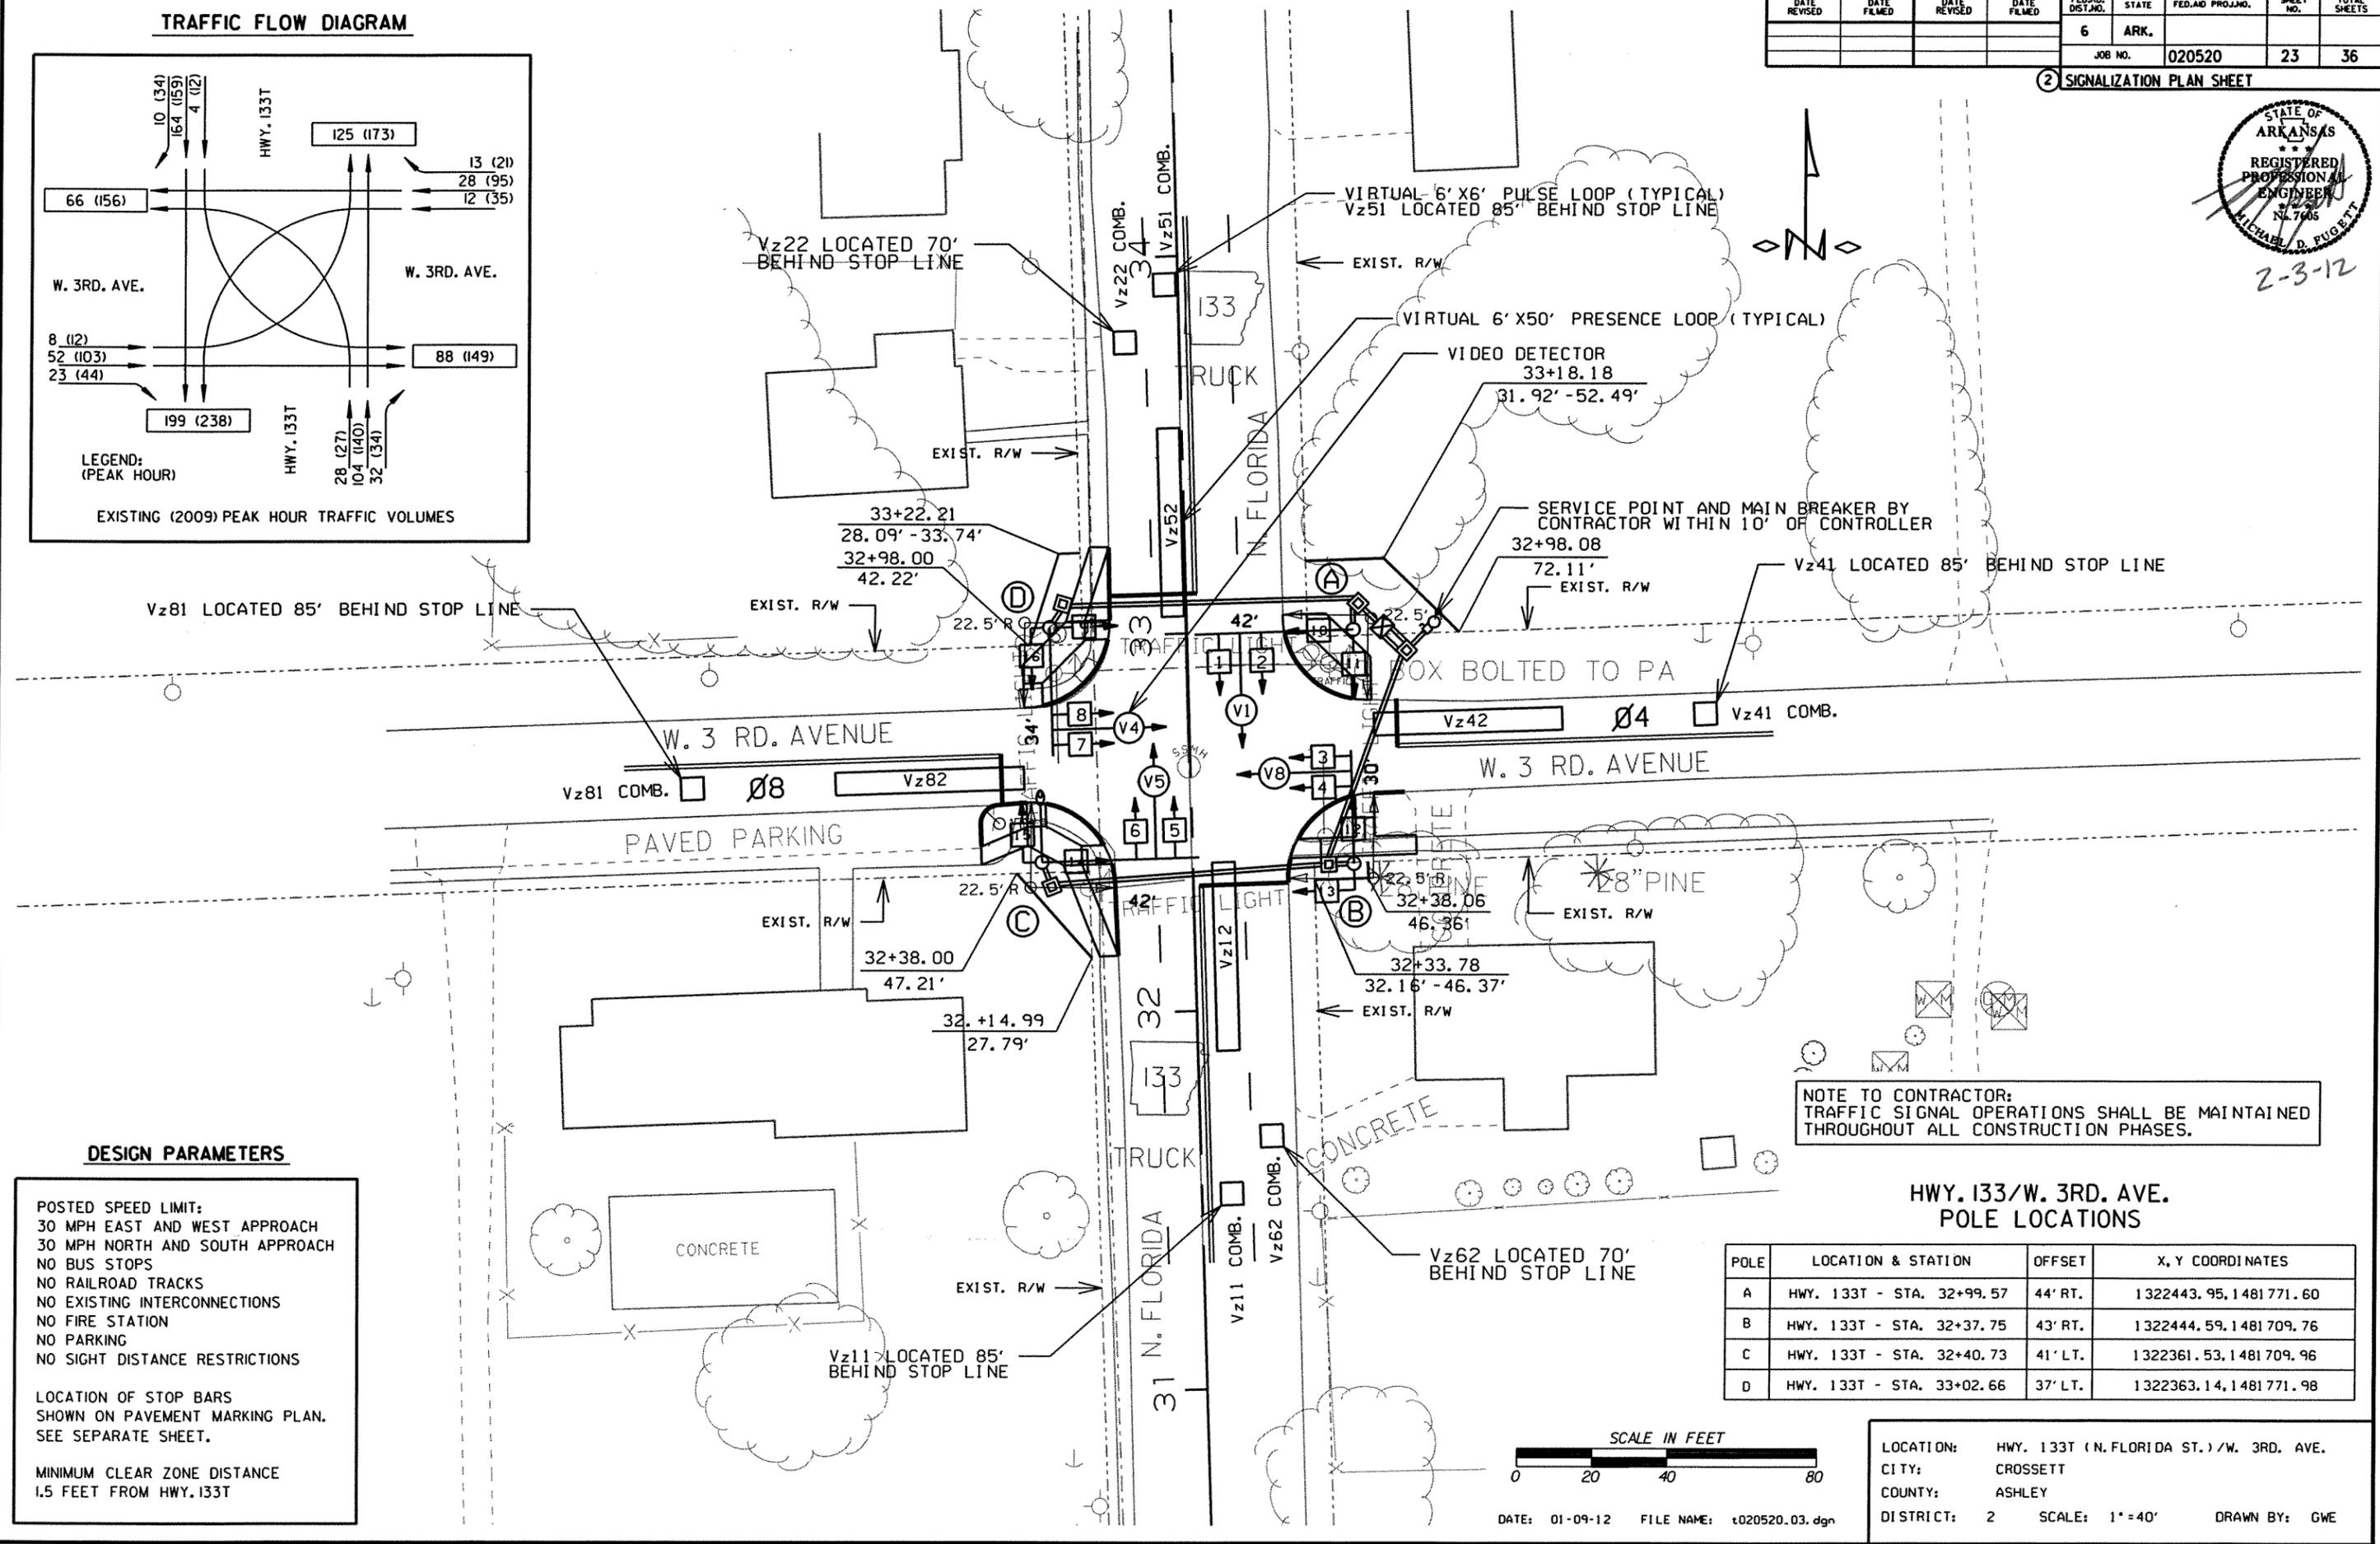

**DESIGN PARAMETERS**

 
POSTED SPEED LIMIT:  
30 MPH EAST AND WEST APPROACH  
30 MPH NORTH AND SOUTH APPROACH  
NO BUS STOPS  
NO RAILROAD TRACKS  
NO EXISTING INTERCONNECTIONS  
NO FIRE STATION  
NO PARKING  
NO SIGHT DISTANCE RESTRICTIONS

LOCATION OF STOP BARS  
SHOWN ON PAVEMENT MARKING PLAN.  
SEE SEPARATE SHEET.

MINIMUM CLEAR ZONE DISTANCE  
1.5 FEET FROM HWY. 133T

**HWY. 133/W. 3RD. AVE.  
POLE LOCATIONS**

POLE	LOCATION & STATION	OFFSET	X, Y COORDINATES
A	HWY. 133T - STA. 32+99.57	44' RT.	1322443.95, 1481771.60
B	HWY. 133T - STA. 32+37.75	43' RT.	1322444.59, 1481709.76
C	HWY. 133T - STA. 32+40.73	41' LT.	1322361.53, 1481709.96
D	HWY. 133T - STA. 33+02.66	37' LT.	1322363.14, 1481771.98




DATE: 01-09-12 FILE NAME: t020520.03.dgn

LOCATION: HWY. 133T (N. FLORIDA ST.) / W. 3RD. AVE.  
CITY: CROSSETT  
COUNTY: ASHLEY  
DISTRICT: 2 SCALE: 1" = 40' DRAWN BY: GWE

1020520\_03.dgn 02-14-2011

DATE REVISED	DATE FILMED	DATE REVISED	DATE FILMED	FED. RD. DIST. NO.	STATE	FED. AID PROJ. NO.	SHEET NO.	TOTAL SHEETS
				6	ARK.			
						JOB NO. 020520	24	36

2 SIGNALIZATION PLAN SHEET

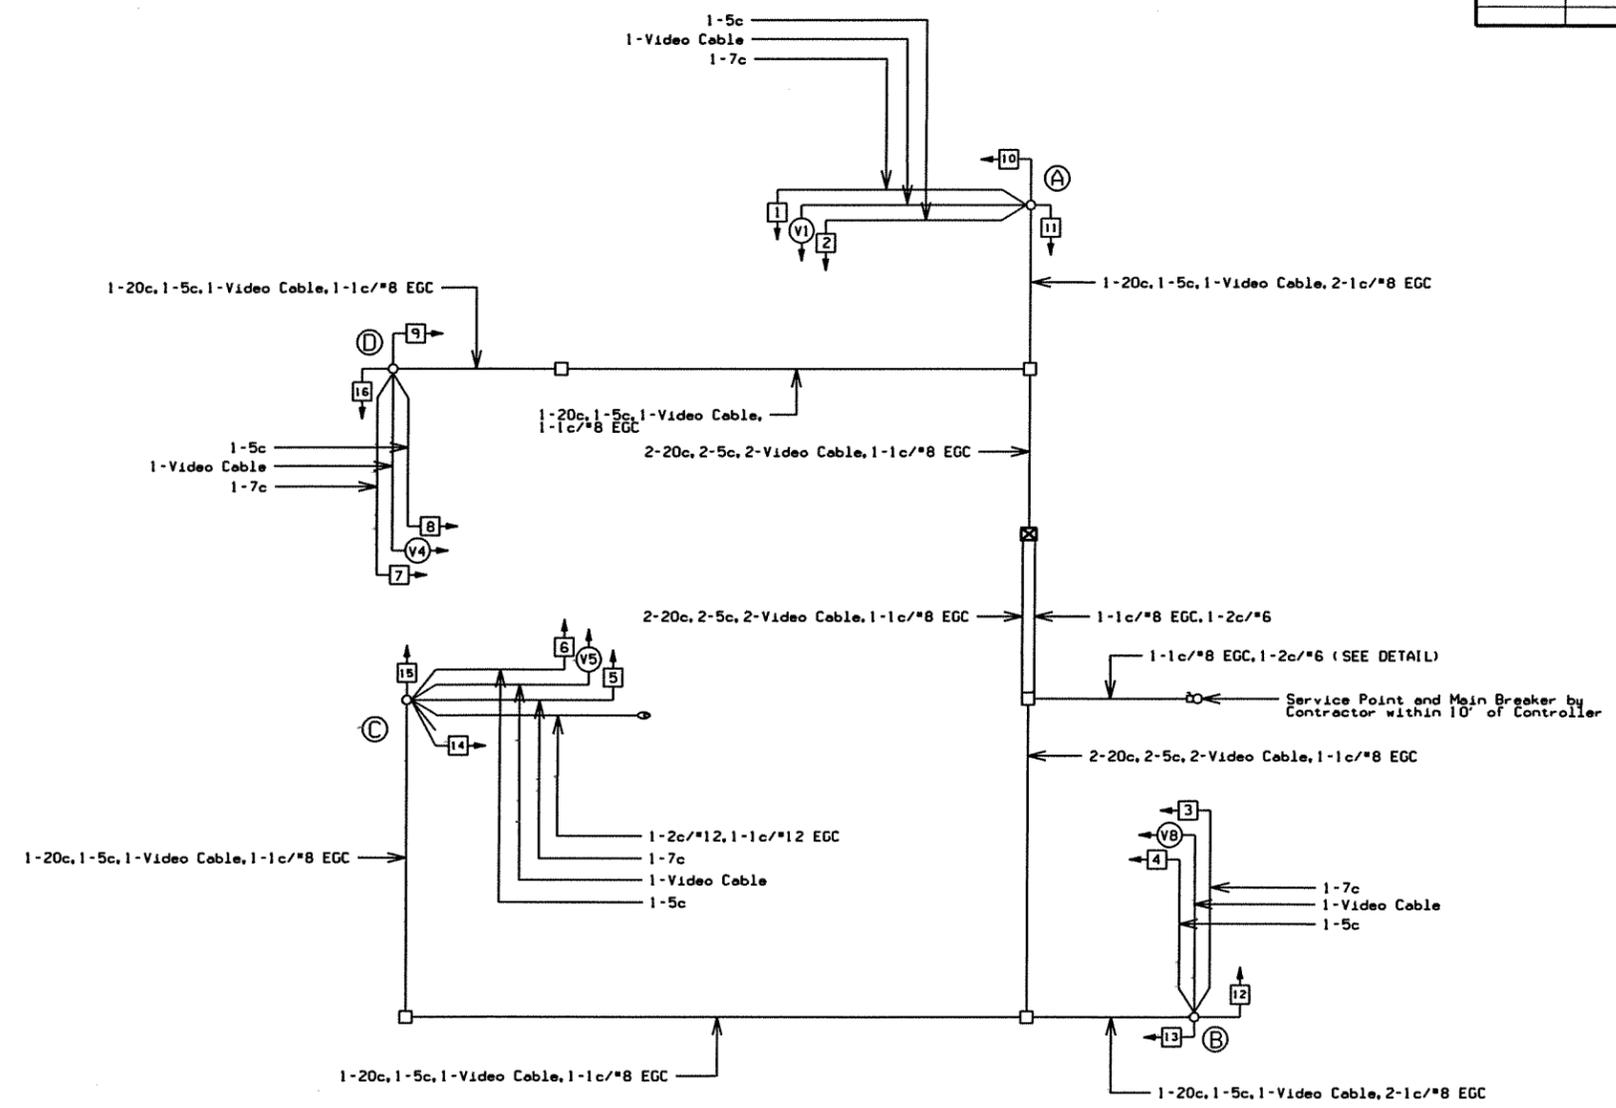

**DETECTOR SYSTEM DESCRIPTION: JOB 020520**

CROSSETT - HWY. 133T(N.FLORIDA ST.)/W.3RD.AVE. DETECTOR ASSIGNMENTS				HARDWARE INPUTS BY SUPPLIER			PROGRAM ASSIGNMENTS			COMMENTS	TUBE LENGTHS
DET. ID#	LOCATION DIRECTION	TYPE	DET. #	CAB. TRM. #	AMP. CHN. #	CON. INP. #	PHS	LOCAL SYSTEM DET. #	MASTER SYSTEM DETECTOR NUMBERS		
Vz11	NB LEFT TURN FAR	COMB.			1	D1	1	1		CAMERA V1	23'
Vz12	NB LEFT TURN	LOCAL			2	V1	1			CAMERA V1	23'
Vz21	SB ADVANCE	LOCAL			5	V2	2			CAMERA V5	74'
Vz22	SB NEAR	COMB.			6	D2	2	2		CAMERA V5	74'
Vz41	WB ADVANCE	COMB.			9	D4	4	4		CAMERA V4	23'
Vz42	WB NEAR	LOCAL			10	V4	4			CAMERA V4	23'
Vz51	SB LEFT TURN FAR	COMB.			7	D5	5	5		CAMERA V5	23'
Vz52	SB LEFT TURN	LOCAL			8	V5	5			CAMERA V5	23'
Vz61	NB ADVANCE	LOCAL			3	V6	6			CAMERA V1	74'
Vz62	NB NEAR	COMB.			4	D6	6	6		CAMERA V1	74'
Vz81	EB ADVANCE	COMB.			13	D8	8	8		CAMERA V8	23'
Vz82	EB NEAR	LOCAL			14	V8	8			CAMERA V8	23'
PB2A&B	W. 3RD. AVE. W. LEG	PED.				P2	2				
PB4A&B	HWY. 133 N. LEG	PED.				P4	4				
PB6A&B	E. 3RD. AVE. E. LEG	PED.				P6	6				
PB8A&B	HWY. 133 S. LEG	PED.				P8	8				
SPARE 11, 12, 15&16											

CONTROLLER INPUT ABBREVIATIONS:  
V = VEHICLE INPUT  
D = SYSTEM OR AUXILIARY INPUT  
P = PEDESTRIAN INPUT

### WIRING DIAGRAM

NOTES TO CONTRACTOR:

- ONE SEPARATE 1-5c IS RUN TO EACH POLE FOR THE PEDESTRIAN PUSH BUTTON.
- ALL DETECTOR RACK CHANNELS, INCLUDING UNUSED, SHALL BE BROUGHT TO TERMINAL STRIP IN DETECTOR AREA OF CABINET.
- THE LOCAL GOVERNMENT SHALL BE RESPONSIBLE FOR PROVIDING POWER TO THE SERVICE POINT.

### INTERVAL CHART

SIGNAL FACES	HWY. 133T/W.3RD. AVE.			FLASH SEQ.
	2+6	CLR. 4+8	CLR.	
1&2	G	**	R R	R
3&4	R	R	G **	R
5&6	G	**	R R	R
7&8	R	R	G **	R
9&10	DW	DW	W FDW	BLK
11&12	W	FDW	DW DW	BLK
13&14	DW	DW	W FDW	BLK
15&16	W	FDW	DW DW	BLK

\*\* DENOTES GREEN OR YELLOW BALL DEPENDING ON NEXT PHASE




LOCATION: HWY. 133T (N.FLORIDA ST.)/W. 3RD. AVE.  
CITY: CROSSETT  
COUNTY: ASHLEY  
DISTRICT: 2 SCALE: N/A DRAWN BY: GWE

DATE REVISED	DATE FILMED	DATE REVISED	DATE FILMED	FED. RD. DIST. NO.	STATE	FED. AID PROJ. NO.	SHEET NO.	TOTAL SHEETS
				6	ARK.			
JOB NO. 020520							25	36


② SIGNALIZATION DETAILS




DRAWER PLAN VIEW

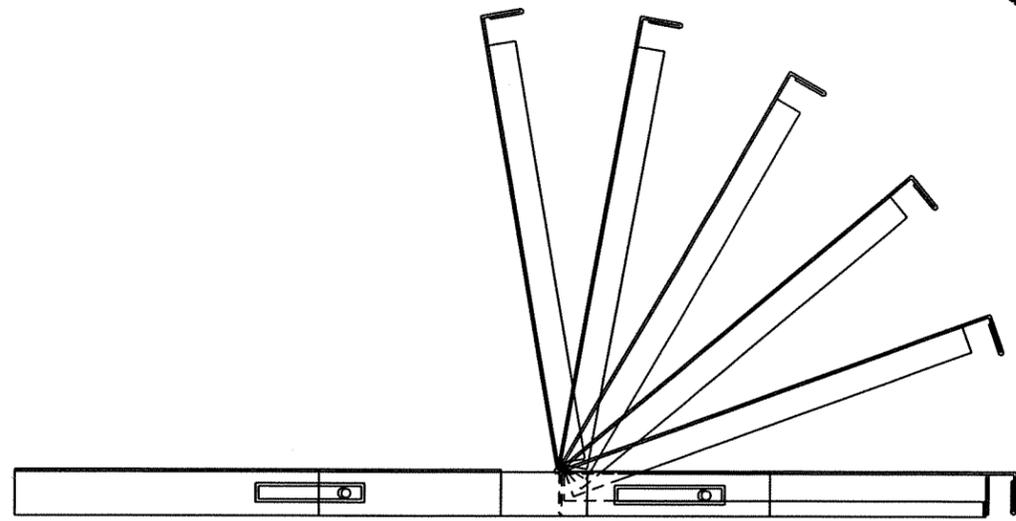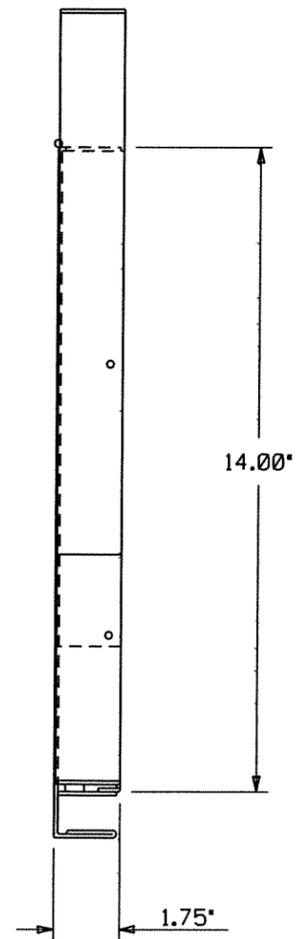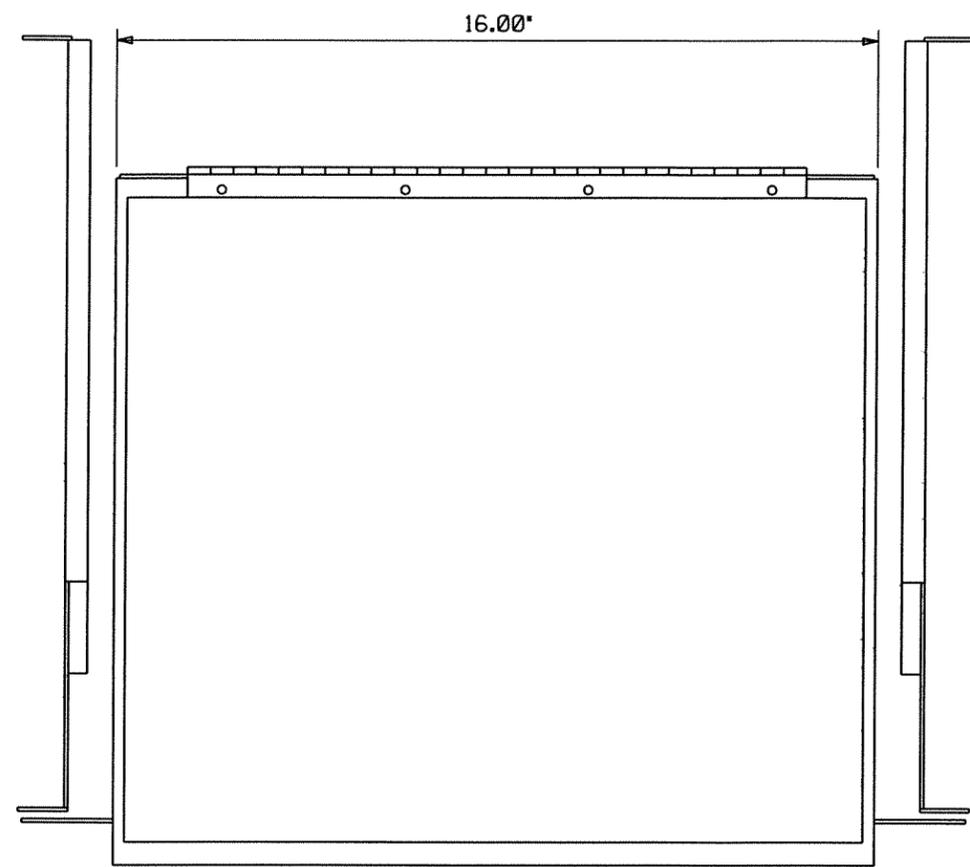

 - NOTES:  
 1. RIGHT HAND SLIDE SHOWN, LEFT SLIDE OPPOSITE.  
 2. GENERAL DEVICES (CC3002-99-D102) OR EQUAL AND CONTAINS (1) RIGHT HAND SLIDE ASSEMBLY, (1) LEFT HAND SLIDE ASSEMBLY.  
 3. ALL HARDWARE NECESSARY TO FASTEN SLIDE ASSEMBLY TO UNDERSIDE OF CONTROLLER SHELF SHALL BE INCLUDED.



FRONT VIEW

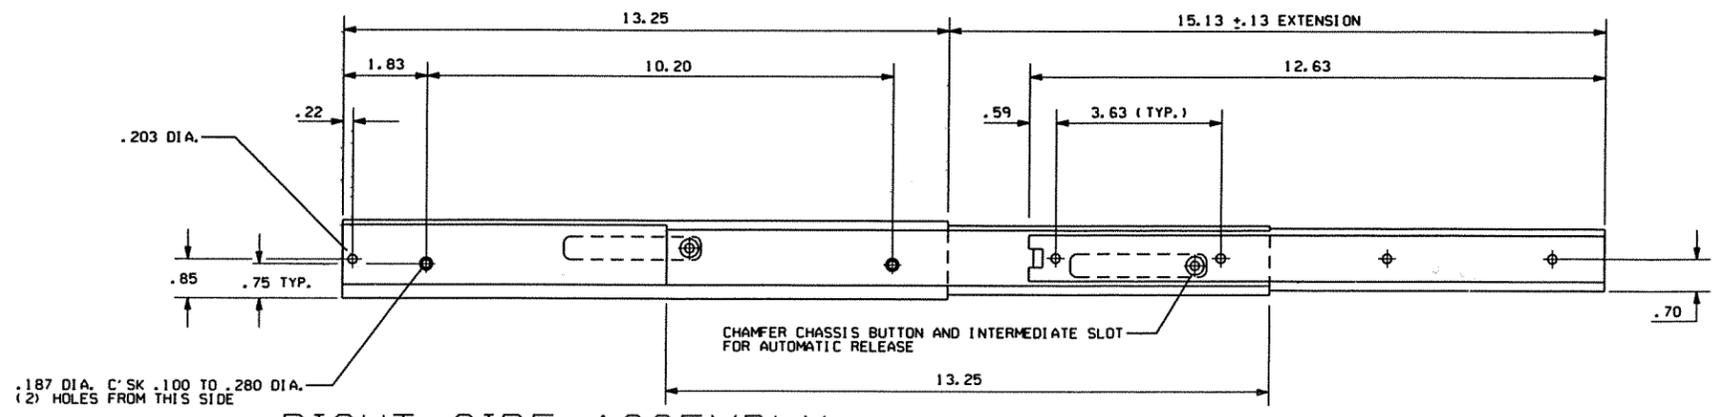

RIGHT SIDE ASSEMBLY

DATE	REVISION	DATE FILM	ARIZONA STATE HIGHWAY COMMISSION
6-15-05	ISSUED		SIGNALIZATION DETAIL (Controller Cabinet Utility Drawer)


DATE REVISED	DATE FILMED	DATE REVISED	DATE FILMED	FED. RD. DIST. NO.	STATE	FED. AID PROJ. NO.	SHEET NO.	TOTAL SHEETS
				6	ARK.			
JOB NO. 020520							26	36

2 SIGNALIZATION DETAILS




2-3-12


### CONDUIT ENTRY TO EXISTING POLE BASE

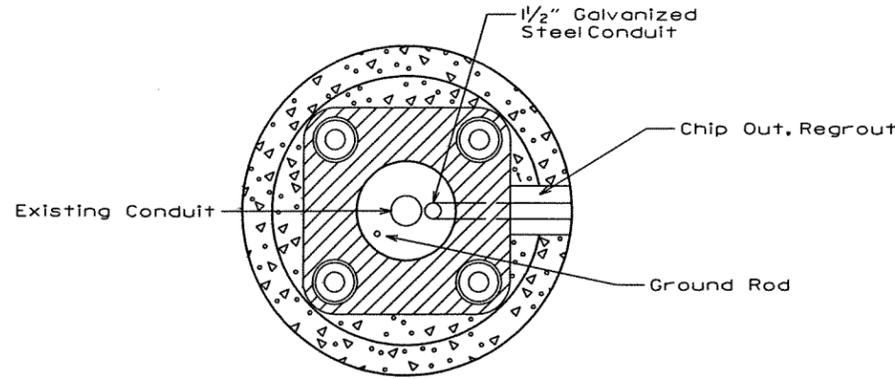


### ANCHOR BASE

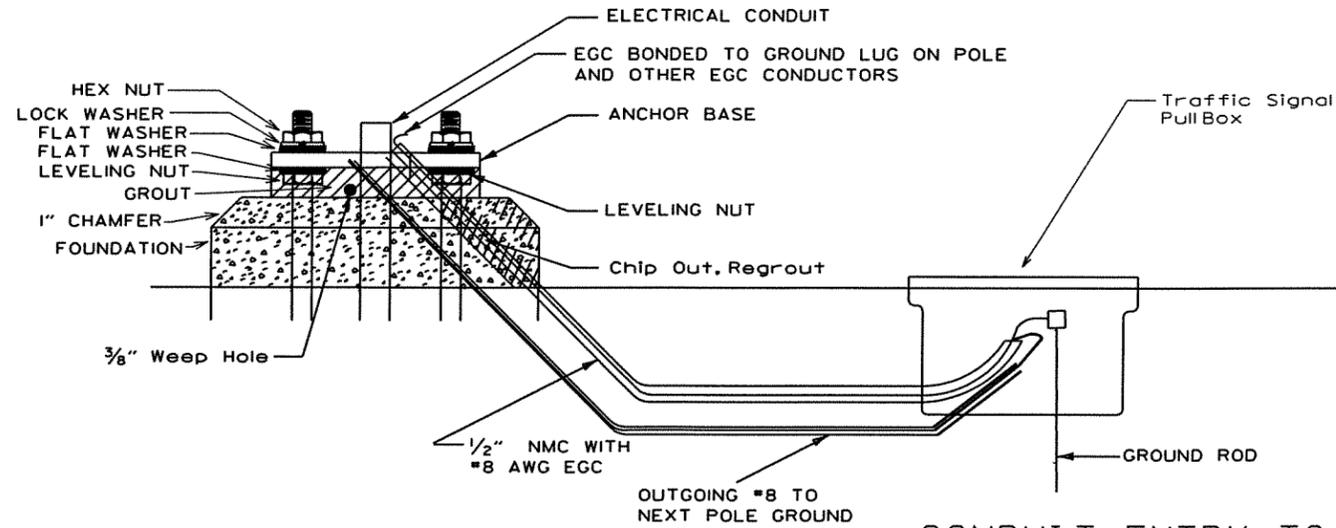

### CONDUIT ENTRY TO EXISTING CONTROLLER CABINET

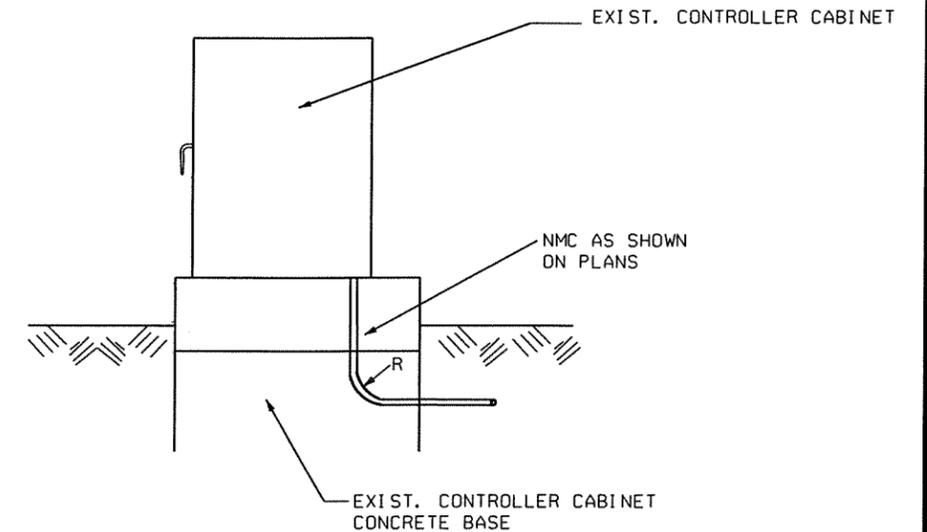


NOTE: ENTRY TO CABINET SHALL BE THROUGH A CUT IN THE BASE SUFFICIENT TO PROVIDE ADEQUATE CONDUIT RADIUS FOR ITEM.

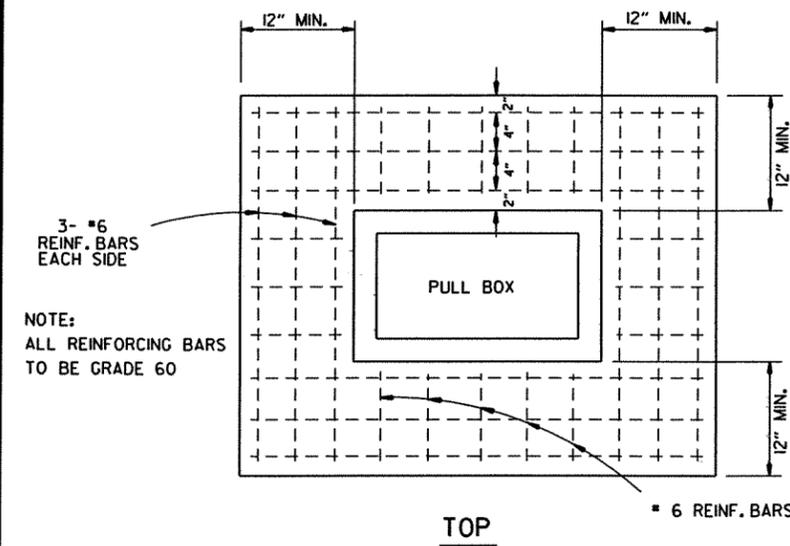

3- #6 REINF. BARS EACH SIDE


NOTE: ALL REINFORCING BARS TO BE GRADE 60

TOP

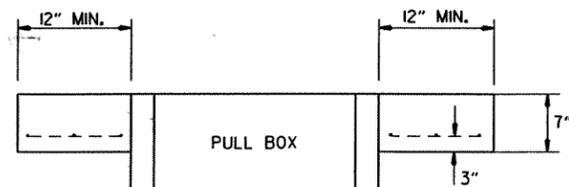

ELEVATION

### Type "HD" Concrete Pull Box Detail

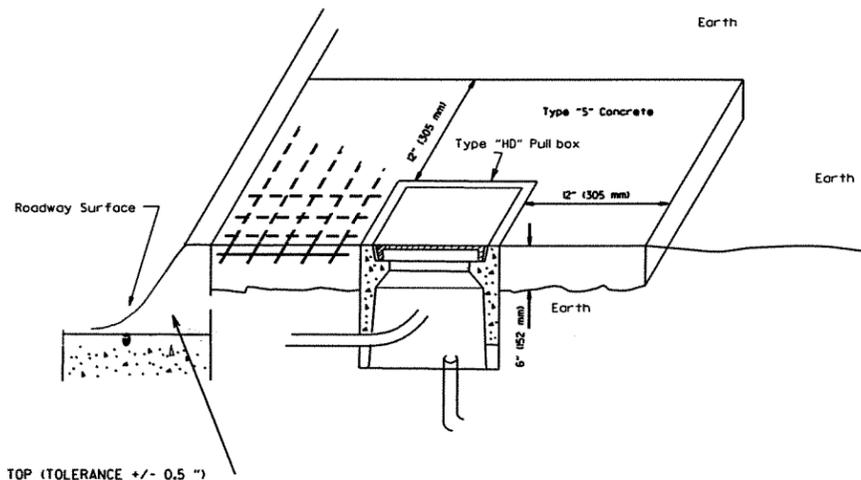

Note: All Type 1 and Type 2 HD pullboxes are installed with an apron of concrete 12" (305 mm) wide and 6" (152 mm) in depth. All payment shall be included in the price of the Type HD pullbox. Pullbox shall be installed flush to surrounding grade unless otherwise instructed by the engineer. The concrete shall be Class "S." Three #6 reinforcing bars in the apron on all sides of the pull box is required in concrete.

DATE	REVISION	DATE FILM
5-21-09	REVISED GROUNDING	
7-31-08	ADDED & REVISED CONDUIT ENTRY	
6-23-04	REVISED CLEARANCE AT CURB ENTRY	
1-4-02	ADDED REINFORCING TO BOX APRON	
7-2-01	REVISED	
12-27-99	REVISED NOTES	
11-18-98	ISSUED	


ARKANSAS STATE HIGHWAY COMMISSION

SIGNALIZATION DETAIL  
(Heavy Duty Pull Box)

# MAIN BREAKER NOT NEAR CONTROLLER CABINET SECONDARY REQUIRED

WITH POWER ISOLATION ASSEMBLY

WITHOUT POWER ISOLATION ASSEMBLY

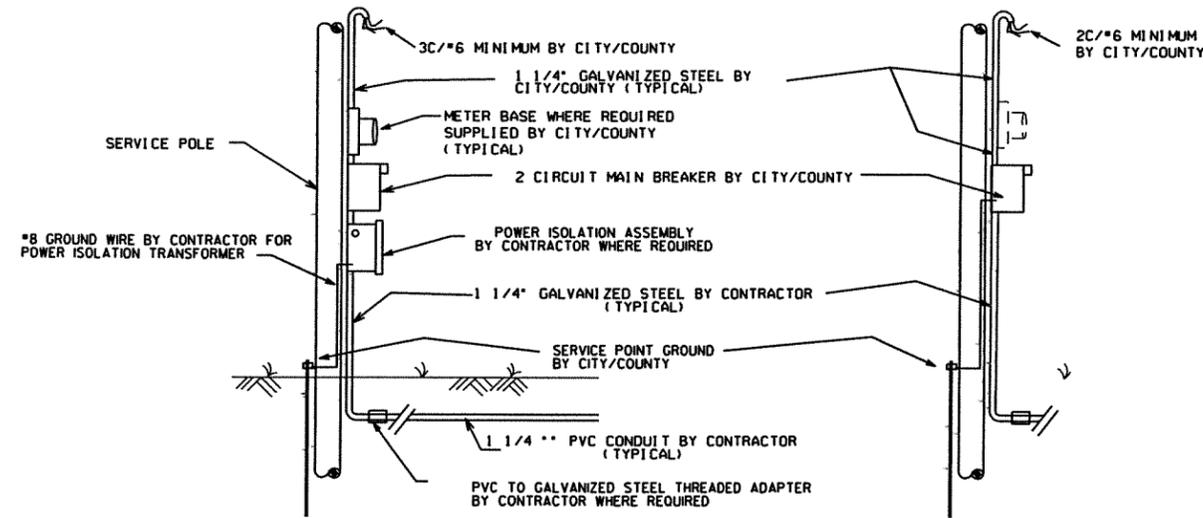

## NOTES TO CONTRACTOR AND AGENCY RESPONSIBLE FOR MAINTENANCE OF THE INTERSECTION (CITY/COUNTY)



Electrical service typically falls into two categories: MAIN BREAKER NEAR CONTROLLER CABINET; and MAIN BREAKER NOT NEAR CONTROLLER CABINET. The Contractor's and the City's or County's responsibility varies accordingly as indicated on these details.

1. ALL SITUATIONS: Electrical service shall be provided by the City/County to a service pole with external raintight breaker (MAIN BREAKER) at a mutually acceptable point within the right-of-way. Service point includes galvanized steel conduit to a point 18' below ground line, two circuit main breaker, power isolation assembly where required, meter loop if required by local utility, electrical conductors and weatherhead. Where street lighting is included as part of signal installation, street lighting circuit (2c/#12 awg UF rated, typical) shall be kept separate from the circuit serving traffic signal. Service wire and wiring from the controller to main breaker is provided by the Contractor as a part of this contract. Wire and wiring from main breaker, and connection to the utility is the responsibility of the City/County.

2. MAIN BREAKER NOT NEAR CONTROLLER CABINET: The Main Breaker assembly, galvanized steel conduit, weatherhead and wire above Main Breaker and connection to the utility shall be provided by City/County. Contractor shall provide as part of contract Secondary Breaker, conduit, wire and wiring to the Main Breaker.

3. MAIN BREAKER NEAR CONTROLLER CABINET: All components of the service point with the exception of the wire and wiring above the Main Breaker is furnished and installed by the Contractor. Wiring from Main Breaker including connection to the utility, is the responsibility of the City/County. If meter loop is required, meter base and hardware is provided by the City/County and installed by the contractor.

# MAIN BREAKER NEAR CONTROLLER CABINET SECONDARY NOT REQUIRED

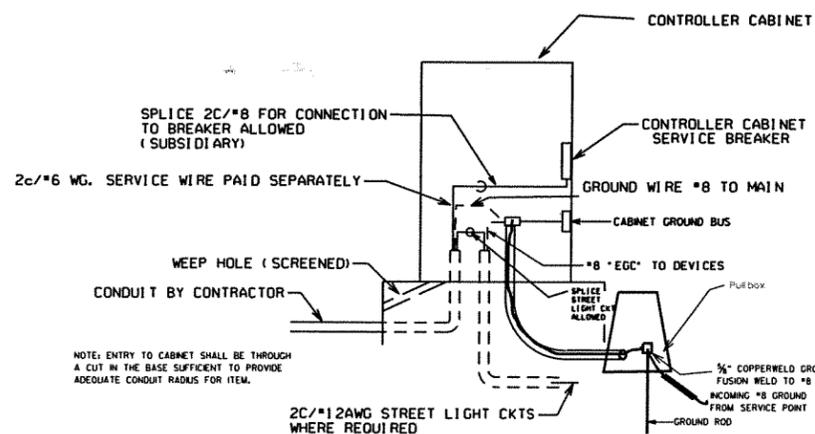
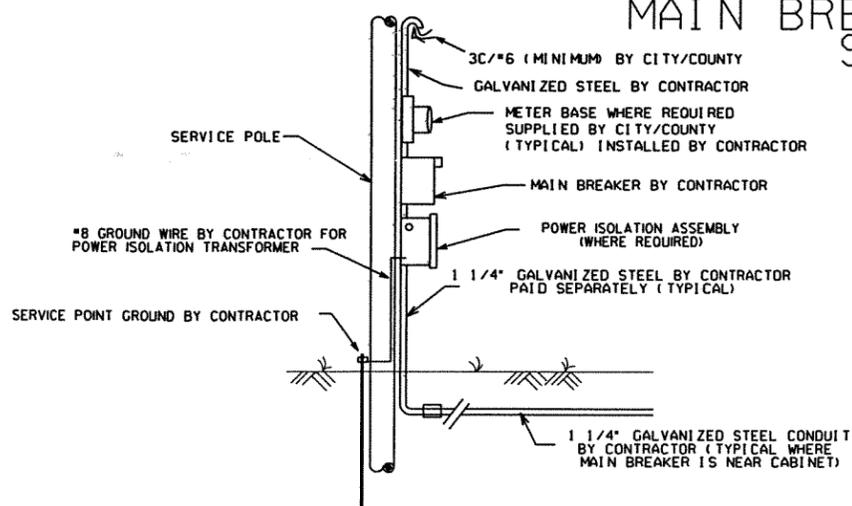


Ground Rod-A 10' x 3/4" ground rod shall be installed in the pull box for each pole and the controller. Payment for the ground rod and 1/2" NMC shall be included in item 701. The pull box and conductor box shall be paid for separately.

DATE REVISED	DATE FILMED	DATE REVISED	DATE FILMED	FED. RD. DIST. NO.	STATE	FED. AID PROJ. NO.	SHEET NO.	TOTAL SHEETS
				6	ARK.			
JOB NO. 020520							27	36

## 2 SIGNALIZATION DETAILS

### SECONDARY BREAKER BY CONTRACTOR (SUBSIDIARY)

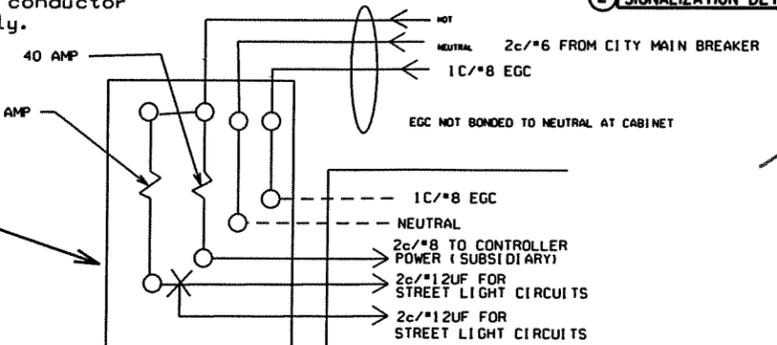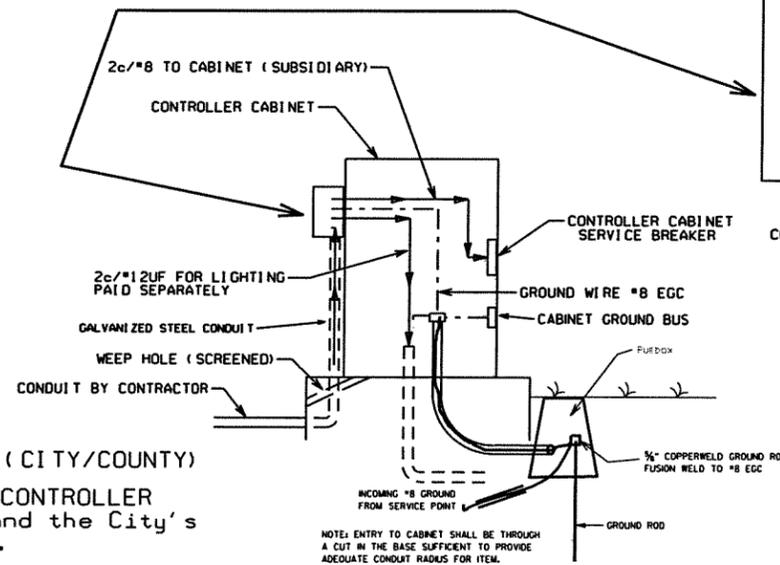


## MAIN BREAKER WIRING (TYPICAL)

Service Ground is typically tied to neutral at the Main Breaker. As such, controller ground IS NOT tied to Neutral at secondary Breaker or in controller cabinet.

WITH POWER ISOLATION ASSEMBLY  
4 CIRCUIT MAIN BREAKER

WITHOUT POWER ISOLATION ASSEMBLY  
2 CIRCUIT MAIN BREAKER

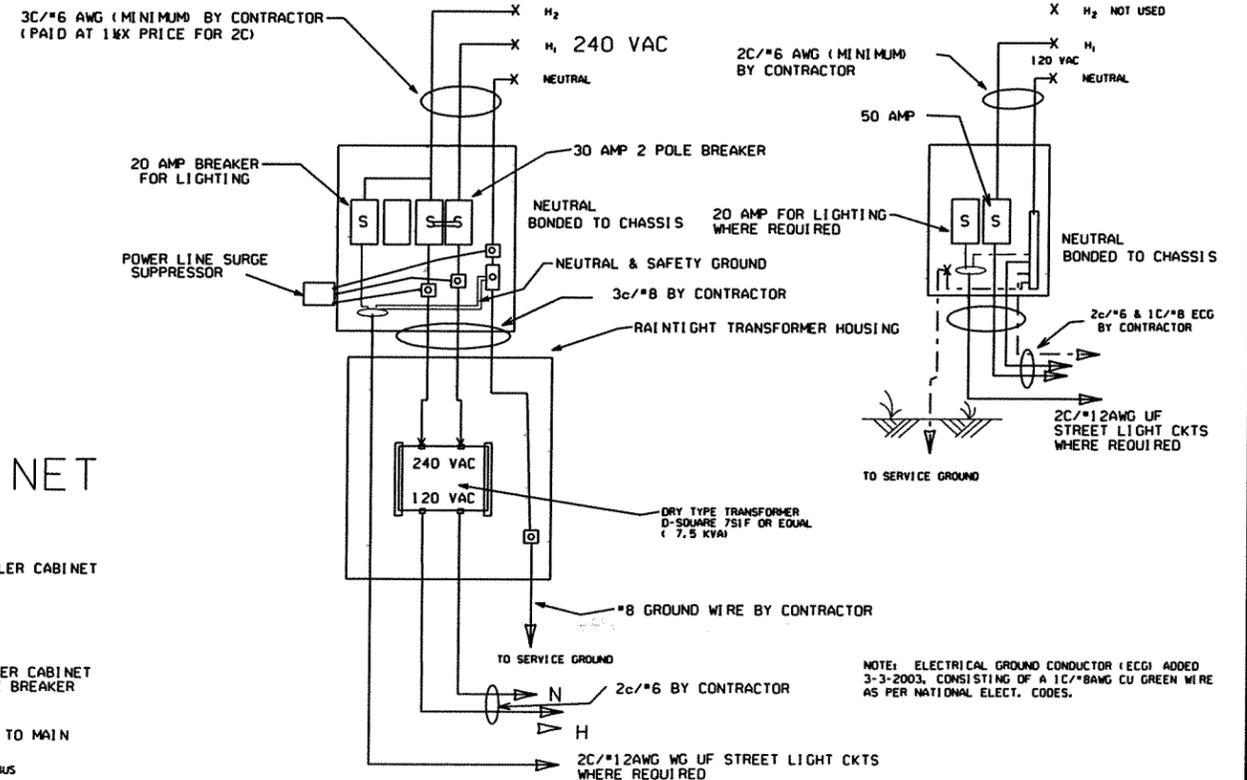

DATE	REVISION	DATE FILM
5-21-09	REVISED GROUNDING	
7-31-08	REVISED GROUNDING	
3-3-03	ADDED EGC NOTE	
9-26-01	REVISED	
12-27-99	REVISED	
7-28-99	REVISED	
2-5-99	ISSUED	









ARKANSAS STATE HIGHWAY COMMISSION

## SIGNALIZATION DETAIL (Service Point)



DATE REVISED	DATE FILMED	DATE REVISED	DATE FILMED	FED. RD. DIST. NO.	STATE	FED. AID PROJ. NO.	SHEET NO.	TOTAL SHEETS
				6	ARK.			
JOB NO.						020520	28	36


2 SIGNALIZATION DETAILS

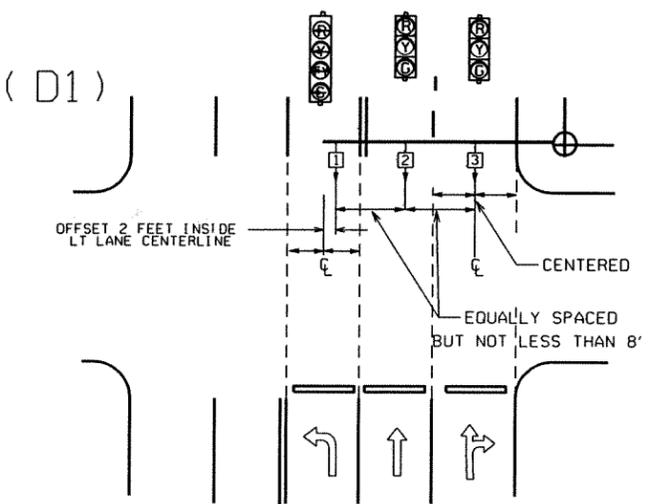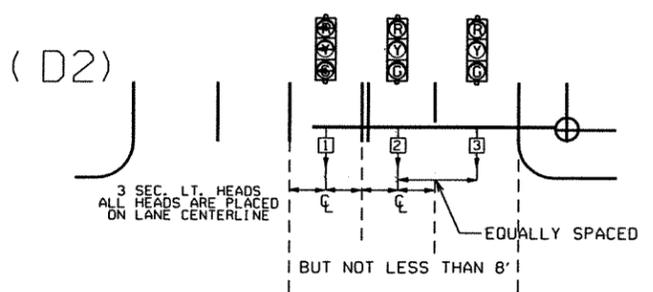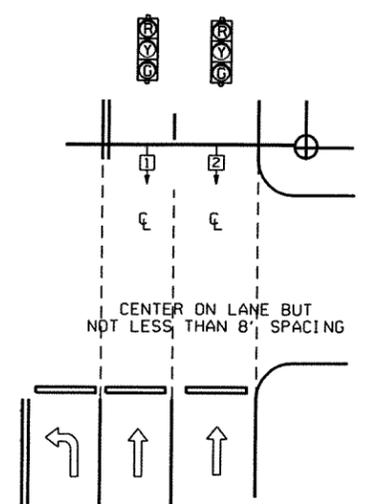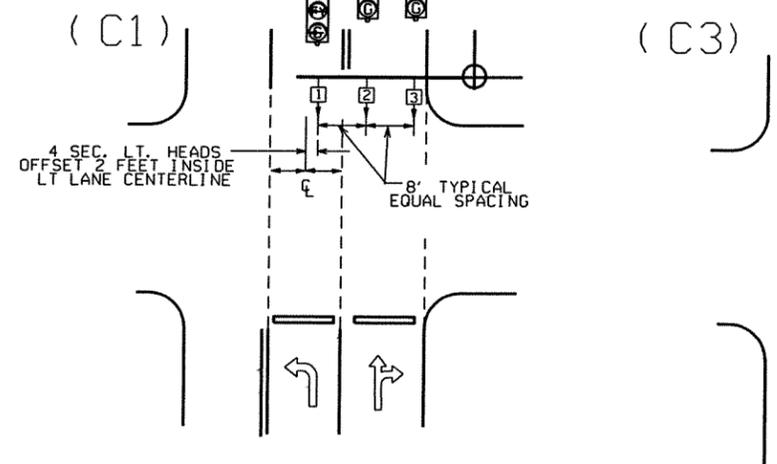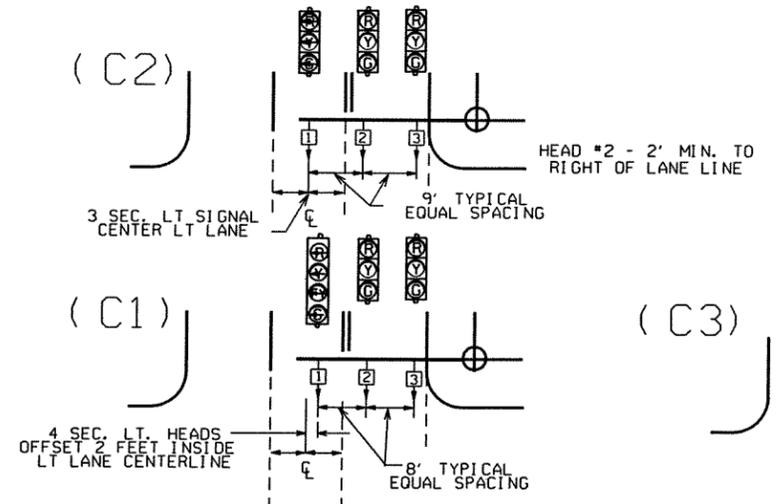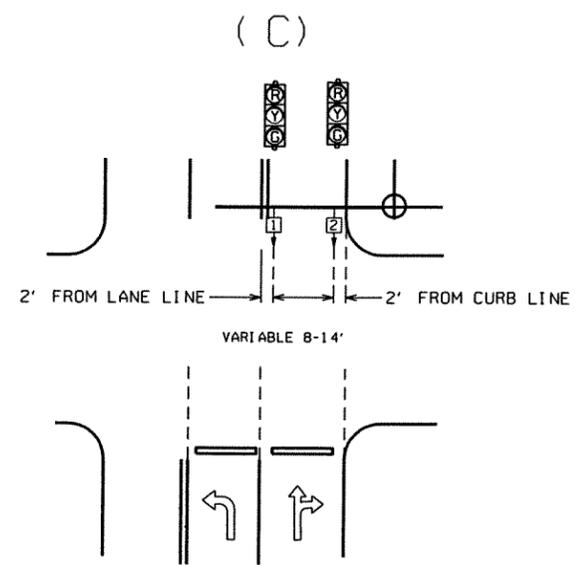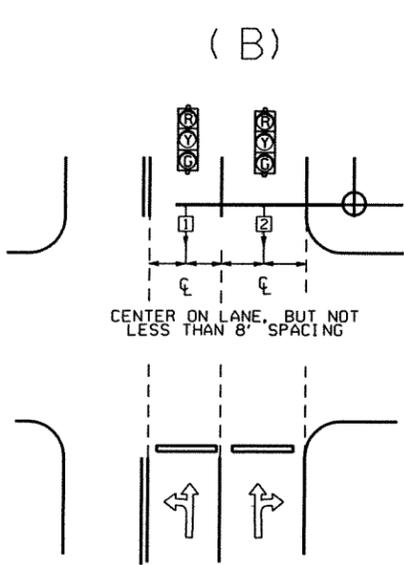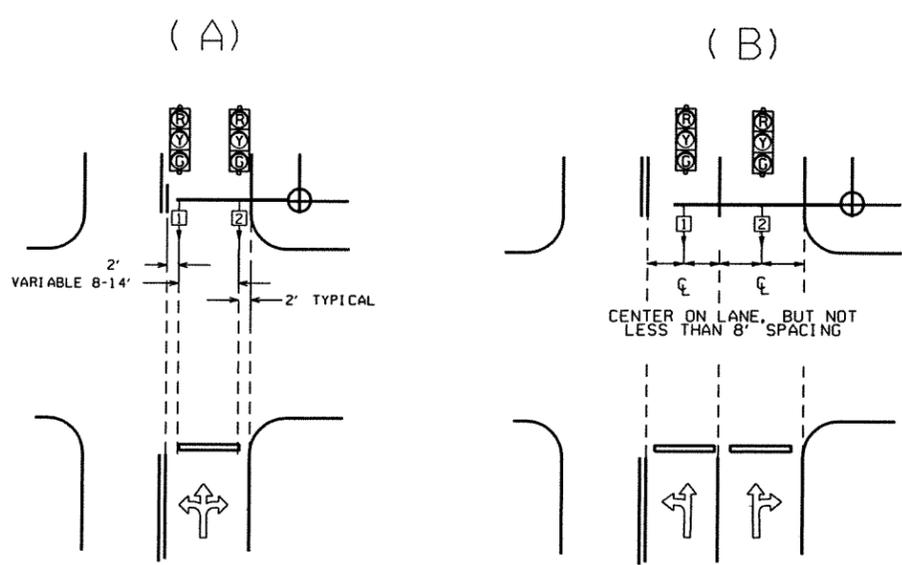

NOTE: WHERE LEFT TURN HEAD (HEAD 1 ON D1 AND D2) IS NOT CALLED FOR ON PLANS, MAST ARM LENGTH MAY STILL BE ALLOWED FOR FUTURE INSTALLATION. HEADS FOR THROUGH MOVEMENTS SHALL STILL BE ALIGNED WITH THROUGH LANES AS SHOWN ON DETAILS

GENERAL NOTES:

- FOUR SECTION "PROTECTED/PERMISSIVE" LEFT TURN HEADS SHOULD BE PLACED A MINIMUM OF TWO (2') FEET TO THE RIGHT OF THE CENTERLINE OF THE APPROACHING LEFT TURN LANE.
- THREE SECTION "PROTECTED" LEFT TURN HEADS SHOULD BE PLACED ON THE CENTERLINE OF THE APPROACHING LEFT TURN LANE.
- WHEN IT IS NECESSARY TO PLACE POLES OTHER THAN AS SHOWN ON PLAN SHEET(S) RESULTING IN MAST ARM EXTENDING MORE THAN TWO FEET PAST (TO THE LEFT OF) THE CENTERLINE OF THE APPROACHING LEFT TURN LANE, MAST ARM SHALL BE CUT TO APPROPRIATE LENGTH AS DETERMINED BY THE ENGINEER, AND A NEW END CAP PROVIDED. THE CONTRACTOR SHALL BE RESPONSIBLE FOR DETERMINING THIS PRIOR TO INSTALLING THE MAST ARM IF ADDITIONAL COMPENSATION IS REQUIRED.
- SIGNAL HEAD SPACING SHALL, IN NO CASE, BE LESS THAN EIGHT (8') FEET BETWEEN HEADS ON CENTER, MEASURED HORIZONTALLY PERPENDICULAR TO THE APPROACH.
- ALL SIGNAL HEADS SHOWN ON THIS DETAIL SHEET SHALL BE LOCATED ACCORDING TO THE DIMENSIONS SHOWN IN RELATION TO THE APPROACH SIDE OF THE INTERSECTION.
- MAXIMUM MOUNTING HEIGHT OF SIGNAL FACES LOCATED BETWEEN 40 FEET AND 53 FEET FROM STOP BAR SHALL BE IN ACCORDANCE WITH FIGURE 4D-1 OF 2009 MUTCD.

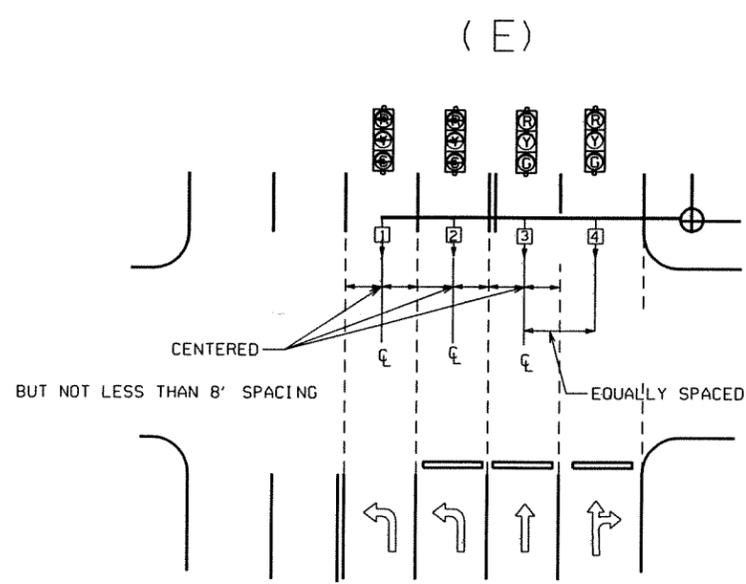

℄ = CENTER OF LANE FROM APPROACH SIDE

DATE	REVISION	DATE FILM	ARKANSAS STATE HIGHWAY COMMISSION
3-11-10	2009 MUTCD		SIGNALIZATION DETAIL (Signal Head Placement)
12-9-99	ISSUED		

NOTES, PED AND TRAFFIC SIGNAL HEAD SIGNS:  
EACH ITEM TRAFFIC SIGNAL HEAD (4 SEC., 1-WAY)\* SHALL INCLUDE A SPECIAL SIGN AS SHOWN, ATTACHED TO THE MAST ARM OR SPAN ASSEMBLY 12' TO THE RIGHT OF THE SIGNAL HEAD UNLESS REMOVED WITHIN THE SIGNAL PLAN NOTES.

EACH ITEM TRAFFIC SIGNAL HEAD (3 SEC., 1-WAY)\* TO BE USED AS A LEFT TURN INDICATION ONLY SHALL INCLUDE A SIGN (R10-10) AS SHOWN, ATTACHED TO THE MAST ARM OR SPAN ASSEMBLY 12' TO THE RIGHT OF THE SIGNAL HEAD.

EACH PEDESTRIAN PUSH-BUTTON SHALL HAVE ONE R10-3E SIGN ATTACHED TO THE POLE ABOVE THE BUTTON. ALL SIGN FACES SHALL BE CONSTRUCTED OF HIGH INTENSITY SHEETING (TYPE III) WITH SILKSCREEN LEGEND AND BORDER.

ALL SIGN BLANKS SHALL BE CONSTRUCTED OF ALUMINUM ALLOY (ASTM DESIGNATION B-209, ALLOY 5052-H38) WITH THICKNESS OF 0.100 INCH.

GENERAL NOTES:  
1. MAST ARM POLES SHALL BE MOUNTED A MINIMUM OF 4 FT. BEHIND CURB OR SHOULDER.

2. OCTAGONAL POLES AND ARMS MEETING THE REQUIREMENTS OF THE PLANS AND SPECIFICATIONS CAN BE INSTALLED IN LIEU OF ROUND. ALL POLES AND ARMS IN A JOB MUST BE THE SAME SHAPE.

3. MINIMUM STRUCTURAL REQUIREMENTS: DESIGN SPECIFICATIONS: AASHTO STANDARD SPECIFICATIONS FOR STRUCTURAL SUPPORTS FOR HIGHWAY SIGNS, LUMINAIRES AND TRAFFIC SIGNALS, 4TH EDITION (2001) WITH 2003 AND 2006 INTERIMS.

USE FATIGUE CATEGORY I FOR ALL STRUCTURES ON ROUTES WHERE THE SPEED LIMIT IS 65 MPH AND GREATER AT THE STRUCTURE LOCATION AND ON ROUTES WHERE SPEED LIMIT IS GREATER THAN 45 MPH WITH AN ARM 60' OR LONGER.

USE FATIGUE CATEGORY II FOR STRUCTURES ON ROUTES WITH A SPEED LIMIT LESS THAN 65 MPH AND GREATER THAN 45 MPH WITH ARMS LESS THAN 60' AND ROUTES WITH SPEED LIMITS OF 45 MPH AND LESS WITH AN ARM 60' OR LONGER.

USE FATIGUE CATEGORY III FOR ALL STRUCTURES WHERE SPEED LIMIT IS 45 MPH AND LESS AND ARMS LESS THAN 60'.

CONSTRUCTION SPECIFICATIONS: ARKANSAS STATE HIGHWAY AND TRANSPORTATION DEPARTMENT STANDARD SPECIFICATIONS FOR HIGHWAY CONSTRUCTION (2003 EDITION) WITH APPLICABLE SUPPLEMENTAL SPECIFICATIONS AND SPECIAL PROVISIONS.

BASE WIND SPEED: 90 MPH.

STEEL MEMBERS CONSIDERED MAIN LOAD CARRYING MEMBERS WITH A THICKNESS GREATER THAN 1/2" SHALL MEET THE LONGITUDINAL CHIPPY V-NOTCH TEST SPECIFIED IN SUBSECTION 807.05 OF THE STANDARD SPECIFICATIONS.

DEAD LOAD: AS A MINIMUM, DESIGN SHALL BE BASED ON THE FIXED ATTACHMENTS SHOWN BELOW OR AS MODIFIED IN THE PLANS.

ALL SIGNAL HEADS TO BE ONE WAY, 12 INCH, AND HAVE 5 IN. BACK PLATES.

HEADS AT END OF ARM - ONE 4 SEC., 85 LB., 16.0 SQ. FT. ONE SIGN MOUNTED 3 FT. FROM SIGNAL \* 2' X 0' X 2' \* 6", 20 LB. REMAINING HEADS SPACED 8 FT. \* 3 SEC., 56 LB., TWO 5 SEC.)

14.4 SQ. FT. DESIGN TO ACCOMMODATE (INCLUDING 2 HEADS FOR ARMS 10 TO 16 FT., 2 HEADS FOR ARMS 10 TO 16 FT., INCLUDING LB., 3 HEADS FOR 18 TO 24 FT. ARMS, 4 HEADS FOR OVER 26 FT. ARMS.

STREET NAME SIGN -- 72" X 18", 36 LB., MOUNTED SUCH THAT OUTSIDE EDGE IS NOT GREATER THAN 12 FT. FROM POLE. DEPENDING UPON POSITION OF SIGNAL HEAD ADJACENT TO POLE, SIGN MAY OVERLAP POLE SHAFT

ROADWAY LUMINAIRES (WHERE REQUIRED ON PLAN SHEET) \* VARIABLE ARM LENGTH (MAX.), 3.3 SQ. FT., 75 LB. PED SIGNALS -- TWO 2 SEC. 12 INCH MOUNTED 8 FT. FROM BASE OF POLE. POST MOUNTED 3 SEC. SIGNAL HEAD AT 10 FT. ON SIDE OF POLE.


4. POLE/MAST ARM CAP -- POLE AND MAST ARMS CAPS SHALL BE PROVIDED, FABRICATED OF EITHER STEEL OR CAST ALUMINUM.

5. HAND HOLE -- HAND HOLES SHALL BE 4 X 6 INCHES FOR STANDARD, AND 3 X 5 INCHES FOR PED POLES, MINIMUM PLACED APPROXIMATELY 12 INCHES FROM BASE, AND SHALL BE FIXED WITH A BOLT DOWN COVER. A VACUUM FORMED ABS COVER IS AN ACCEPTABLE ALTERNATE TO STEEL. POLES GREATER THAN 21 FT. IN HEIGHT (FOR ROADWAY LUMINAIRE ATTACHMENT) SHALL INCLUDE A HAND HOLE WITHIN 12 INCHES OF MAST ARM(S) ATTACHMENT(S).

6. POLE/MAST ARM TAPER AND SLOPE - AVERAGE TAPER OF SIGNAL ARMS AND POLE SHALL BE 0.125 TO 0.15 INCHES PER FT.

MAST ARM CENTERLINE ANGLE AT ATTACHMENT POINT WITH POLE SHALL MAINTAIN NOT LESS THAN 0.5 DEGREES OR MORE THAN 4 DEGREES POSITIVE SLOPE WITH A LINE PERPENDICULAR TO THE POLE CENTERLINE. THE ARM SHALL MAINTAIN A POSITIVE AFTER IT IS PLACED UNDER LOAD.

7. NUT COVERS - EACH POLE SHALL INCLUDE A BOLT DOWN NUT COVER FOR EACH ANCHOR BOLT.

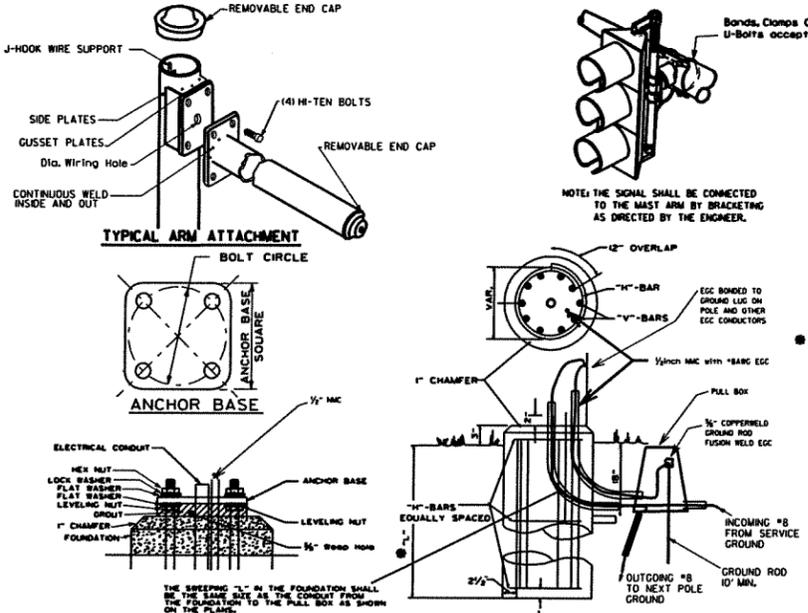


THE GROUND ROD SHALL BE FUSION WELDED TO A 1/2" X 8 A.W.G. SOLID COPPER GROUND WIRE. ATTACHMENT TO THE PRIMARY GROUND MAY BE BY AN APPROVED CLAMP. THE ROD IS TO BE LOCATED IN THE CONCRETE PULL BOX.

TYPICAL FOUNDATION DETAILS

POLE FOUNDATION MINIMUM DIMENSIONS AND STEEL REINFORCING. ALL REINFORCING STEEL SHALL BE GRADE 40 MIN.

ARM LENGTH	FDN. DIAMETER	DEPTH 'L'	STEEL		
			VERT.	HORZ.	O/C.
PED	30"	7'-0"	12-#7 (6'-6")	10-#4	8.44'
2' to 12'	30"	10'-6"	12-#7 (10'-0")	15-#4	8.42'
over 12' to 20'	30"	11'-6"	12-#7 (11'-0")	16-#4	8.66'
over 20' to 35'	36"	12'-6"	13-#8 (12'-0")	17-#4	8.88'
over 35' to 50'	36"	13'-6"	13-#8 (13'-0")	19-#4	8.56'
over 50' to 72'	42"	14'-6"	18-#8 (14'-0")	20-#4	8.74'
Twins to 20'	30"	16'-0"	12-#6 (15'-6")	22-#4	8.76'
Twins over 20' to 44'	36"	16'-0"	13-#8 (15'-6")	22-#4	8.76'
Twins over 44' to 50'	42"	16'-0"	18-#8 (15'-6")	22-#4	8.76'
Twins over 50' to 72'	42"	16'-6"	18-#8 (16'-0")	23-#4	8.64'

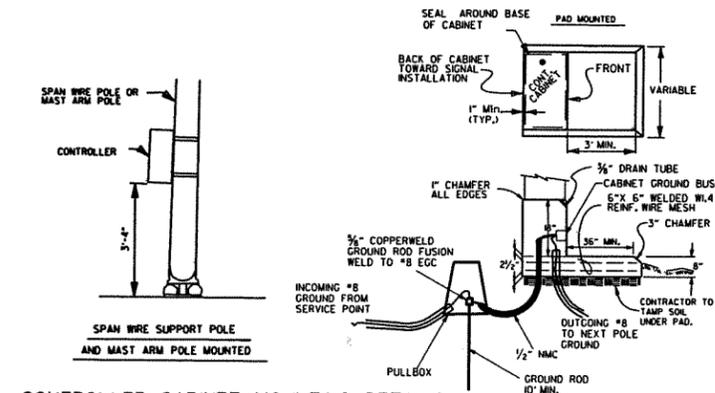

CONTROLLER CABINET MOUNTING DETAILS

UNLESS OTHERWISE DIRECTED BY THE ENGINEER, CABINET ORIENTATION SHALL BE SUCH THAT THE BACK OF THE CABINET IS PARALLEL TO THE STREET AND POSITIONED TO ALLOW VISIBILITY OF THE SIGNAL DISPLAY WHILE OBSERVING THE CONTROLLER FRONT PANEL.

8. GROUND ROD - A 10' X 5/8" GROUND ROD SHALL BE INSTALLED IN THE PULL BOX FOR EACH POLE AND THE CONTROLLER. PAYMENT FOR THE GROUND ROD AND 1/2" NMC SHALL BE INCLUDED. IN ITEM 714 FOR SIGNAL POLES AND ITEM 701 FOR THE CONTROLLER. THE PULL BOX AND CONDUCTOR BOX SHALL BE PAID FOR SEPARATELY.

9. POLE BASE/FOUNDATION - ANCHOR BOLTS SHALL INCLUDE AS A MINIMUM, ONE LEVELING NUT, TWO FLAT WASHERS, ONE LOCK WASHER, AND ONE HEX. NUT. PERIMETER OF ANCHOR BASE SHALL BE GROUDED WITH A 1/4" WEEP HOLE. ALL CONCRETE SHALL BE CLASS 'S' OR GREATER.

10. CONCRETE - ALL CONCRETE FOR CONTROLLER CABINET AND POLE FOUNDATIONS SHALL BE CLASS 'S' OR GREATER.

11. PEDESTRIAN PHASES - PEDESTRIAN MOVEMENTS SHALL BE PUSH BUTTON ACTUATED AND CONCURRENTLY TIMED, UNLESS OTHERWISE INDICATED ON THE PLAN SHEET(S). FURNISHING AND INSTALLING PED PUSH SWITCH SHALL BE CONSIDERED SUBSIDIARY TO THE ITEM PEDESTRIAN SIGNAL HEAD.

SIGNAL OPERATION NOTES:




FLASHING OPERATION - PRIOR TO NORMAL OPERATION, SIGNAL SHALL BE FLASHED FOR A PERIOD OF 3 TO 5 WORK DAYS OR AS DIRECTED BY THE ENGINEER. SIGNAL SHALL BE PLACED IN OPERATION ONLY ON A REGULAR WORK DAY, EXCEPT FRIDAY.

THE CONTRACTOR MAY BE REQUIRED TO ALTER THE FLASHING DISPLAY DURING THE TEMPORARY FLASH PERIOD. AT THE TIME INTERSECTION IS PLACED IN PERMANENT OPERATION, THE FLASH SEQUENCE SHALL THEN BE RETURNED TO THAT INDICATED ON THE PLAN SHEETS. NO ADDITIONAL COMPENSATION SHALL BE ALLOWED FOR THESE ALTERATIONS IN FLASH SEQUENCE.

WHEN THE GROUND ELEVATION AT THE POLE IS LOWER THAN THE ROADWAY ELEVATION, THE LENGTH OF FOUNDATION ABOVE THE GROUND MAY BE INCREASED TO PROVIDE THE REQUIRED SIGNAL HEAD CLEARANCE ABOVE THE ROADWAY. WHEN THE REQUIRED LENGTH OF FOUNDATION ABOVE THE GROUND IS 5'-6" OR LESS, NO INCREASE IN DEPTH "L" WILL BE REQUIRED. WHEN THE REQUIRED LENGTH OF FOUNDATION ABOVE THE GROUND IS 5'-6" OR LESS, INCREASE DEPTH "L" BY 1'-0". FOR LENGTHS GREATER THAN 5'-6", DEPTH "L" SHALL BE ADJUSTED AS DIRECTED BY THE ENGINEER. LONGITUDINAL REINFORCING, AS SHOWN IN THE TABLE, SHALL BE PROVIDED FOR THE LENGTH OF THE EXTENDED SHAFT AND #4 TIES SHALL BE PROVIDED AT A SPACING NOT TO EXCEED 9" ON CENTERS. PAYMENT WILL BE IN ACCORDANCE WITH SECTION 714 OF THE STANDARD SPECIFICATIONS.

IN LIEU OF DESIGNING THE STRUCTURE TO RESIST PERIODIC GALLOPING, A VIBRATORY MITIGATION DEVICE MAY BE PROVIDED BY THE POLE MANUFACTURER. THE VIBRATORY MITIGATION DEVICE SHALL BE AN ANTI-GALLOPING PANEL CONSISTING OF A 60" X 16" X 0.25" SIGN BLANK MOUNTED NEAR THE END OF THE MAST ARM NOT TO EXCEED ONE QUARTER OF THE LENGTH OF THE MAST ARM FROM THE END OF THE MAST ARM WITH THE LONG AXIS OF THE PANEL COLLINEAR WITH THE LONG AXIS OF THE MAST ARM. THE PANEL SHOULD BE MOUNTED AT SUCH A HEIGHT AS TO PROVIDE AT LEAST 6" CLEAR FROM THE TOP OF ANY SIGNAL ASSEMBLY OR SIGN PANEL LOCATED ON THE MAST ARM WITHIN THE LENGTH OF THE ANTI-GALLOPING PANEL.

TRUCK-INDUCED GUST LOADS SHALL BE EXCLUDED FOR FATIGUE DESIGN FOR ALL STRUCTURES EXCEPT MAST ARMS MOUNTED OVER FACILITIES WITH POSTED SPEEDS OF 65 MPH OR GREATER AT THE LOCATION OF THE STRUCTURE.

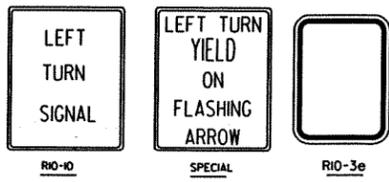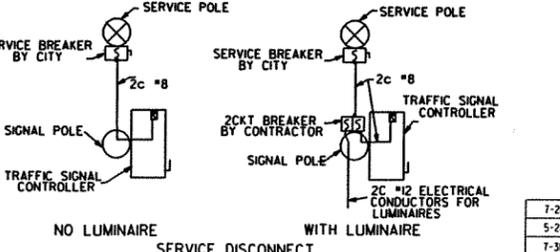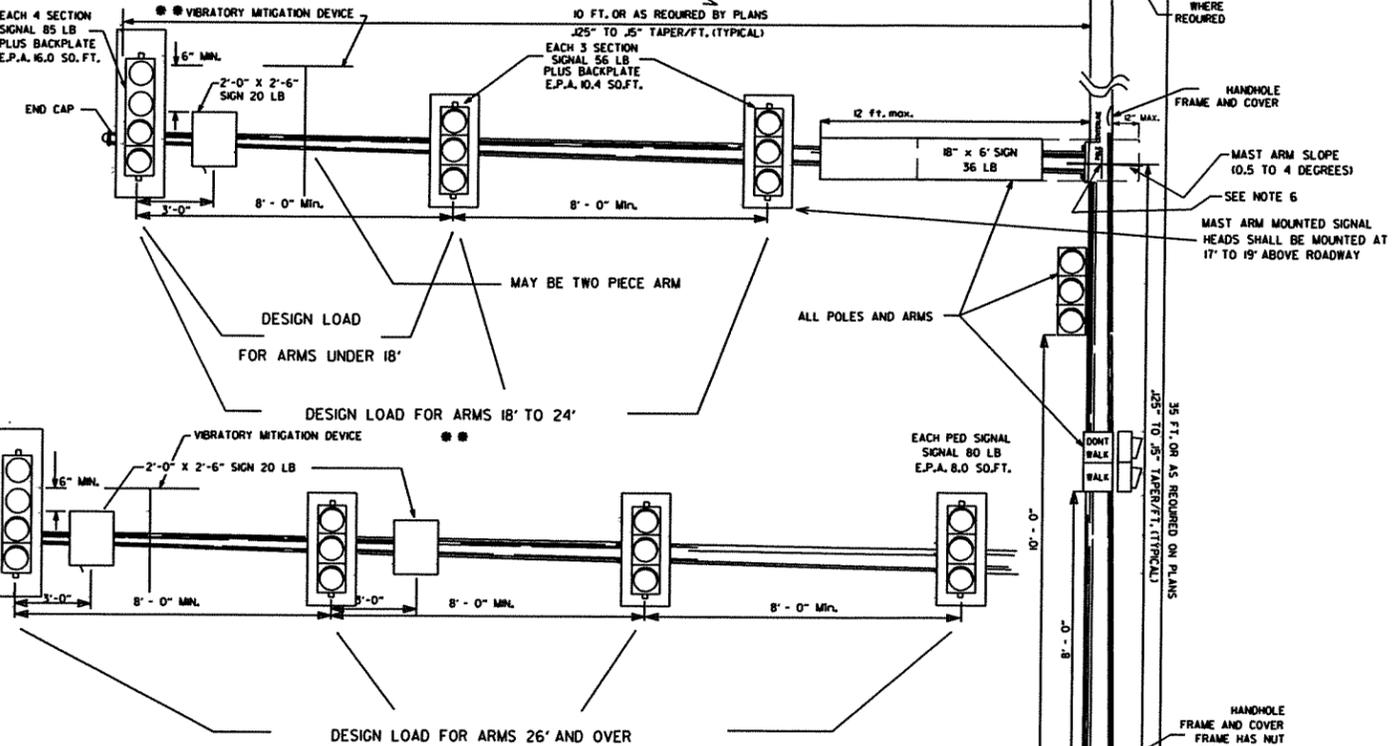

DATE	REVISION	DATE FILED
7-21-8	REVISED WIND SIGNAL HEADS	
5-21-09	REVISED GROUNDING	
7-31-08	REVISED GROUNDING	
4-25-08	ADDED VIBRATORY MITIGATION DEVICE & NOTES	
4-18-08	REVISED AASHTO NOTES	
4-17-08	REVISED TO 2001 AASHTO STANDARDS	
10-12-04	REVISED CABINET ORIENTATION	
6-23-04	REVISED	
5-11-04	REV. NOTE 3/AASHTO REQUIREMENTS	
6-11-01	REV. NOTES & POLE MAST ARM SLOPE	
4-11-01	REVISED POLE TAPERS	
4-25-00	REV. NOTES & SIGNAL HEAD PLACEMENT	
1-22-99	REVISED FOUNDATION DETAILS	
1-17-98	REVISED DETAILS AND NOTES	
1-21-95	ISSUED	

DATE REVISED	DATE FILED	DATE REVISED	DATE FILED	FED. RD. DIST. NO.	STATE	FED. RD. PROJ. NO.	SHEET NO.	TOTAL SHEETS
				6	ARK.			
JOB NO.						020520	29	36

SIGNALIZATION DETAILS


SPECIAL NOTE: 90 MPH WIND ZONE DESIGN, SEE NOTE 3. MINIMUM STRUCTURAL REQUIREMENTS.




ARKANSAS STATE HIGHWAY COMMISSION

SIGNALIZATION DETAILS (Steel Pole With Mast Arm)


DATE	REVISION	DATE FILED
------	----------	------------

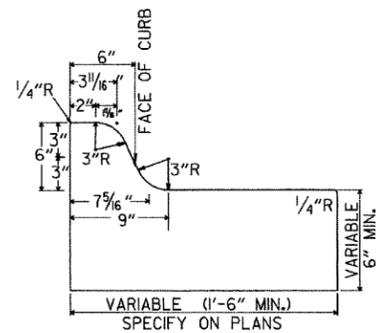


TYPE A

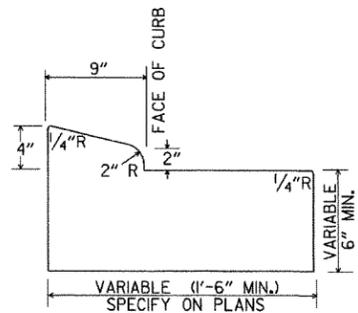


TYPE B-1

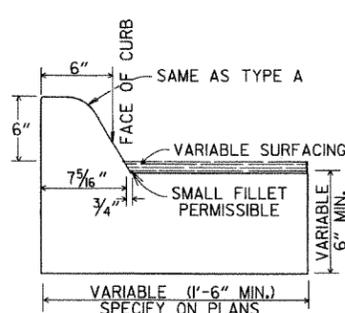


TYPE C

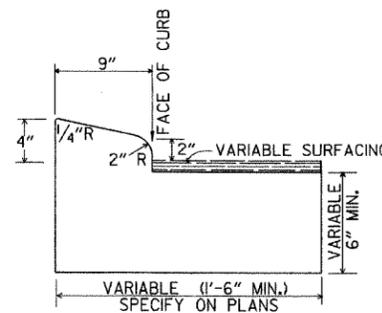

TYPE B-2

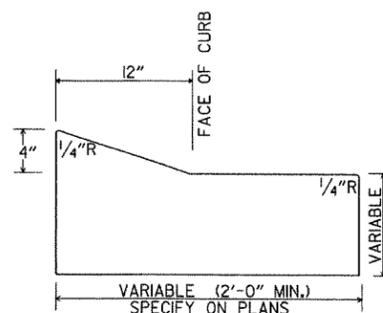


TYPE E-1

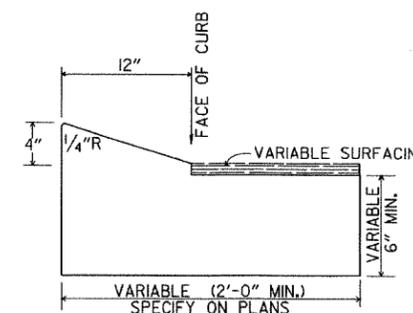


TYPE E-2


CONCRETE COMBINATION CURB AND GUTTER

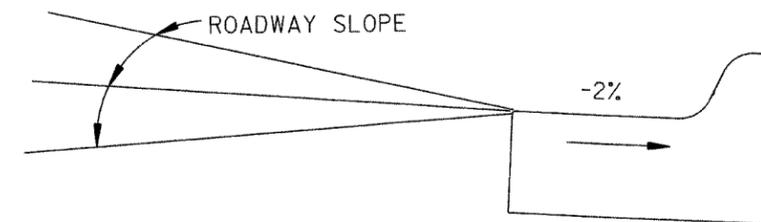


DETAIL OF GUTTER SLOPE  
GUTTER SHALL BE CONSTRUCTED ON 2% SLOPE AWAY FROM ROADWAY, REGARDLESS OF ROADWAY SLOPE.

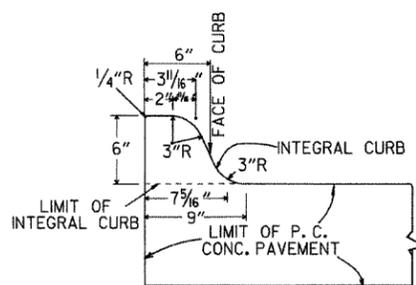

TYPE A

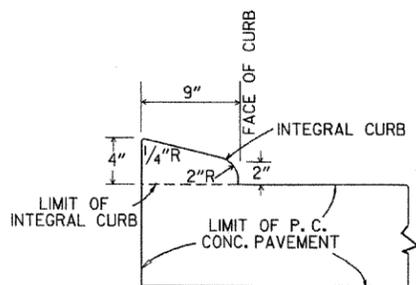


TYPE B

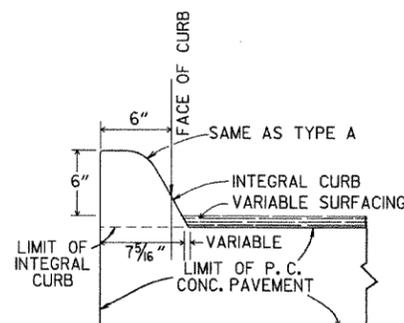

TYPE C


INTEGRAL CURB

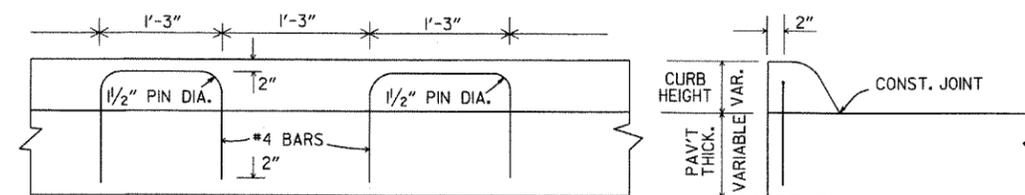


LONGITUDINAL SECTION

ELEVATION


ALTERNATE CONSTRUCTION METHOD FOR INTEGRAL CURB

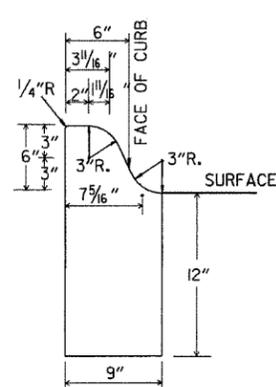


TYPE A

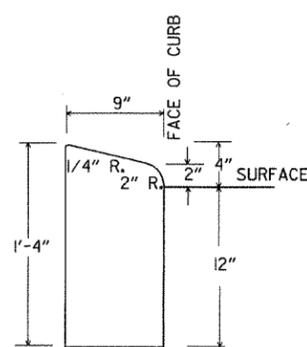

TYPE B

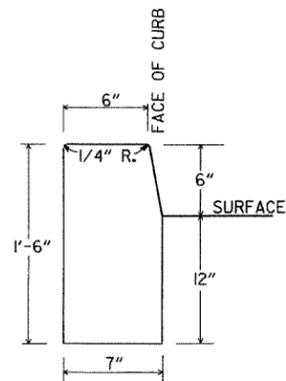


TYPE D

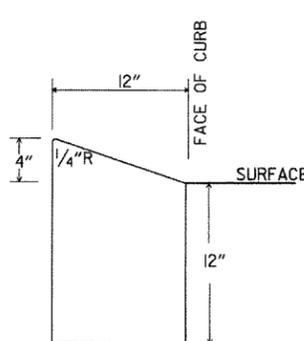

TYPE E

CONCRETE CURB

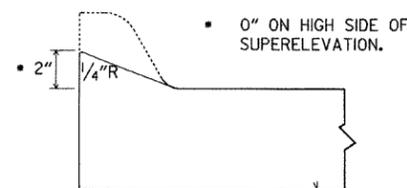

NOTE: USE MODIFIED CURB AS SPECIFIED ON STD. DR-1. COMPENSATION FOR MODIFIED CURB WILL BE CONSIDERED INCLUDED IN THE PRICE BID FOR THE TYPE OF CURB OR CURB AND GUTTER SPECIFIED.


DETAILS OF MODIFIED CURB

DATE	REVISION	DATE FILMED
11-29-07	REVISED GUTTER SLOPE & MODIFIED CURB DETAILS	
11-10-05	ADDED DETAILS OF TYPE E CURBS	
11-16-01	REVISED CONCRETE CURB TYPE B	
11-18-98	REVISED MODIFIED CURB	
6-2-94	ADDED NOTE TO SPECIAL MODIFIED CURB	
8-5-93	CORRECTED GUTTER SLOPE	8-5-93
10-1-92	ADDED DETAILS OF GUTTER SLOPE	10-1-92
5-24-90	ADDED DETAILS OF MODIFIED CURB	5-24-90
11-30-89	VARIABLE DEPTH TYPE A & B 1	11-30-89
7-15-88	REVISED MODIFIED CURB	630-7-15-88
11-1-73	REVISED MODIFIED CURB	500-11-1-73
10-2-72	REVISED AND REDRAWN	512-10-2-72


ARKANSAS STATE HIGHWAY COMMISSION

CURBING DETAILS


STANDARD DRAWING CG-1

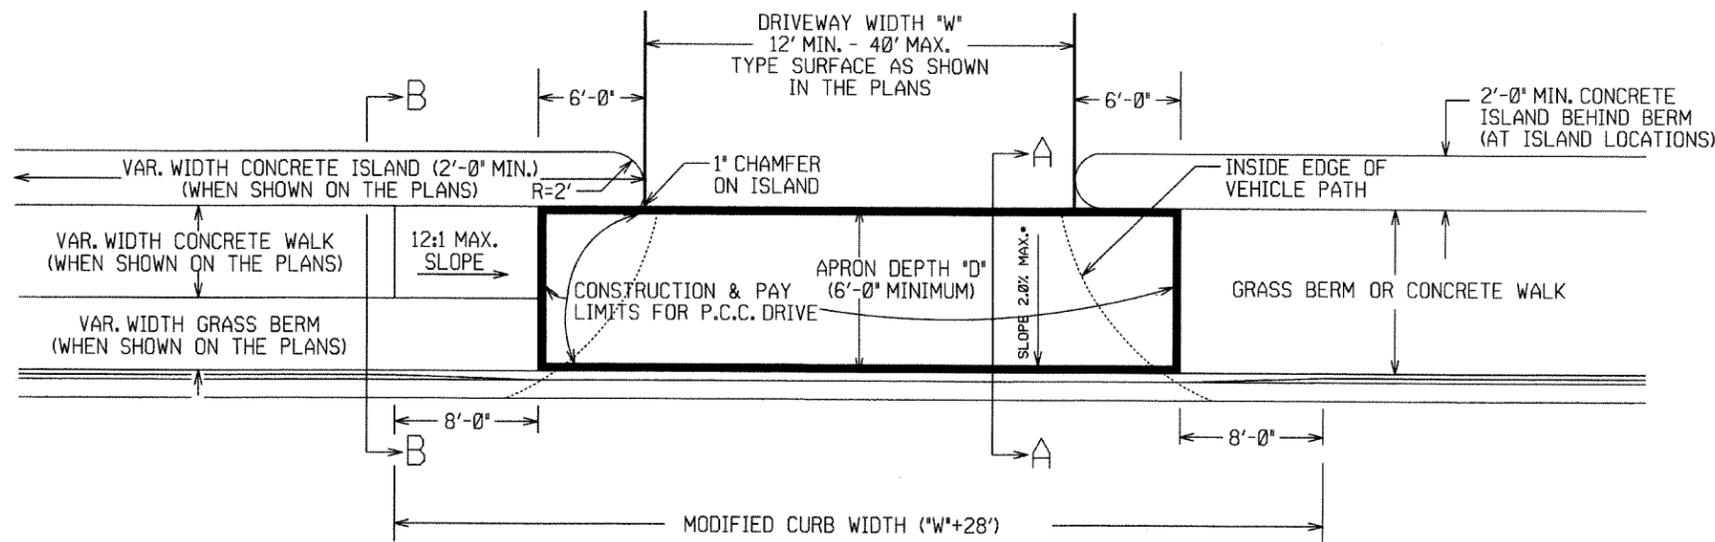

PLAN VIEW

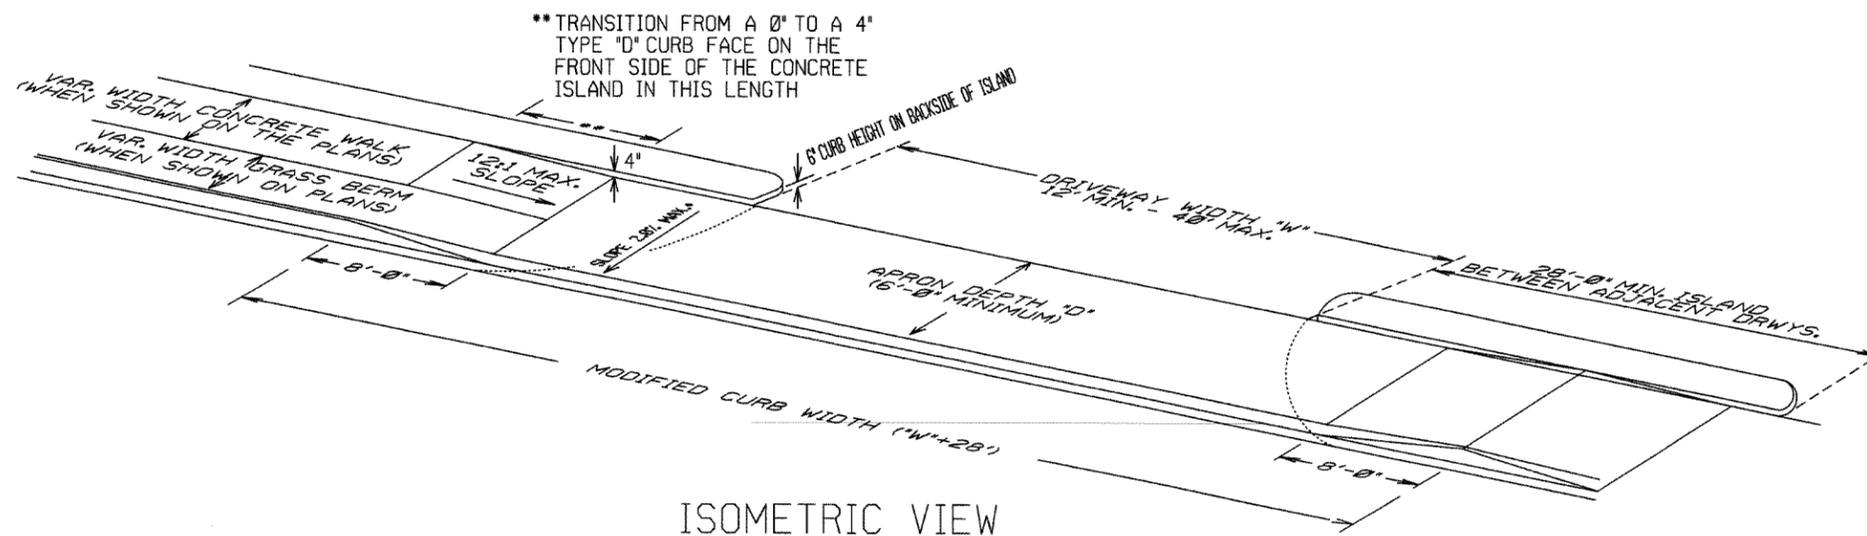

ISOMETRIC VIEW

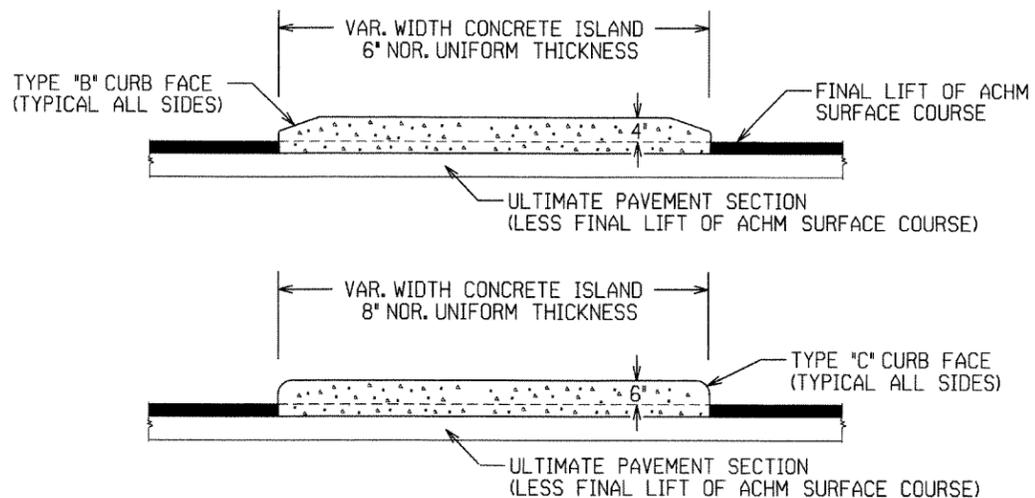

CURBED ISLANDS FOR CHANNELIZATION

REFER TO PLANS FOR TYPE OF CURB FACE TO BE USED.  
NO DIRECT PAYMENT WILL BE MADE FOR THE CURB FACES  
SHOWN ON THE ISLAND DETAILS. PAYMENT FOR THE CURB  
FACE WILL BE INCLUDED IN THE UNIT PRICE BID FOR THE  
ITEM "CONCRETE ISLAND".




EXTENSION TYPICAL SECTIONS

- 1: CONCRETE - 6" P.C. CONCRETE DRIVEWAY
- 2: ASPHALT - 2" ACHM SURFACE COURSE (1/2")  
4" ACHM BINDER COURSE (1") OR  
4" ACHM BASE COURSE (1-1/2")
- 3: ASPHALT - 2" ACHM SURFACE COURSE (1/2")  
7" AGGREGATE BASE COURSE
- 4: AGGREGATE - 6" AGGREGATE BASE COURSE


THE TYPE OF EXTENSION SHALL BE AS SHOWN IN THE PLANS.  
THE CONTRACTOR MAY, WITH THE APPROVAL OF THE ENGINEER,  
SUBSTITUTE A LOWER NUMBERED TYPE OF EXTENSION IN LIEU  
OF THE TYPE SPECIFIED IN THE PLANS, BUT AT NO ADDITIONAL  
COST TO THE DEPARTMENT.

DRIVEWAY EXTENSION DETAILS

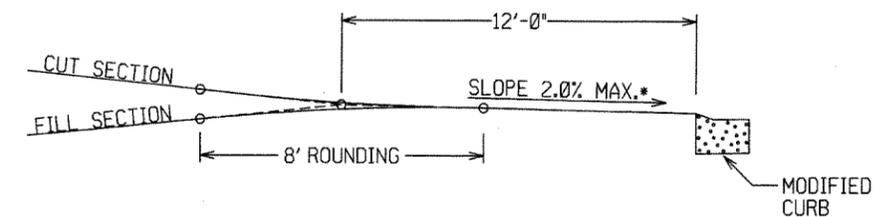


DRIVEWAY VERTICAL ALIGNMENT DETAILS

\* NOTE: DRIVEWAYS MAY NOT BE SLOPED AWAY  
FROM THE ROADWAY UNLESS APPROVED  
BY THE ENGINEER.

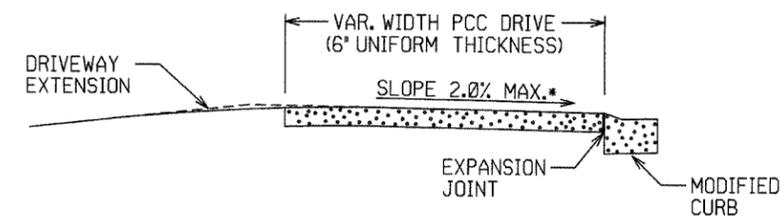

SECTION A-A

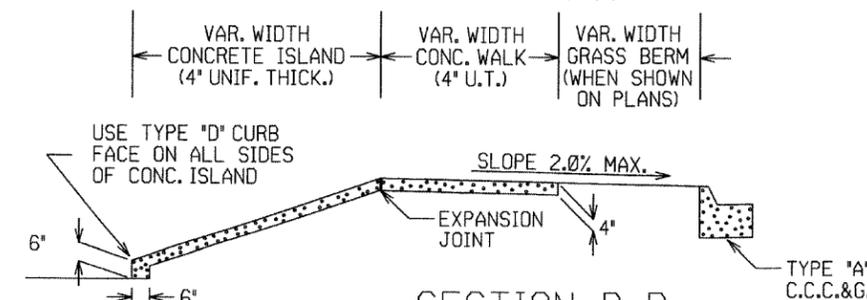



SECTION B-B  
CURBED ISLAND BEHIND WALK

DATE	REV	DATE FILMED	DESCRIPTION
11-29-07			ADDED CHANNELIZATION ISLAND WITH TYPE C CURB FACE & REVISED DRIVEWAY SLOPE NOTE & VERTICAL ALIGNMENT DETAIL
11-10-05			REV. APRON SLOPE & DEPTH OF AGG. BASE.
8-22-02			ADDED ISLAND DETAILS & NOTES
3-30-00			REV. MOD. CURB WIDTH & TRANS. NOTE
11-19-98			REVISED NOTES
11-18-98			REDRAWN AND REISSUED


ARKANSAS STATE HIGHWAY COMMISSION  
DETAILS OF DRIVEWAYS & ISLANDS  
STANDARD DRAWING DR-1

NOTES:


1. ALL LINES SHALL HAVE A WIDTH OF 4 INCHES.
2. THE THICKNESS AND RATE OF PAINT APPLICATION SHALL BE AS SPECIFIED IN SECTION 718 OF THE STANDARD SPECIFICATIONS.
3. THIS DRAWING SHALL BE USED IN CONJUNCTION WITH THE LATEST REVISED ADDITION OF THE "MANUAL ON UNIFORM TRAFFIC CONTROL DEVICES."
4. RAISED PAVEMENT MARKERS SHALL BE CENTERED BETWEEN SKIP LINES ON 40 FEET SPACING UNLESS OTHERWISE SHOWN ON THE PLANS.

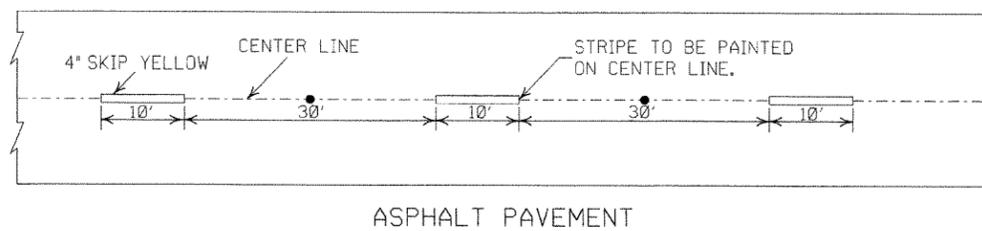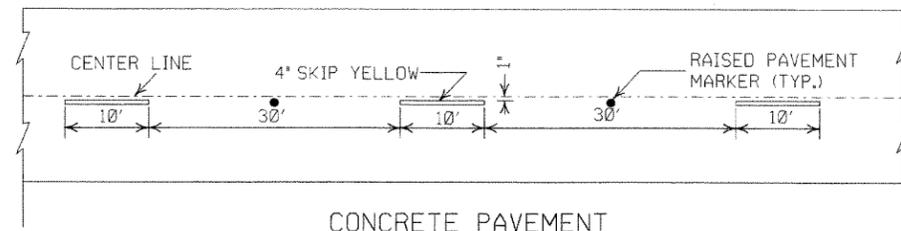


BROKEN LINE STRIPING

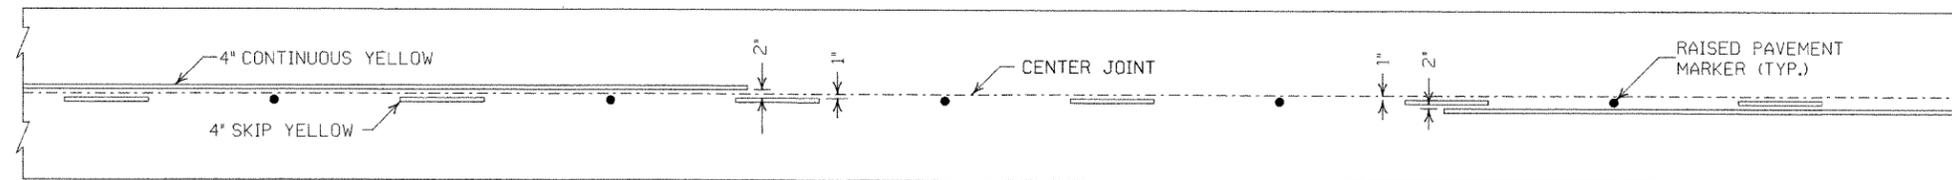


SOLID LINE STRIPING ON CONCRETE PAVEMENT

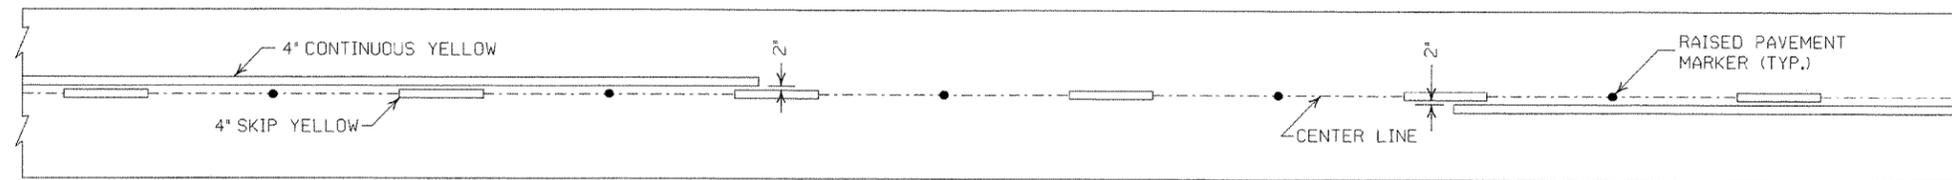

SOLID LINE STRIPING ON ASPHALT PAVEMENT

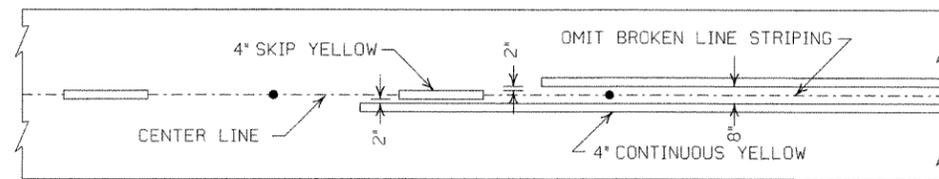


ASPHALT PAVEMENT

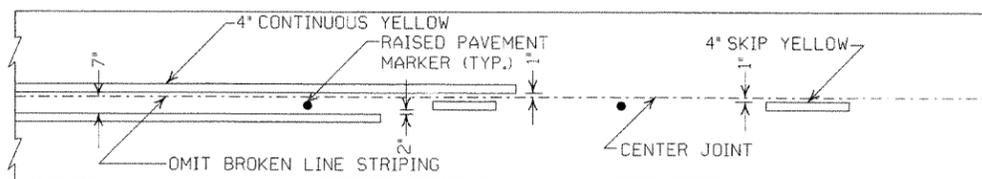


CONCRETE PAVEMENT

STRIPING AT ADJACENT NO PASSING LANES

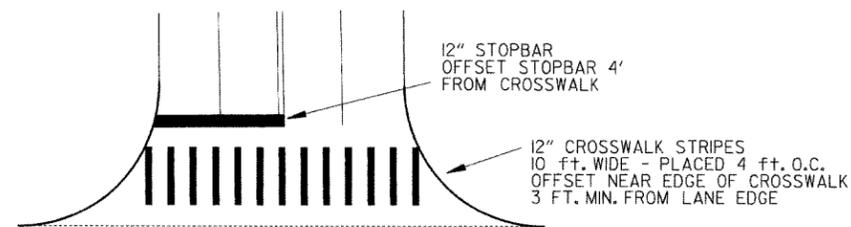


CROSSWALK AND STOPBAR DETAILS

2" FOR ASPHALT OR CONCRETE PAVEMENT  
6" FOR BITUMINOUS SURFACE TREATMENT

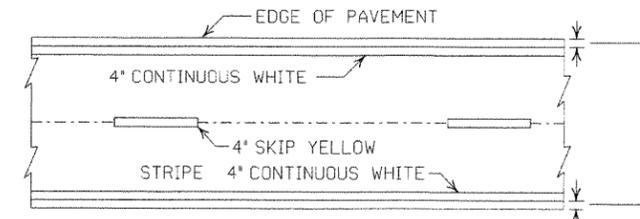

PAVEMENT EDGE LINE MARKING

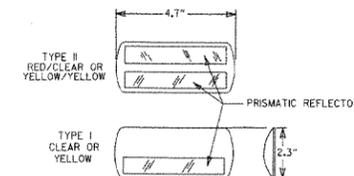

NOTE:  
THE RED LENS OF THE  
TYPE II R.P.M. SHALL  
FACE THE INCORRECT  
TRAFFIC MOVEMENT.

DETAIL OF  
STANDARD  
RAISED PAVEMENT MARKERS

GENERAL NOTES:

THIS DRAWING SHOULD BE CONSIDERED AS TYPICAL ONLY AND THE FINAL LOCATION OF THE STRIPING AND RAISED PAVEMENT MARKERS SHALL BE DETERMINED BY THE ENGINEER.

THIS DRAWING SHOULD BE USED IN CONJUNCTION WITH THE "MANUAL ON UNIFORM TRAFFIC CONTROL DEVICES", LATEST REVISION.

NOTE:  
DIMENSIONS SHOWN FOR RAISED PAVEMENT MARKERS ARE TYPICAL. THE CONTRACTOR MAY SUBSTITUTE SIMILAR MARKERS WITH THE APPROVAL OF THE ENGINEER. REQUESTING APPROVAL FOR SIMILAR MARKERS MAY BE MADE BY REFERRING TO THE AHTD QUALIFIED PRODUCTS LIST.

DATE	REVISION	FILMED
11-17-10	REVISED GENERAL NOTES & REMOVED PLOWABLE PVMT MKRS	
11-18-04	REVISED NOTE 2 & GENERAL NOTES	
8-22-02	ADDED CROSSWALK & STOPBAR DTLS.	
7-02-98	ADDED DETAILS OF STD. RAISED PAV'T. MARKERS	
4-26-96	REV. NOTES 3&4; ADDED R.P.M.	
9-30-80	DRAWN	1-9-30-80

ARKANSAS STATE HIGHWAY COMMISSION

PAVEMENT MARKING DETAILS

STANDARD DRAWING PM-1

ADVANCE DISTANCES (XXXX)

500 FT 1/2 MILE  
1000 FT 3/4 MILE  
1500 FT 1 MILE AHEAD

GENERAL NOTES:

- ALL TRAFFIC CONTROL DEVICES USED ON ROAD CONSTRUCTION SHALL CONFORM TO THE MANUAL ON UNIFORM TRAFFIC CONTROL DEVICES, LATEST EDITION, AND TO THE STANDARD HIGHWAY SIGNS, LATEST EDITION, OR AS APPROVED BY THE FEDERAL HIGHWAY ADMINISTRATION.
- TRAFFIC CONTROL DEVICES SHALL BE SET UP JUST BEFORE THE START OF CONSTRUCTION OPERATIONS AND SHALL BE PROPERLY MAINTAINED DURING THE TIME SUCH CONDITIONS EXIST. THEY SHALL REMAIN IN PLACE ONLY AS LONG AS NEEDED AND REMOVED THEREAFTER.
- EXISTING SIGNS AND CONSTRUCTION SIGNS SHALL BE KEPT IN PROPER POSITION, AND BE CLEAN AND LEGIBLE AT ALL TIMES. SIGNS THAT DO NOT APPLY TO EXISTING CONDITIONS SHALL BE REMOVED. SIGNS THAT ARE DAMAGED, DEFACED, OR THAT ACCUMULATE DIRT DURING CONSTRUCTION SHALL BE CLEANED, REPAIRED, OR REPLACED.
- SIGNS ARE USUALLY MOUNTED ON A SINGLE POST, ALTHOUGH THOSE WIDER THAN 36" OR LARGER THAN 10 SQ. FT. SHALL BE MOUNTED ON TWO POSTS OR ABOVE A TYPE III BARRICADE.
- SIGN POSTS DIRECT BURIED IN SOIL SHALL BE 2 LB. MINIMUM CHANNEL POST OR 4"x4" WOOD POSTS. CHANNEL POSTS SHALL BE PAINTED GREEN. WOOD POSTS SHALL BE PAINTED WHITE. ALL POSTS SHALL BE NEATLY CONSTRUCTED, AND SHALL BE REPLUMBED, CLEANED, OR REPAIRED AS NEEDED FOR THE DURATION OF THE JOB. THERE SHALL NOT BE MORE THAN 2 POSTS IN A 7' PATH FOR WOOD OR CHANNEL POSTS. ANY CHANNEL POST SPLICE SHALL BE IN ACCORDANCE WITH STANDARD DRAWING TC-3.
- POST MOUNTED SIGNS IN RURAL AREAS SHALL BE CONSTRUCTED WITH THE NEAR EDGE OF THE SIGN FROM 6 TO 12 FEET FROM THE PAVEMENT EDGE. SIGNS IN URBAN AREAS AND BARRICADE MOUNTED SIGNS SHALL BE MOUNTED A MINIMUM OF 2 FEET FROM THE PAVEMENT EDGE.
- ALL POST AND BARRICADE MOUNTED SIGNS MOUNTED IN URBAN AREAS SHALL BE MOUNTED A MINIMUM DISTANCE OF 7' FROM THE BOTTOM OF THE SIGN TO THE ROADWAY SURFACE. ALL POST AND BARRICADE MOUNTED SIGNS MOUNTED IN RURAL AREAS SHALL BE MOUNTED A MINIMUM DISTANCE OF 7' FROM THE BOTTOM OF THE SIGN TO THE ROADWAY SURFACE, EXCEPT A MINIMUM OF 6' SHALL BE USED WHEN MOUNTING AN ADVISORY SIGN BELOW A WARNING SIGN. TEMPORARY SIGNS MAY BE MOUNTED ON PORTABLE SUPPORTS FOR INTERMEDIATE TERM STATIONARY WORK CONDITIONS. THE SIGNS MINIMUM MOUNTING HEIGHT SHALL BE 5'. RETROREFLECTIVE DEVICES SHALL BE USED. TEMPORARY SIGNS MAY BE MOUNTED ON PORTABLE SUPPORTS FOR SHORT-TERM, SHORT DURATION, AND MOBILE CONDITIONS. THEY SHALL BE NO LESS THAN ONE (1) FOOT ABOVE THE TRAVELED WAY. LONG-TERM STATIONARY SIGNS SHALL BE DIRECT BURIED IN SOIL, UNLESS CONDITIONS NECESSITATE THE USE OF PORTABLE SIGNS, OR AS APPROVED BY THE ENGINEER. CONCRETE PADS, CONCRETE OR ROCK BALLAST, OR OTHER SOLID MATERIALS SHALL NOT BE UTILIZED WITH PORTABLE SIGN SUPPORTS.













- FLAGGERS SHALL USE REFLECTORIZED STOP-SLOW PADDLES. FLAGS MAY BE USED ONLY FOR EMERGENCY SITUATIONS.
- MOST OF THE SIGNS SHOWN ARE ORIENTED TO THE RIGHT. HOWEVER, THIS DOES NOT PRECLUDE THE USE OF MIRROR IMAGES OF THESE SIGNS WHERE THE REVERSE ORIENTATION MIGHT BETTER CONVEY TO MOTORISTS THE PROPER DIRECTION OF MOVEMENT.
- R55-1 SIGNS SHALL BE PLACED AT LEAST 1500' BUT NOT MORE THAN 1 MILE IN ADVANCE OF THE WORK ZONE. IF A SPEED LIMIT REDUCTION IS IN EFFECT, THE SIGN SHALL BE PLACED A MINIMUM OF 500' IN ADVANCE OF THE "REDUCED SPEED AHEAD" SIGN.


\* NOTE: SUPPORTS FOR SIGNS, BARRICADES, AND VERTICAL PANELS THAT ARE DIFFERENT FROM THE REQUIREMENTS SHOWN IN NOTES 4 & 5, BUT MEET THE REQUIREMENTS OF NCHRP-350 OR MANUAL FOR ASSESSING SAFETY HARDWARE (MASH), WILL BE ACCEPTED. COMPLIANCE WITH THE REQUIREMENTS OF NCHRP-350 OR MANUAL FOR ASSESSING SAFETY HARDWARE (MASH) IS REQUIRED FOR ALL PROJECTS.

12-15-11	REVISED W24-1	
11-17-10	DELETED W8-9a & ADDED W8-9	
10-15-09	ADDED REFERENCE TO MASH & ADDED SIGN W24-1	
4-17-08	REVISED SIGN DESIGNATIONS	
11-18-04	REVISED NOTES	
10-9-03	REVISED NOTE 1	
11-16-01	REVISED NOTE 7	
9-28-00	REVISED NOTE	
11-18-98	ADDED NOTE	
6-26-97	REVISED NOTE 5	
4-03-97	REVISED NOTE 5	
10-18-96	ADDED CONTROLLED ACCESS HWY. SIGN & TO NOTE 7	
10-12-95	ADDED R55-1	
6-8-95	REVISED TO CORRECT SIGN ILLUSTRATIONS	6-8-95
2-2-95	REVISED PER PART VI, MUTCD SEPT. 3, 1993	
8-15-91	DRAWN AND PLACED IN USE	
DATE	REVISION	FILMED


ARKANSAS STATE HIGHWAY COMMISSION  
STANDARD TRAFFIC CONTROLS  
FOR HIGHWAY CONSTRUCTION  
STANDARD DRAWING TC-1

   \* USE 6" C LETTERS  
\*\* USE 4" D LETTERS

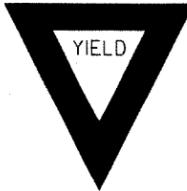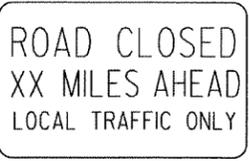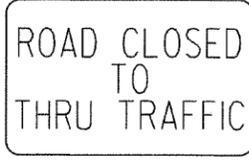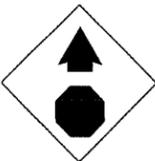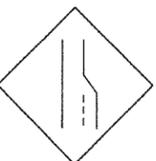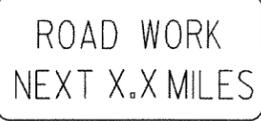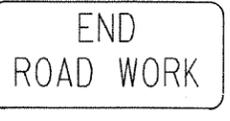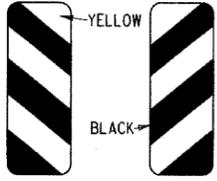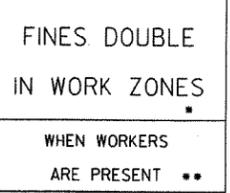
<p>RI-1</p>  <p>STANDARD 30"x30" EXPWAY 36"x36" SPECIAL 48"x48"</p>	<p>RI-2</p>  <p>STD. 36"x36"x36" EXPWY. 48"x48"x48" FWY. 60"x60"x60"</p>	<p>R2-1</p>  <p>STD. 24"x30" EXPWY. 36"x48" FWY. 48"x60"</p>	<p>R2-5A</p>  <p>STD. 24"x30" EXPWY. 36"x48" FWY. 48"x60"</p>	<p>R2-5C</p>  <p>STD. 24"x30" EXPWY. 36"x48" FWY. 48"x60"</p>	<p>R4-1</p>  <p>STD. 24"x30" EXPWY. 36"x48" FWY. 48"x60"</p>	<p>R4-2</p>  <p>STD. 24"x30" EXPWY. 36"x48" FWY. 48"x60"</p>	
<p>R5-1</p>  <p>STD. 30"x30" EXPWY. 36"x36" SPECIAL 48"x48"</p>	<p>R11-2</p>  <p>48"x30"</p>	<p>R11-3A</p>  <p>60"x30"</p>	<p>R11-4</p>  <p>60"x30"</p>	<p>RSP-1</p>  <p>48"x30"</p>	<p>WI-1</p>  <p>STD. 36"x36" FWY. 48"x48"</p>	<p>WI-2</p>  <p>STD. 36"x36" FWY. 48"x48"</p>	
<p>WI-3</p>  <p>STD. 48"x48"</p>	<p>WI-4</p>  <p>STD. 48"x48"</p>	<p>WI-6</p>  <p>STD. 48"x24" SPECIAL 60"x30"</p>	<p>WI-8</p>  <p>STD. 18"x24" SPECIAL 24"x30" EXPWY. 30"x36" FWY. 36"x48"</p>	<p>W3-1</p>  <p>STD. 36"x36" SPECIAL 48"x48"</p>	<p>W3-2</p>  <p>STD. 36"x36" SPECIAL 48"x48"</p>	<p>W4-2</p>  <p>STD. 36"x36" FWY. 48"x48"</p>	
<p>W5-1</p>  <p>STD. 36"x36" SPECIAL 48"x48"</p>	<p>W6-3</p>  <p>EXPWY. 36"x36" SPECIAL 48"x48"</p>	<p>W8-7</p>  <p>EXPWY. 36"x36" FWY. 48"x48"</p>	<p>W9-2</p>  <p>STD. 36"x36" FWY. 48"x48"</p>	<p>W13-1</p>  <p>STD. 24"x24"</p>	<p>W20-1</p>  <p>STD. 48"x48"</p>	<p>W20-2</p>  <p>STD. 48"x48"</p>	<p>W20-3</p>  <p>STD. 48"x48"</p>
<p>W20-4</p>  <p>STD. 48"x48"</p>	<p>W20-5</p>  <p>STD. 48"x48"</p>	<p>W20-7a</p>  <p>18" 500 FEET W16-2 24"</p> <p>STD. 36"x36" FWY. 48"x48"</p>	<p>W21-2</p>  <p>STD. 30"x30" SPECIAL 36"x36"</p>	<p>W21-5</p>  <p>STD. 30"x30" SPECIAL 36"x36"</p>	<p>W24-1</p>  <p>STD. 36"x36"</p>	<p>WI-4b</p>  <p>STD. 48"x48"</p>	<p>R56-1</p>  <p>STD. 18"x18"</p>
<p>W8-11</p>  <p>STD. 36"x36" FWY. 48"x48"</p>	<p>W8-9</p>  <p>STD. 36"x36" FWY. 48"x48"</p>	<p>G20-1</p>  <p>60"x24"</p>	<p>G20-2</p>  <p>48"x24"</p>	<p>OM-3L OM-3R</p>  <p>12"x36"</p>	<p>M4-9</p>  <p>STD. 30"x24" SPECIAL 48"x36" SPECIAL 60"x48"</p>	<p>M4-10</p>  <p>48"x18"</p>	<p>R55-1</p>  <p>36"x60"</p> <p>* USE 6" C LETTERS ** USE 4" D LETTERS</p>

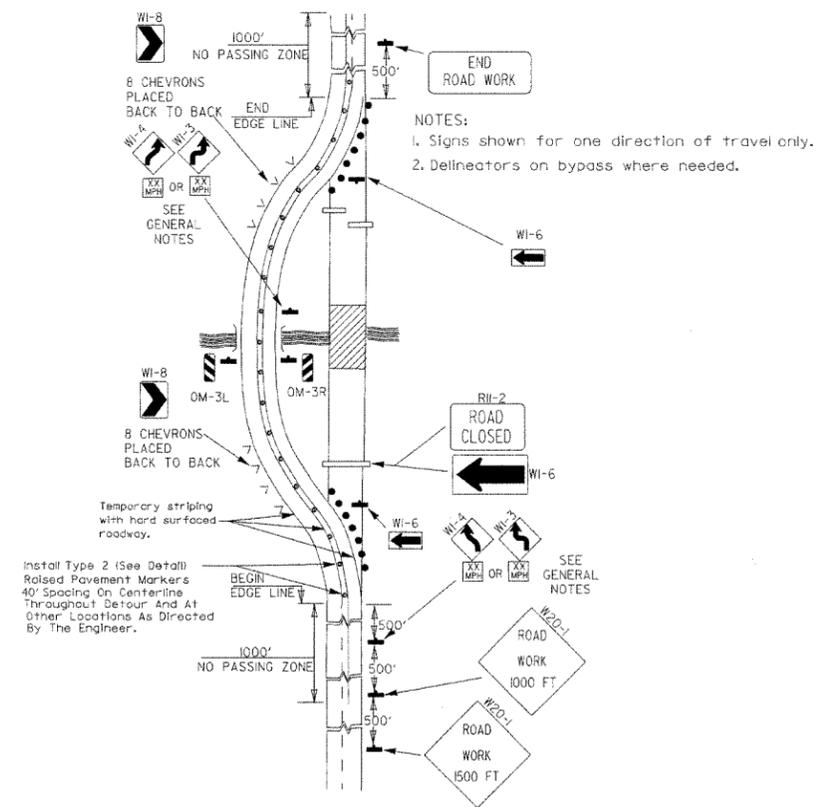


(A) Typical application of traffic control devices on a 2-lane highway where the entire roadway is closed and a bypass detour is provided.

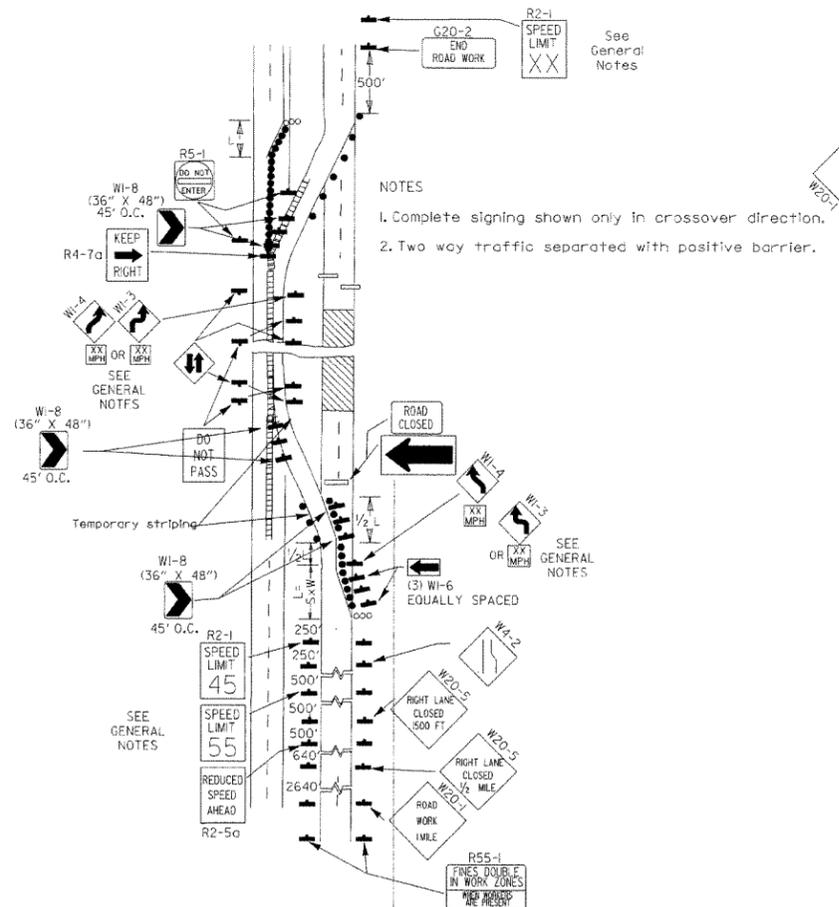

(B) Typical application - 4-lane divided roadway where one roadway is closed.

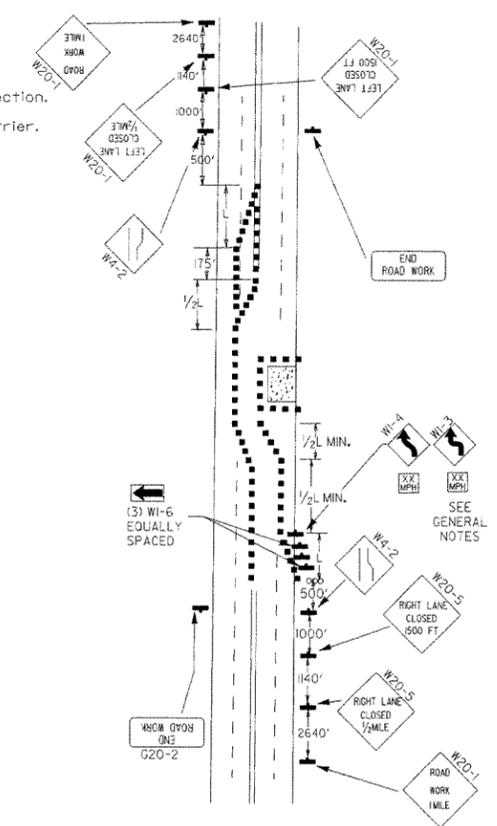


(C) Typical application - 4-lane undivided roadway where half of the roadway is closed.

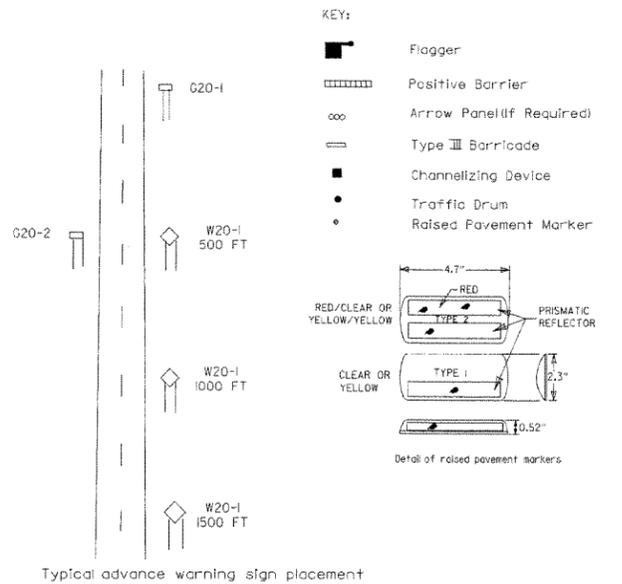


Taper formulae:  
 $L = SxW$  for speeds of 45mph or more.  
 $L = \frac{WS^2}{60}$  for speeds of 40mph or less.  
 Where:  
 L = Minimum length of taper.  
 S = Numerical value of posted speed limit prior to work or 85th percentile speed.  
 W = Width of offset.


- GENERAL NOTES:
- Advisory speed posted on W1-3 or W1-4 curve warning signs to be determined at site. Use W1-4 when speed is greater than 30mph and W1-3 when 30mph or less.
  - When the existing speed limit is 55mph and the plans require a speed limit of 45mph, the R2-1(55) shall be omitted and the R2-1(45) shall be installed at that location. Additional R2-1(45) speed limit signs shall be installed at a maximum of 1/2 mile intervals. At the end of the work area a R2-1(XX) shall be installed to match original speed limit.
  - When the existing speed limit is 65mph and the plans require a speed limit of 55mph, the R2-1(65) shall be omitted. Additional R2-1(55) speed limit signs shall be installed at a maximum of 1/2 mile intervals. At the end of the work area a R2-1(XX) shall be installed to match original speed limit.
  - The maximum spacing between channelizing devices in a taper should be approximately equal in feet to the speed limit. Beyond the taper, maximum spacing shall be two times the speed limit, or as directed by the Engineer.
  - Warning lights and/or flags may be mounted to signs or channelizing devices at night as needed.
  - Pavement markings no longer applicable which might create confusion in the minds of vehicle operators shall be removed or obliterated as soon as practicable.
  - Trailer mounted devices such as arrow panels and portable changeable message signs shall be delineated by affixing conspicuity material in a continuous line on the face of the trailer. When placed on or adjacent to the shoulder and not behind a positive barrier, these devices shall be delineated by placing five (5) traffic drums, equally spaced along the traffic side of the device.

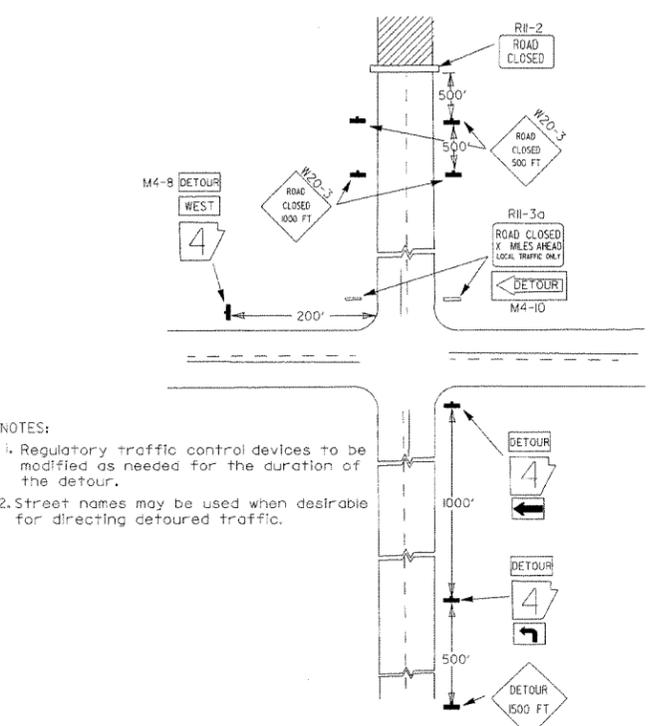

(D) Typical application - roadway closed beyond detour point.

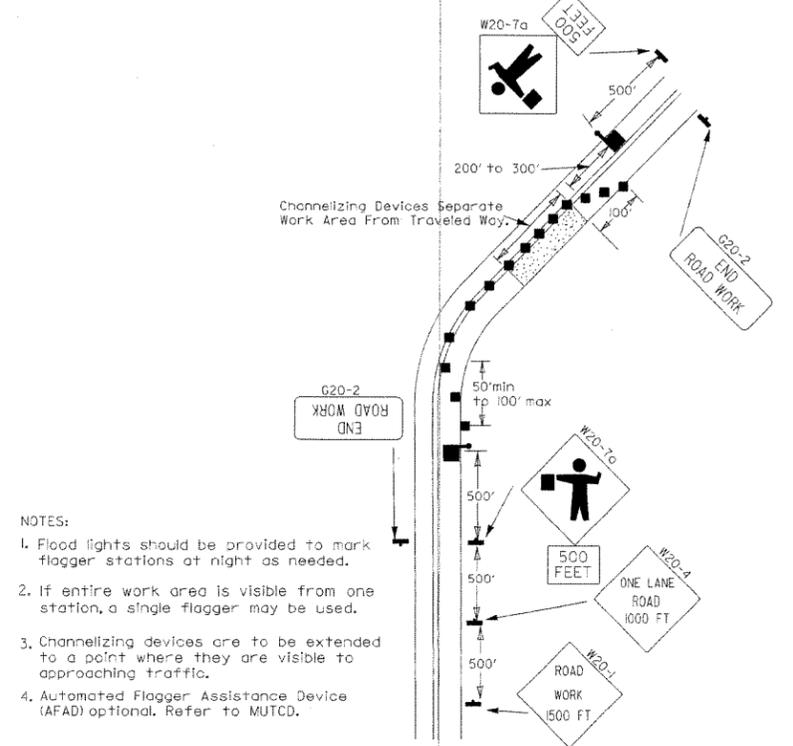


(E) Typical application of traffic control devices on 2-lane highway where one lane is closed and flagging is provided.

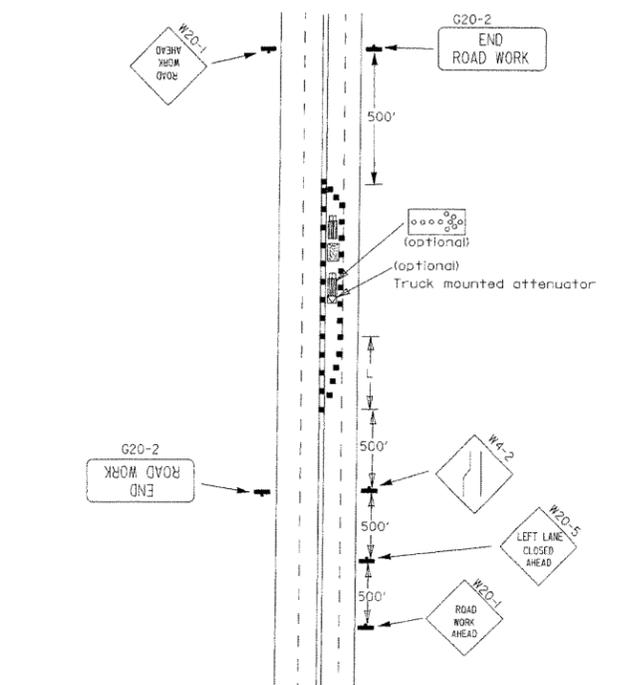


(F) Typical application - 4-lane undivided roadway with inside lane closed.

DATE	REVISION	FILMED
3-11-10	ADDED (AFAD)	
11-20-08	REVISED SIGN DESIGNATIONS	
11-18-04	ADDED GENERAL NOTE	
10-18-96	ADDED R55-1	
4-26-96	CORRECTED (a) BEHIND G20-2	
6-8-95	CORRECTED SIGN IDENT. ON W1-4A	6-8-95
2-2-95	REVISED PER PART VI, MUTCD, SEPT. 3, 1993	
8-15-91	DRAWN AND PLACED IN USE	

Channelizing devices

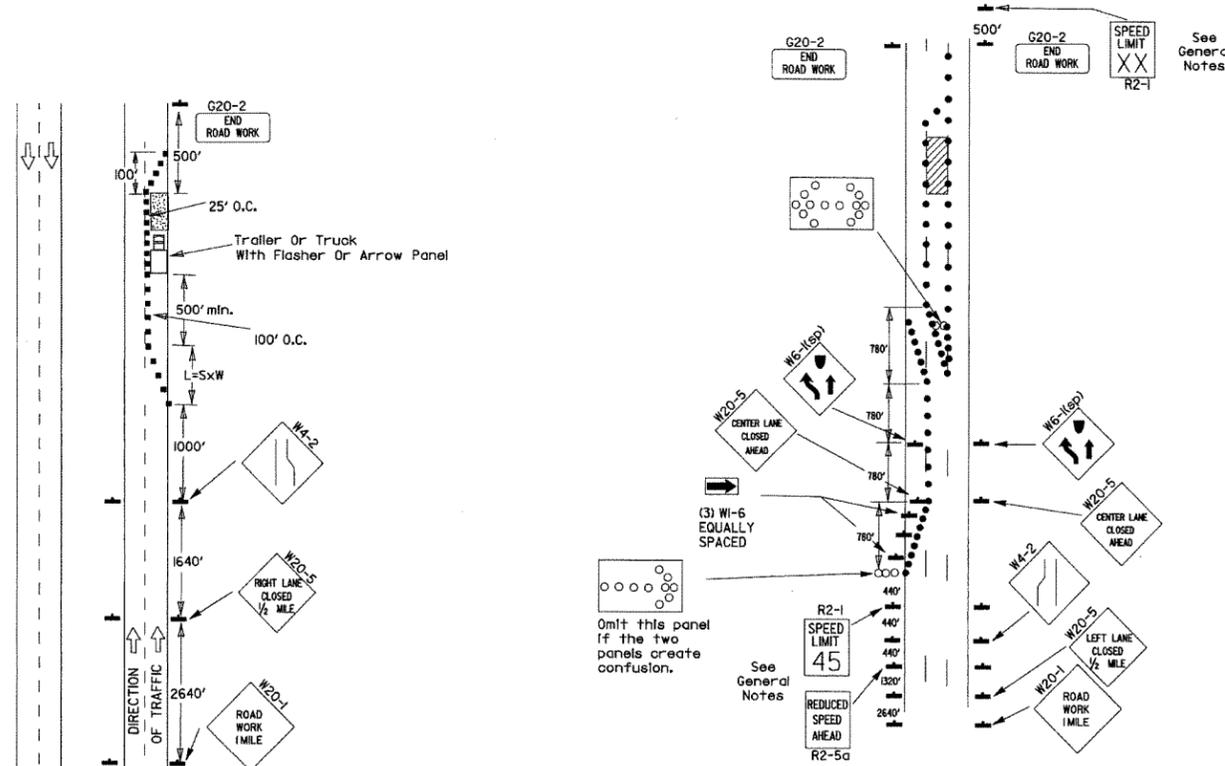

(A) Typical application - daytime maintenance operations of short duration on a 4-lane divided roadway where half of the roadway is closed.

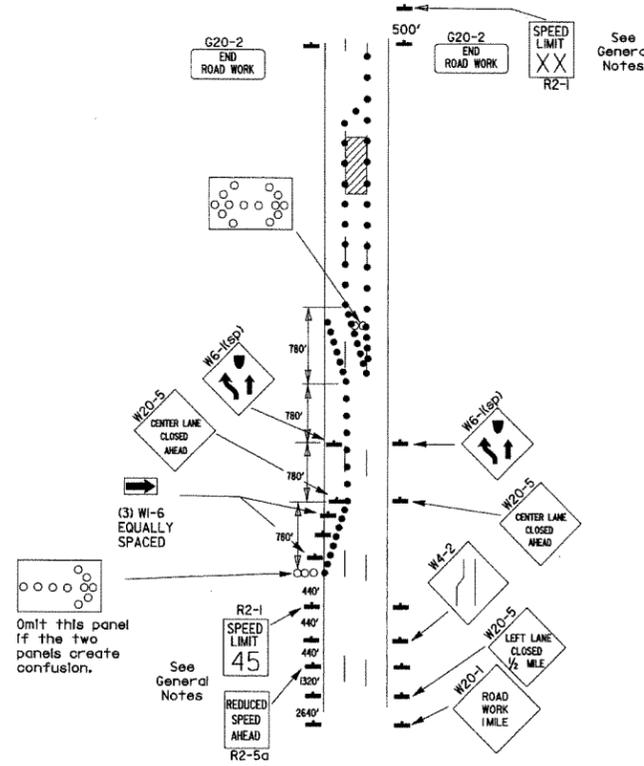


(B) Typical application - 3-lane oneway roadway where center lane is closed.




- KEY:
- Arrow Panel (if Required)
  - Channelizing Device
  - Traffic drum

GENERAL NOTES:

1. A speed limit reduction may be implemented ONLY when designated in the plan or when recommended by the Roadway Design Division.
2. When the existing speed limit is 55mph and the plans require a speed limit of 45mph, the R2-1(55) shall be omitted and the R2-5a shall be installed at that location. Additional R2-145mph speed limit signs shall be installed at a maximum of 1 mile intervals. At the end of the work area a R2-1(XX) shall be installed to match original speed limit.
3. When the existing speed limit is 65mph and the plans require a speed limit of 55mph, the R2-1(45) shall be omitted. Additional R2-155mph speed limit signs shall be installed at a maximum of 1 mile intervals. At the end of the work area a R2-1(XX) shall be installed to match original speed limit.
4. The maximum spacing between channelizing devices in a taper should be approximately equal in feet to the speed limit. Beyond the taper, maximum spacing shall be two times the speed limit or as directed by the Engineer.
5. Warning lights and/or flags may be mounted to signs or channelizing devices at night as needed.
6. Pavement markings no longer applicable which might create confusion in the minds of vehicle operators shall be removed or obliterated as soon as practicable.
7. The G20-1 sign will be required on jobs of over two miles in length. When the lane closure is not at the beginning of the project, the G20-1 sign shall be erected 125' in advance of the job limit. Additional W20-1 (1 MILE) signs are not required in advance of lane closures that begin inside the project limits.
8. Flaggers shall use STOP/SLOW paddles for controlling traffic through work zones. Flags may be used only for emergency situations.
9. All plastic drums and cones shall meet the requirements of NCHRP-350 or Manual for Assessing Safety Hardware (MASH).
10. Trailer mounted devices such as arrow panels and portable changeable message signs shall be delineated by affixing conspicuity material in a continuous line on the face of the trailer. When placed on or adjacent to the shoulder and not behind a positive barrier, these devices shall be delineated by placing five (5) traffic drums, equally spaced along the traffic side of the device.

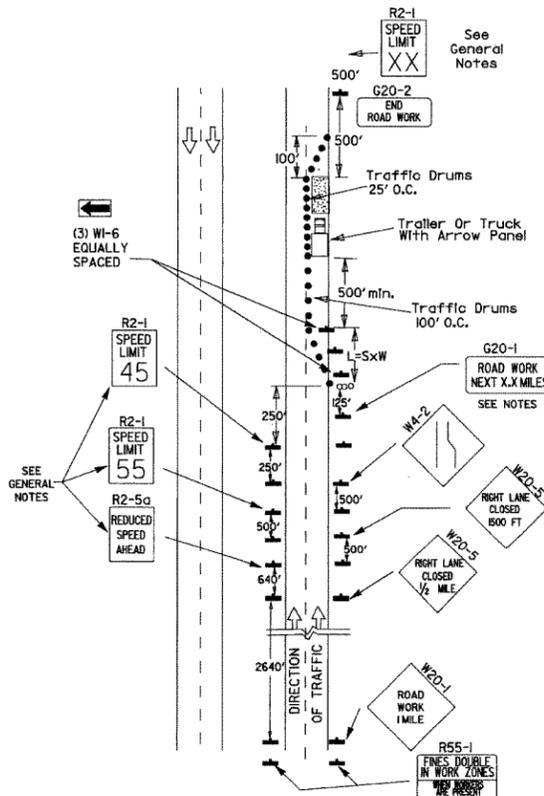

(C) Typical application - construction operations of intermediate to long term duration on a 4-lane divided roadway where half of the roadway is closed.

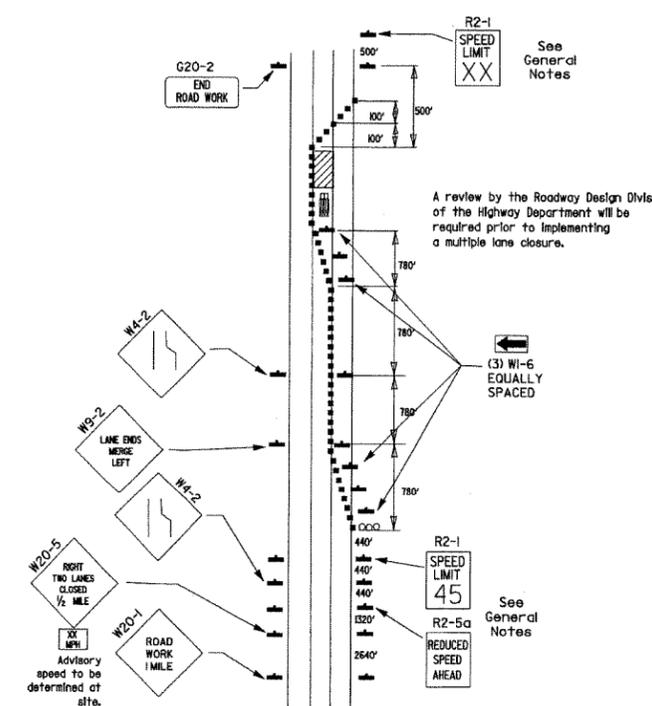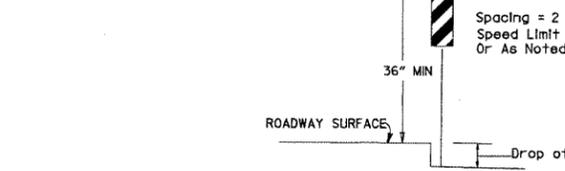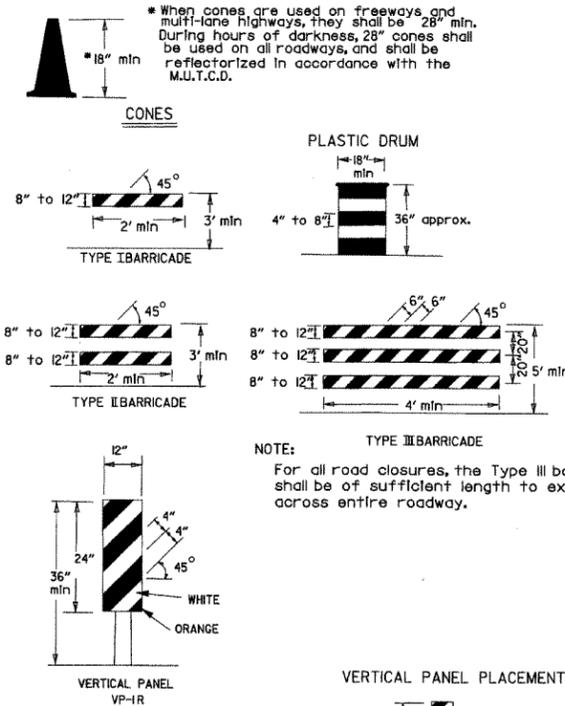


(D) Typical application - closing multiple lanes of a multilane highway.



TRAFFIC CONTROL DEVICES FOR VERTICAL PAVEMENT DIFFERENTIALS

VERTICAL DIFFERENTIAL	LOCATIONS	TRAFFIC CONTROL
1" to 3"	Centerline, lane lines	W8-11
1" to 3"	Edge of shoulder	W8-9
Greater than 3"	Lane lines	Standard lane closure required
Greater than 3"	Edge of traveled lane	*RSP-land vertical panels, drums or concrete barrier
Greater than 3"	Edge of shoulder	*Vertical panels, drums or concrete barrier

\* When shown on the plans concrete barrier will be used.  
When the shoulder area is used as part of the traveled lane and there is insufficient width to place drums on the remaining shoulder width, then vertical panels shall be used.

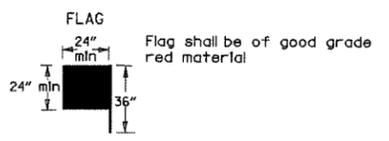

STOP SLOW PADDLE

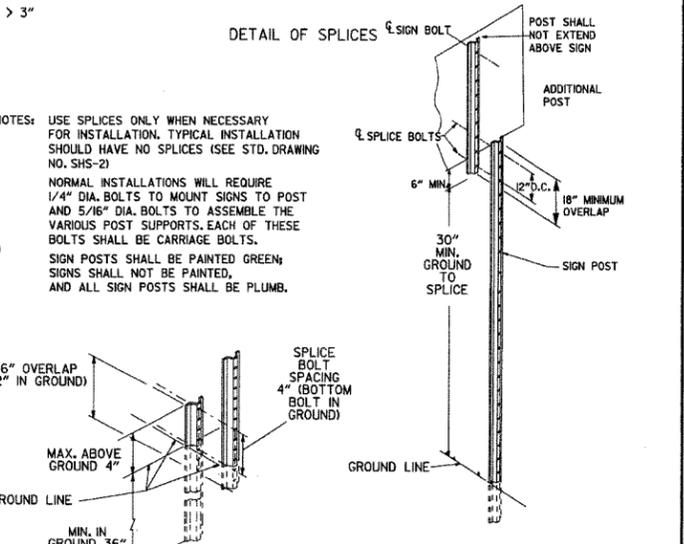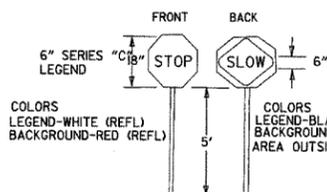


NOTES:

- USE SPLICES ONLY WHEN NECESSARY FOR INSTALLATION. TYPICAL INSTALLATION SHOULD HAVE NO SPLICES (SEE STD. DRAWING NO. SHS-2)
- NORMAL INSTALLATIONS WILL REQUIRE 1/4" DIA. BOLTS TO MOUNT SIGNS TO POST AND 5/16" DIA. BOLTS TO ASSEMBLE THE VARIOUS POST SUPPORTS. EACH OF THESE BOLTS SHALL BE CARRIAGE BOLTS.
- SIGN POSTS SHALL BE PAINTED GREEN; SIGNS SHALL NOT BE PAINTED, AND ALL SIGN POSTS SHALL BE PLUMB.

DATE	REVISION	FILMED
10-16-09	ADDED REFERENCE TO MASH	
11-20-08	REVISED SIGN DESIGNATIONS	
11-18-04	ADDED NOTE	
10-1-98	ADDED NOTE	
4-03-97	ADDED (SP) TO W6-1 & REVISED TRAFFIC CONTROL DEVICES NOTE	
10-18-96	ADDED R55-1	
10-12-95	MOVED UPPER SPLICE	
6-8-95	REVISED SPLICE DETAIL, TEXT	6-8-95
2-2-95	REVISED PER PART VI, MUTCD, SEPT. 3, 1993	
8-15-91	DRAWN AND PLACED IN USE	


ARKANSAS STATE HIGHWAY COMMISSION  
STANDARD TRAFFIC CONTROLS FOR HIGHWAY CONSTRUCTION  
STANDARD DRAWING TC-3

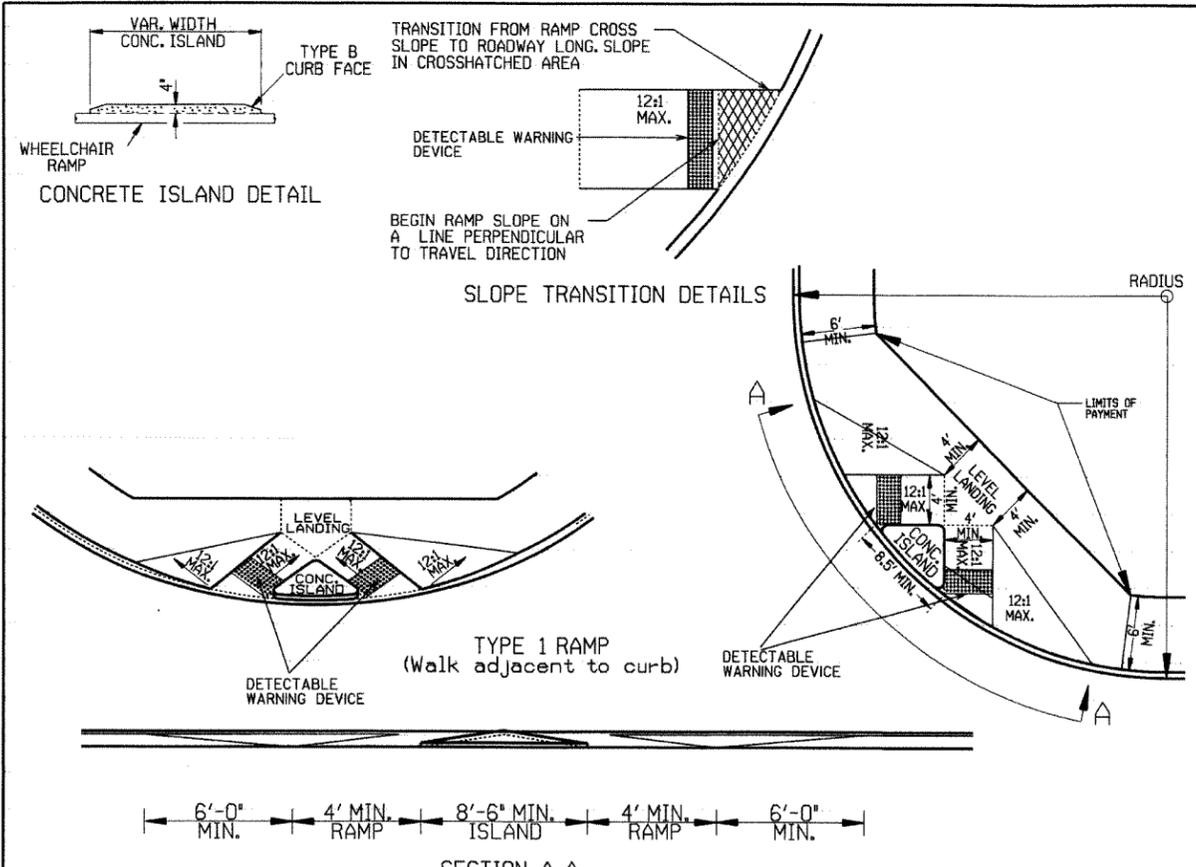



**TYPE 1 RAMP DIMENSIONS AND QUANTITIES**

RADIUS 'R'	DISTANCE 'X'	DISTANCE 'Y'	LENGTH 'L'	RAMP AREA 'A'
FEET	FEET	FEET	FEET	SQ. YD.
15	11.67	18.82	32.18	26.21
20	11.52	22.28	35.46	30.07
25	11.43	26.60	38.77	33.80
30	11.37	30.26	40.33	36.90
35	11.33	33.51	43.11	39.77
40	11.30	36.45	45.26	42.45
45	11.27	39.16	47.34	44.97
50	11.25	41.69	49.36	47.35
55	11.24	44.07	51.31	49.63
60	11.22	46.33	53.21	51.80

**GENERAL NOTES FOR DETECTABLE WARNING DEVICES**  
 THE DETECTABLE WARNING DEVICE SHALL BE LOCATED SO THAT THE NEAREST EDGE OF THE DEVICE IS 6 TO 8 INCHES FROM THE FACE OF THE CURB. TRUNCATED DOMES IN THE DETECTABLE WARNING SURFACE SHALL MEET THE REQUIREMENTS OF THE GEOMETRIC CONFIGURATION SHOWN. DOMES SHALL BE ALIGNED ON A SQUARE GRID IN THE PREDOMINANT DIRECTION OF TRAVEL TO PERMIT WHEELS TO ROLL BETWEEN DOMES. DETECTABLE WARNING DEVICE SHALL BE 24 INCHES IN THE DIRECTION OF TRAVEL AND EXTEND THE FULL WIDTH OF THE CURB RAMP OR FLUSH SURFACE. DETECTABLE WARNING DEVICE SHALL BE ON THE AHTD QUALIFIED PRODUCTS LIST FOR CAST-IN-PLACE TACTILE PANELS (ADA DETECTABLE WARNING).

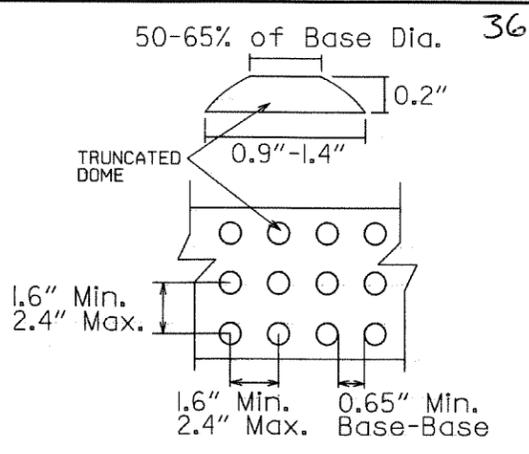


DETECTABLE WARNING DEVICE DETAIL

 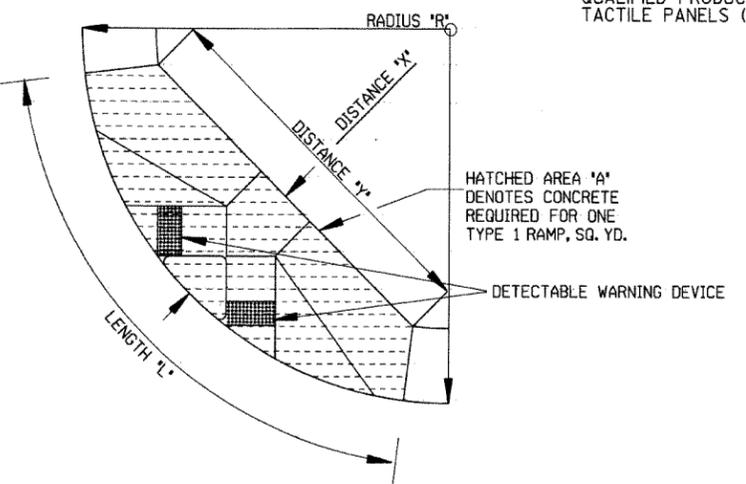


SECTION A-A


**NOTE:**  
 THE CROSS SLOPE OF THE RAMPS, LEVEL LANDINGS, AND SIDEWALKS SHALL NOT EXCEED 2.0% UNLESS REQUIRED TO MATCH STREET LONGITUDINAL GRADE.

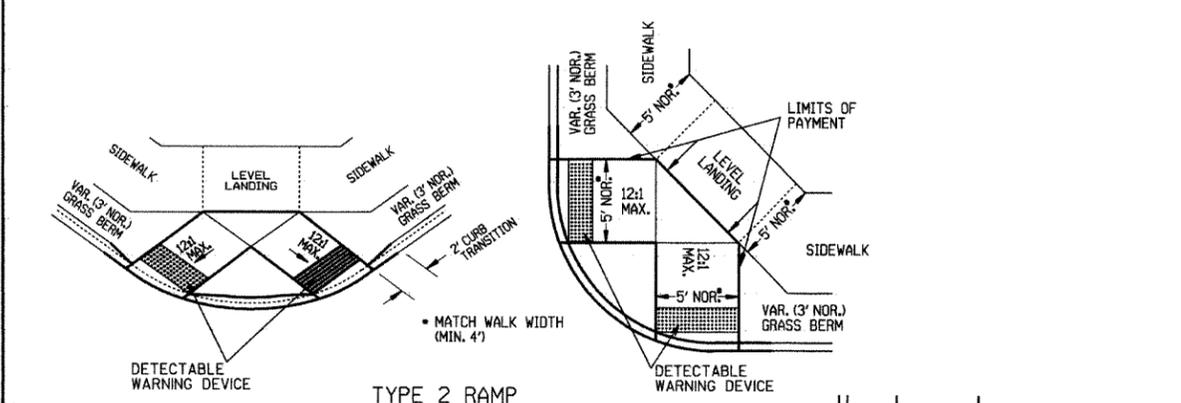


TYPE 2 RAMP

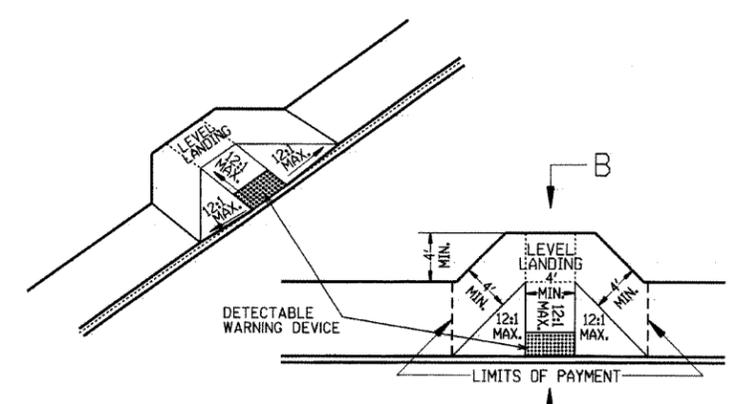

TYPE 4 RAMP (Walk adjacent to curb)

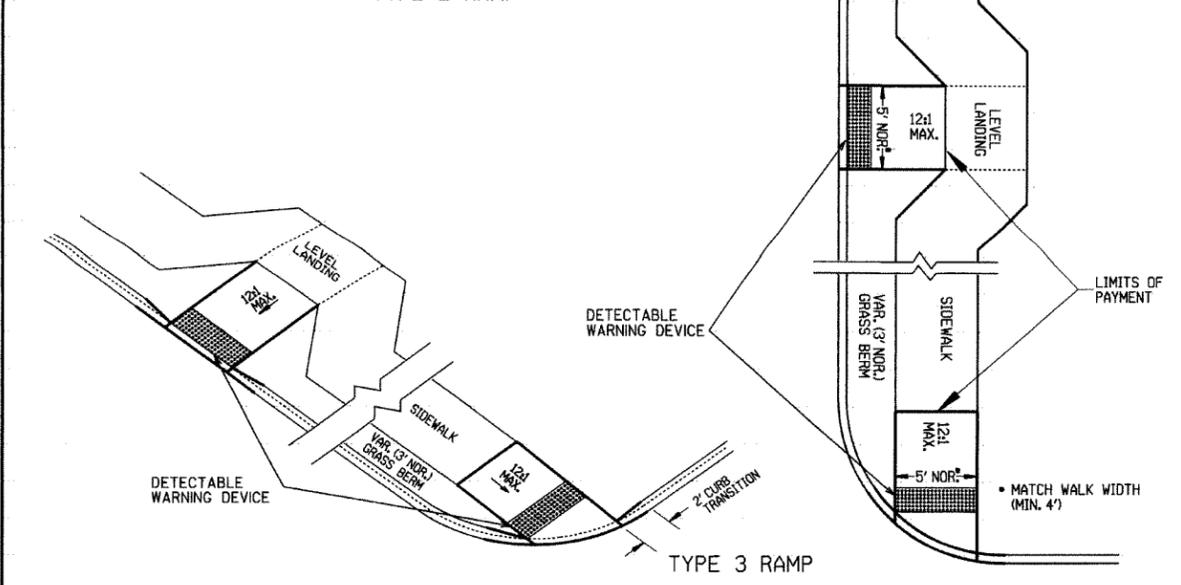

TYPE 3 RAMP

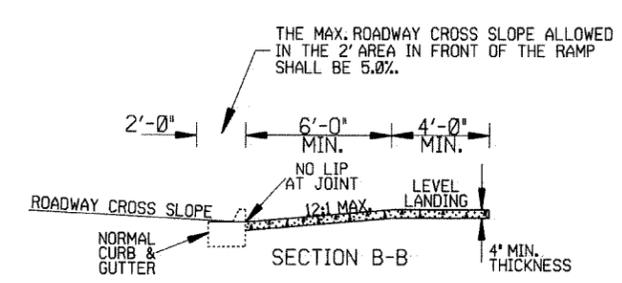

SECTION B-B

**GENERAL NOTES:**

IN NEW CONSTRUCTION, UNLESS OTHERWISE INDICATED ON THE PLANS, WHEELCHAIR RAMPS ARE TO BE PROVIDED AT ALL CORNERS OF CURBED STREET INTERSECTIONS AND MID-BLOCK CROSSWALK LOCATIONS. IN ALTERATIONS WHEELCHAIR RAMPS ARE TO BE PROVIDED AT CURBED STREET INTERSECTIONS WITH PEDESTRIAN TRAFFIC AND MID-BLOCK CROSSWALK LOCATIONS. THE LENGTH OF THE RAMP SHALL BE SUCH THAT THE SLOPE DOES NOT EXCEED 12:1. THE SURFACE TEXTURE OF THE RAMP SHALL CONFORM TO A CLASS 6 FINISH ACCORDING TO SECTION 802.19. THE NORMAL GUTTER GRADE SHALL BE MAINTAINED THROUGH THE AREA OF THE RAMP. ALL PAVEMENT MARKINGS SHALL BE IN ACCORDANCE WITH THE LATEST EDITION OF THE MANUAL OF UNIFORM TRAFFIC CONTROL DEVICES PUBLISHED BY THE FEDERAL HIGHWAY ADMINISTRATION. THE MINIMUM THICKNESS OF THE RAMP, WALK, & LANDING SHALL BE 4". THE MINIMUM WIDTH OF THE RAMPS SHALL BE THE WALK WIDTH OR 36", WHICHEVER IS GREATER. RAMPS SHALL BE MODIFIED AS NECESSARY TO INSURE THAT THEY ARE PARALLEL TO A LINE DRAWN FROM THE CENTER OF ONE RAMP TO THE CENTER OF THE RAMP ON THE OPPOSITE SIDE OF THE INTERSECTION. THE DIMENSIONS AND QUANTITIES SHOWN ON THIS DRAWING ARE FOR A 90° INTERSECTION ONLY. DIMENSIONS AND QUANTITIES FOR SKEWED INTERSECTIONS WILL VARY, AND ARE TO BE DETERMINED BY THE ENGINEER.

**RAMP SELECTION CRITERIA**

CHOICE	TYPE	DESCRIPTION
FIRST CHOICE	TYPE 1	CORNER LOCATIONS WITH THE WALK ADJACENT TO THE CURB (BOTH NEW CONSTRUCTION AND ALTERATIONS).
	TYPE 2	CORNER LOCATIONS WITH THE WALK OFFSET FROM THE CURB A DISTANCE INSUFFICIENT TO ALLOW THE REQUIRED RAMP SLOPE (BOTH NEW CONSTRUCTION AND ALTERATIONS).
	TYPE 3	CORNER LOCATIONS WITH THE WALK OFFSET FROM THE CURB A DISTANCE SUFFICIENT TO ALLOW THE REQUIRED RAMP SLOPE (BOTH NEW CONSTRUCTION AND ALTERATIONS).
	TYPE 4	TANGENT LOCATIONS (BOTH NEW CONSTRUCTION AND ALTERATIONS).
SECOND CHOICE	TYPE 5	TANGENT LOCATIONS (ALTERATIONS ONLY).
THIRD CHOICE	TYPE 6	CORNER LOCATIONS (ALTERATIONS ONLY). THIS RAMP MAY BE USED ONLY IF THE TYPE 5 RAMPS CANNOT BE PLACED AT THE ENDS OF THE RADIUS.
FOURTH CHOICE		IF SITE CONSTRAINTS PREVENT THE CONSTRUCTION OF ANY OF THE TYPES LISTED, THEN AND ONLY THEN CAN THE 12:1 MAX. SLOPE ON THE RAMP BE EXCEEDED TO PROVIDE ACCESS TO THE STREET LEVEL (ALTERATIONS ONLY). THE SLOPE CAN BE STEEPENED TO A 10:1 MAX. FOR A MAX. LENGTH OF 5' OR A 8:1 MAX. FOR A MAX. LENGTH OF 2'. SLOPES STEEPER THAN 8:1 ARE NOT ALLOWED UNDER ANY CIRCUMSTANCES.

**NOTE:** IN ALTERATIONS, THE SELECTION OF THE TYPE OF WHEELCHAIR RAMP TO BE CONSTRUCTED SHALL BE BASED ON THE AMOUNT OF RIGHT-OF-WAY AVAILABLE, AND ON THE PRESENCE OF OTHER SITE CONSTRAINTS (UTILITIES, BUILDINGS, ETC.). THE TABLE ABOVE LISTS THE ORDER IN WHICH THE RAMPS ARE TO BE CONSIDERED. AN ALTERATION IS DEFINED AS A PROJECT THAT CHANGES OR AFFECTS THE USE OF A PEDESTRIAN PATHWAY (OVERLAYS, SIGNALIZATION PROJECTS, ETC.) BUT DOES NOT REQUIRE THE PURCHASE OF ADDITIONAL RIGHT-OF-WAY. ALL PROJECTS THAT REQUIRE THE PURCHASE OF ADDITIONAL RIGHT-OF-WAY WILL USUALLY BE CONSIDERED NEW CONSTRUCTION FOR THE PURPOSES OF THE CHART ABOVE.

DATE	REVISION	DATE FILED
11-10-05	REVISED TO NEW SIDEWALK POLICY	
10-9-03	REVISED GEN. NOTES & ADDED NOTE	
4-10-03	REV. DETECTABLE WARNING DEVICES	
8-22-02	ADD DETECTABLE WARNING DEVICES	
3-30-00	ADD SLOPE TRANS. & REV. ISL. DIMS.	
11-18-98	REVISED NOTES	
8-12-98	REVISED TEXTURE	
7-02-98	REDRAWN & REISSUED	
10-18-96	CORRECTED DIMENSIONS	10-18-96
5-24-90	FROM 4:02 MAX. SLOPES	5-24-90
7-15-88	ADJUSTED MAX. SLOPE	652-1-15-88
7-14-88	INCL. CONC. ISL. IN PAY ITEM	
6-02-76	ISSUED-P.H.D.	299-7-28-76

ARKANSAS STATE HIGHWAY COMMISSION

WHEELCHAIR RAMPS  
 NEW CONSTRUCTION  
 AND ALTERATIONS

STANDARD DRAWING WR-1